

ISFA RATE FIELD - WASTE/VENT PIPING FY2026


ISFA

333 W 35TH STREET
CHICAGO, IL 60616


NOVEMBER 14, 2025
ISSUE FOR BID



SHEET LIST TABLE		
SHEET NUMBER	SHEET TITLE	
GENERAL		
G0.001	PROJECT COVER SHEET	
PLUMBING		
P.001	PLUMBING TITLE SHEET	
P.002	PLUMBING PLAN - UNDERGROUND - SECTION 1	SECTION 1
P.003	PLUMBING PLAN - UNDERGROUND - SECTION 1	SECTION 1
P.004	PLUMBING PLAN - UNDERGROUND - SECTION 1	SECTION 1
P.005	PLUMBING PLAN - UNDERGROUND - SECTION 1	SECTION 1
P.006	PLUMBING PLAN - UNDERGROUND - SECTION 1	SECTION 1
P.007	PLUMBING PLAN - UNDERGROUND - SECTION 1	SECTION 1
P.008	PLUMBING PLAN - UNDERGROUND - SECTION 1	SECTION 1
P.009	PLUMBING PLAN - UNDERGROUND - SECTION 1	SECTION 1
P.010	PLUMBING PLAN - UNDERGROUND - SECTION 1	SECTION 1
P.011	PLUMBING PLAN - UNDERGROUND - SECTION 1	SECTION 1
P.001	PLUMBING PLAN - SERVICE LEVEL - SECTION 1	SECTION 1
P.002	PLUMBING PLAN - SERVICE LEVEL - SECTION 2	SECTION 2
P.003	PLUMBING PLAN - SERVICE LEVEL - SECTION 3	SECTION 3
P.004	PLUMBING PLAN - SERVICE LEVEL - SECTION 4	SECTION 4
P.005	PLUMBING PLAN - SERVICE LEVEL - SECTION 5	SECTION 5
P.006	PLUMBING PLAN - SERVICE LEVEL - SECTION 6	SECTION 6
P.007	PLUMBING PLAN - SERVICE LEVEL - SECTION 7	SECTION 7
P.008	PLUMBING PLAN - SERVICE LEVEL - SECTION 8	SECTION 8
P.009	PLUMBING PLAN - SERVICE LEVEL - SECTION 5	SECTION 5
P.010	PLUMBING PLAN - SERVICE LEVEL - SECTION 6	SECTION 6
P.011	PLUMBING PLAN - SERVICE LEVEL - SECTION 7	SECTION 7
P.102	PLUMBING PLAN - LEVEL 100 - SECTION 2	SECTION 2
P.103	PLUMBING PLAN - LEVEL 100 - SECTION 3	SECTION 3
P.104	PLUMBING PLAN - LEVEL 100 - SECTION 4	SECTION 4
P.105	PLUMBING PLAN - LEVEL 100 - SECTION 5	SECTION 5
P.106	PLUMBING PLAN - LEVEL 100 - SECTION 6	SECTION 6
P.107	PLUMBING PLAN - LEVEL 100 - SECTION 7	SECTION 7
P.108	PLUMBING PLAN - LEVEL 100 - SECTION 8	SECTION 8
P.109	PLUMBING PLAN - LEVEL 100 - SECTION 9	SECTION 9
P.110	PLUMBING PLAN - LEVEL 100 - SECTION 10	SECTION 10
P.111	PLUMBING PLAN - LEVEL 200 - SECTION 11	SECTION 11
P.203	PLUMBING PLAN - LEVEL 200 - SECTION 3	SECTION 3
P.204	PLUMBING PLAN - LEVEL 200 - SECTION 4	SECTION 4
P.205	PLUMBING PLAN - LEVEL 200 - SECTION 5	SECTION 5
P.206	PLUMBING PLAN - LEVEL 200 - SECTION 6	SECTION 6
P.207	PLUMBING PLAN - LEVEL 200 - SECTION 7	SECTION 7
P.208	PLUMBING PLAN - LEVEL 200 - SECTION 8	SECTION 8
P.209	PLUMBING PLAN - LEVEL 200 - SECTION 9	SECTION 9
P.210	PLUMBING PLAN - LEVEL 200 - SECTION 10	SECTION 10
P.300	PLUMBING PLAN - LEVEL 300 - SECTION 4	SECTION 4
P.305	PLUMBING PLAN - LEVEL 300 - SECTION 5	SECTION 5
P.306	PLUMBING PLAN - LEVEL 300 - SECTION 6	SECTION 6
P.307	PLUMBING PLAN - LEVEL 300 - SECTION 7	SECTION 7
P.308	PLUMBING PLAN - LEVEL 300 - SECTION 8	SECTION 8
P.309	PLUMBING PLAN - LEVEL 300 - SECTION 9	SECTION 9
P.404	PLUMBING PLAN - LEVEL 400 - SECTION 4	SECTION 4
P.405	PLUMBING PLAN - LEVEL 400 - SECTION 5	SECTION 5
P.406	PLUMBING PLAN - LEVEL 400 - SECTION 6	SECTION 6
P.407	PLUMBING PLAN - LEVEL 400 - SECTION 7	SECTION 7
P.408	PLUMBING PLAN - LEVEL 400 - SECTION 8	SECTION 8
P.409	PLUMBING PLAN - LEVEL 400 - SECTION 9	SECTION 9
P.410	PLUMBING PLAN - LEVEL 400 - SECTION 10	SECTION 10
P.503	PLUMBING PLAN - LEVEL 500 - SECTION 3	SECTION 3
P.504	PLUMBING PLAN - LEVEL 500 - SECTION 4	SECTION 4
P.505	PLUMBING PLAN - LEVEL 500 - SECTION 5	SECTION 5
P.506	PLUMBING PLAN - LEVEL 500 - SECTION 6	SECTION 6
P.507	PLUMBING PLAN - LEVEL 500 - SECTION 7	SECTION 7
P.508	PLUMBING PLAN - LEVEL 500 - SECTION 8	SECTION 8
P.509	PLUMBING PLAN - LEVEL 500 - SECTION 9	SECTION 9
P.510	PLUMBING PLAN - LEVEL 500 - SECTION 10	SECTION 10
P.001	PLUMBING DETAILS	
P.001 PLUMBING SCHEDULES		
P.001 PLUMBING SPECIFICATIONS		

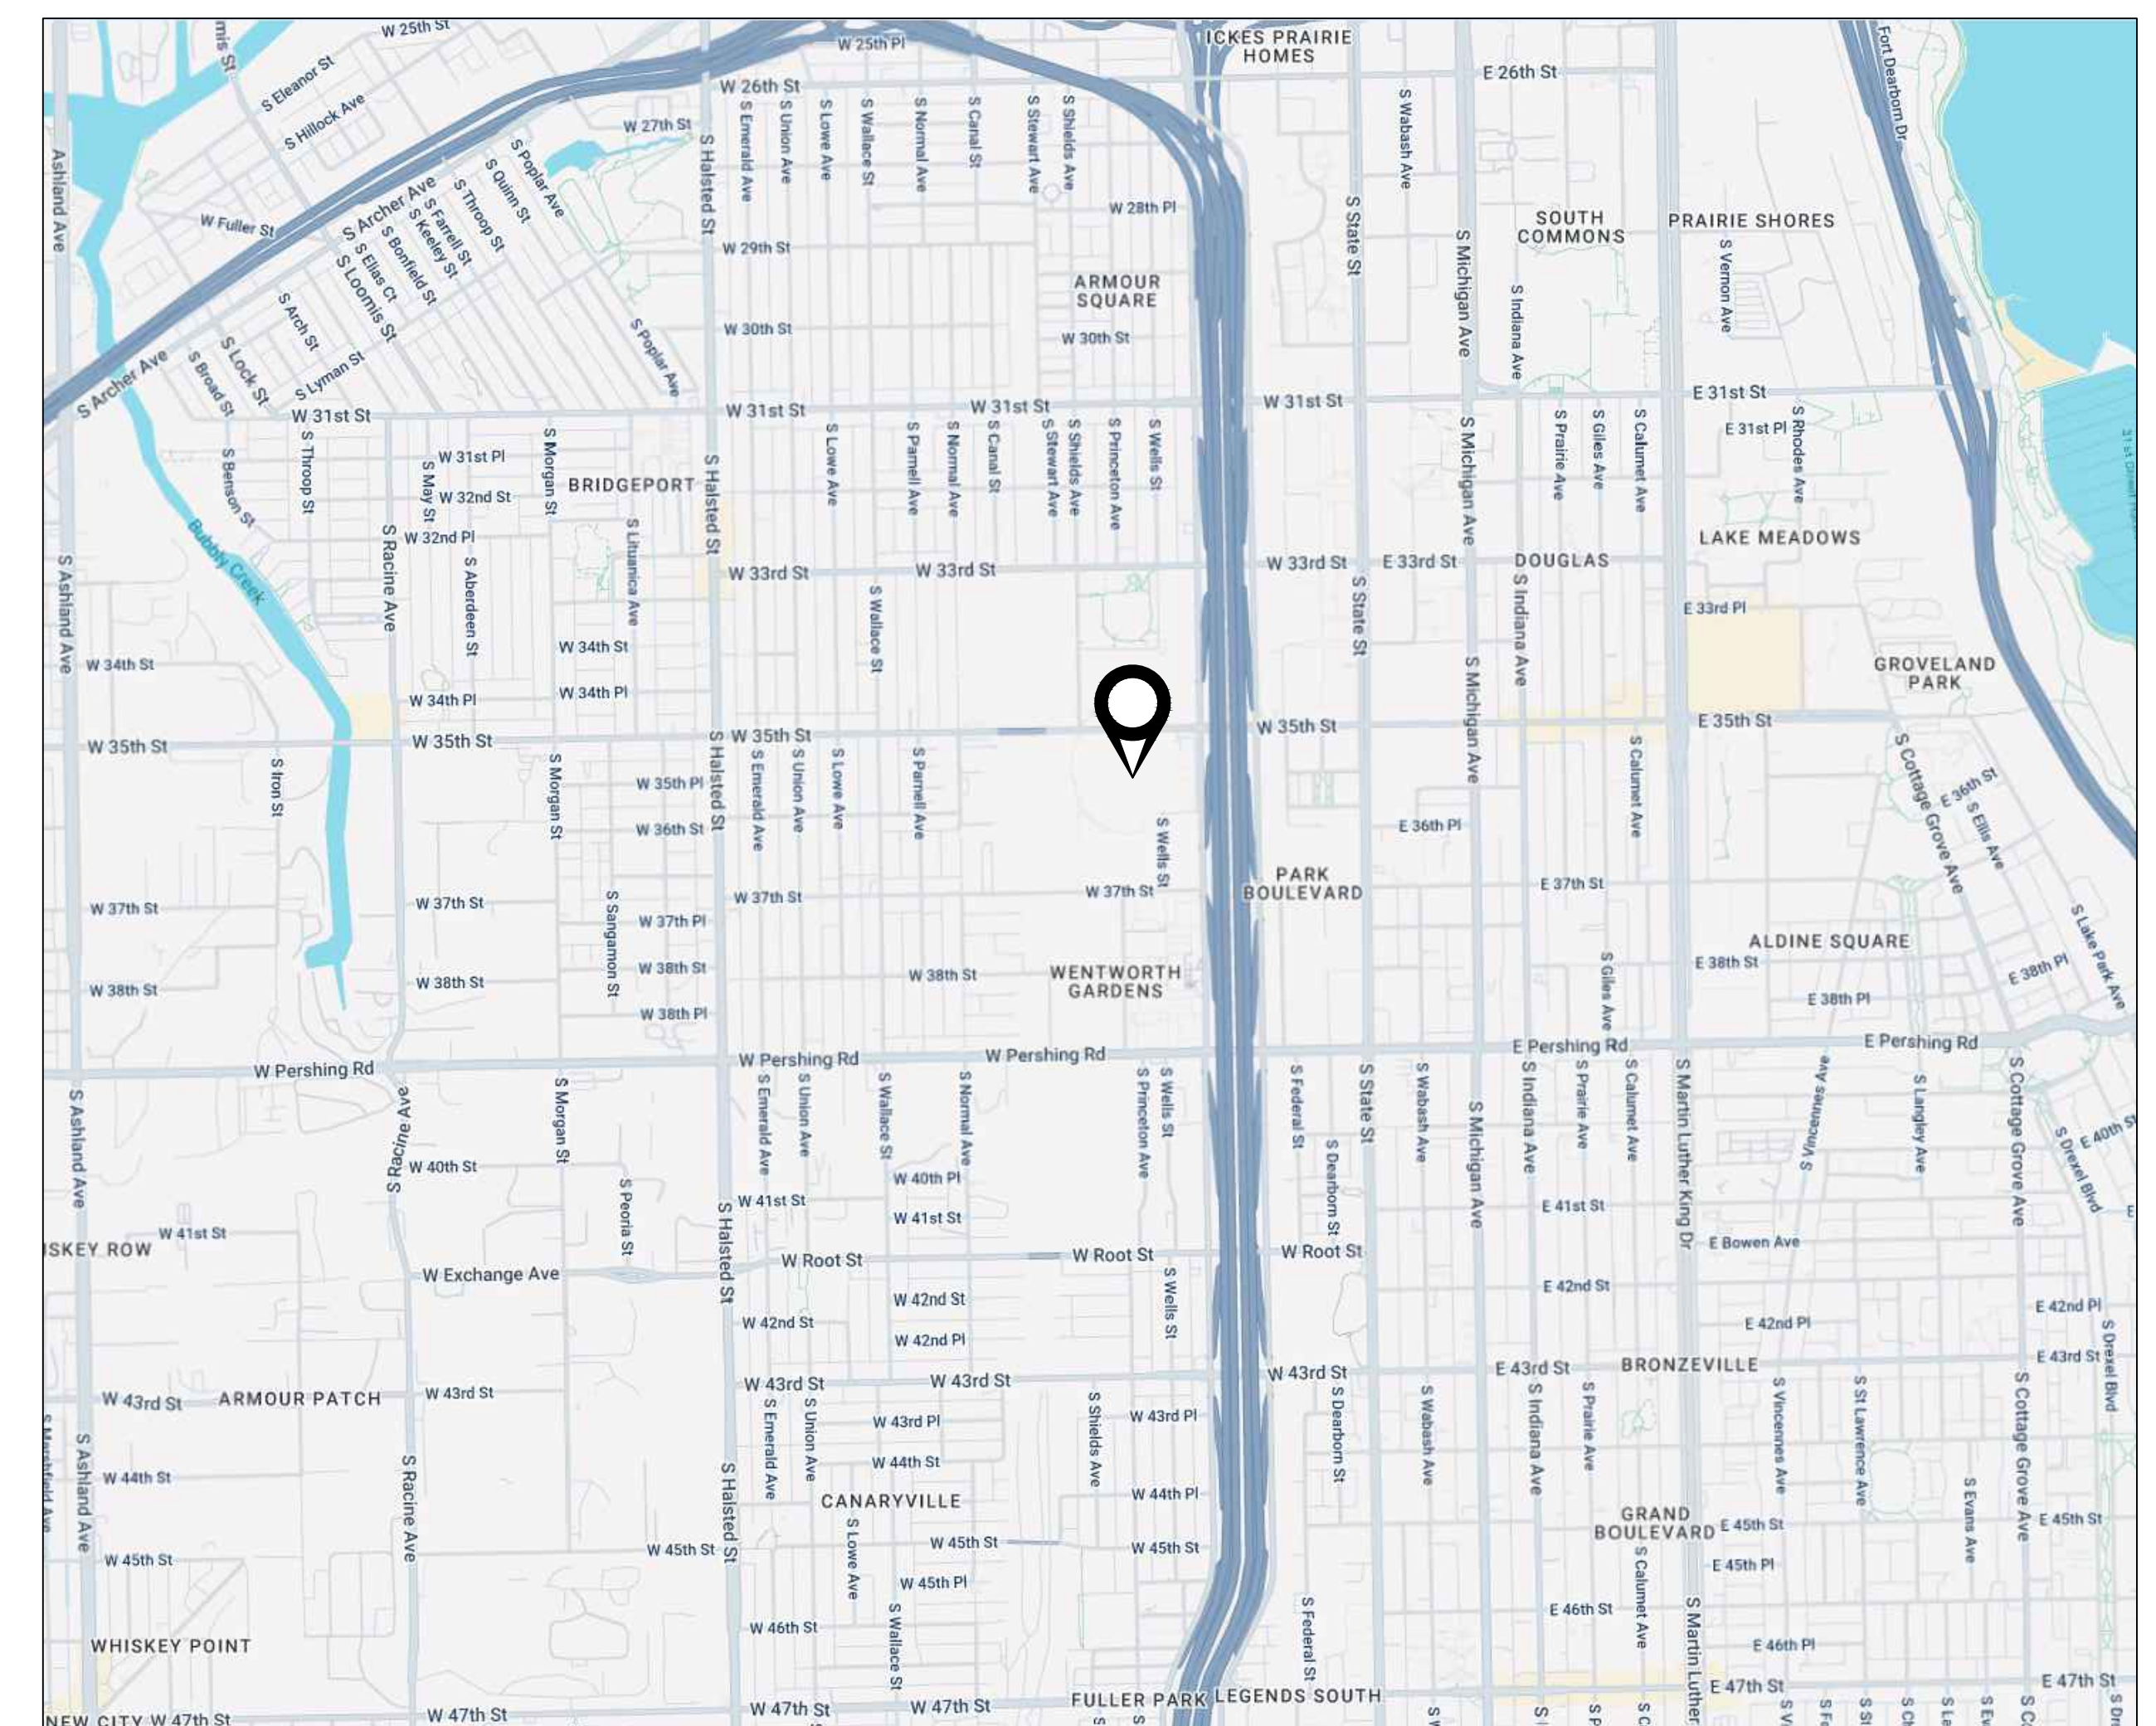

1 LOCATION MAP

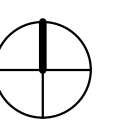[illegible]



DEPARTMENT OF BUILDINGS
CITY OF CHICAGO
ADMINISTRATIVE RELIEF

 Application No. **18-01556**

Project Address: **331 N. W. Chicago St. 2nd**

Project name: **100 Colfax Hall**

SUBJECT OF REQUEST: Possible Structural Material

Administrative Relief is granted to the above address regarding the code section 18-220.1
_____ providing to the use of polypropylene mesh within hollow hole in line of new brick building
 for the interior, basement project (conclusion may be from the code inspectors and their desire to be
 more flexible on this matter.)

Notified (Date), the said firm the said machine is causing constant deterioration of the said brick
element since polypropylene mesh is much more resistant to acidic waste than concrete is. Administrative
is granted on no permanent basis on the 12/1/18.

This Administrative Relief is granted only to this address under the specific scope for this project
 of use of space as is shown or the scope of work under this permit change this Relief if
 needed.

Once signed by the Commissioner of the Department of Buildings, this form must be
 submitted immediately to the permit or of the contractor documents.

Noted and Monitored
Continuation

Contract Name: South Side
 Contract Number: 131-0001401
 Date: 11/27/2018

OFFICE USE ONLY
 Reviewed by: KEVIN GELBERG
 Reviewed Date: 11/14/18
 Recommended by: R. S. FERRER
11/14/18

100 NORTH BACON AVENUE, CHICAGO, ILLINOIS 60607

MEPFP
ENGINEERING

ELARA ENGINEERING

30 N WOLF RD
SECOND FLOOR
HILLSDALE, IL 60162

(708) 236-0300

PROJECT SCOPE OF WORK

1. REPLACE GREASE TRAP AT RATE FIELD KITCHEN SPACE AS IDENTIFIED.
2. REPLACE STORM PUMP SYSTEMS IN AREAS IDENTIFIED.
3. COMPLETE OWNER SUITE SCOPING IN AREAS IDENTIFIED.
4. COMPLETE UNDERGROUND SCOPING TO BE PERFORMED IN AREAS IDENTIFIED.
5. REPLACE PUBLIC LAVATORY FAUCETS, ACCESSORIES, COMPONENTS, SPECIALTIES, ETC.
6. REPAIR AND REPLACE 9 SECTIONS OF PIPING. USE ARW WHERE DESCRIBED.
7. REPLACE THE 2 LARGE MAIN WATER HEATER STORAGE TANKS, ONE AT A TIME.
8. VERIFY AND UPDATE RAMP DRAINS IN AREAS IDENTIFIED.

ELECTRICAL SCOPE OF WORK

1. DISCONNECT POWER AND RECONNECT POWER FOR IN-KIND REPLACEMENT FOR EJECTOR AND SUMP PUMPS FOR THE REQUIRED REPLACEMENT SCOPE.

PROJECT REQUIREMENTS

1. ANY EXISTING EQUIPMENT TO DEMOLISHED SHALL BE COORDINATED WITH CHICAGO WHITE SOX SO THE CHICAGO WHITE SOX MAINTENANCE STAFF MAY SALVAGE EQUIPMENT, PARTS, COMPONENTS, ETC. INCLUDING BUT NOT LIMITED TO LAVATORY FAUCETS REPLACEMENT SCOPE PARTS.
2. ANY PIPING MATERIAL AND ASSOCIATED COMPONENTS TO DEMOLISHED SHALL BE COORDINATED WITH CHICAGO WHITE SOX PRIOR TO DISPOSAL.
3. CONTRACTOR REMAINS FULLY RESPONSIBLE FOR ALL DEMOLISHED EQUIPMENT, PIPING MATERIALS, PARTS, COMPONENTS, ETC. THAT CHICAGO WHITE SOX DOES NOT SALVAGE.
4. VARIABLE FREQUENCY DRIVES SHALL BE MANUFACTURED BY "ABB" ONLY.
5. COORDINATE ACCESS TO SPACES NECESSARY TO PERFORM WORK WITH ISFA. PORTIONS OF THE BUILDING WILL BE SECURED REGULARLY AND ISFA REQUIRES NOTIFICATION TO PROVIDE ACCESS.
6. CONTRACTOR SHALL ENDEAVOR TO SUBMIT SUBMITTALS TIMELY FOR REVIEW AND COORDINATION PURPOSES.

Y PLAN:

DATE/REVISION:

[illegible]

PROJECT:
GUARANTEED RATE FIELD -
WASTE/VENT PIPING FY2026

W 35TH STREET,
CHICAGO, ILLINOIS 60616

PROJECT COVER SHEET

SIGNED BY: CF

HECKED BY: MS

PROJECT NO: 250

SCALE	NO SCALE
-------	----------

FEET NO.





















































G0.001

ABBREVIATIONS

ACW	AUTOMATIC CLOTHES WASHER	KW	KITCHEN WASTE OR KILOWATT
AD	AREA DRAIN	L/LAV	LAVATORY
AFF	ABOVE FINISHED FLOOR	LS	LAB SINK
AMP	AMPERE	LT	LAUNDRY TUB
ANB	ACID NEUTRALIZING BASIN	MB	MOP BASIN
ANSI	AMERICAN NATIONAL STANDARDS INSTITUTE	MC	MECHANICAL CONTRACTOR
AP	ACCESS PANEL	MS	MANUFACTURERS STANDARDIZATION SOCIETY
ASME	AMERICAN SOCIETY OF MECHANICAL ENGINEERS	NC	NEW CONNECTION OR NORMALLY CLOSED
ASSE	AMERICAN SOCIETY OF SAFETY ENGINEERS	NT	NOT IN CONTRACT
ASTM	AMERICAN SOCIETY FOR TESTING AND MATERIALS	NPS	NOMINAL PIPE SIZE
AV	ACID/CHEMICAL VENT	NPW	NON POTABLE WATER
AVTR	ACID/CHEMICAL VENT THRU ROOF	NO	NORMALLY OPEN
AW	ACID/CHEMICAL WASTE	NSF	NATIONAL SCIENCE FOUNDATION
BASC	BUILDING AUTOMATION SYSTEMS CONTRACTOR	NTS	NOT TO SCALE
BFP	BACKFLOW PREVENTER	OD	OVERFLOW DRAIN
BOP	BOTTOM OF PIPE	OSD	OPEN SITE DRAIN
BT	BATH TUB	OSAY	OUTSIDE STEM AND YOKE
CA	COMPRESSED AIR	P	PUMP
CI	CAST IRON	PA	PIPE ANCHOR
CISPI	CAST IRON SOIL PIPE INSTITUTE	PC	PLUMBING CONTRACTOR
CIL	CILING	PD	PUMP DISCHARGE
CO	CLEANOUT	PDI	PLUMBING & DRAINAGE INSTITUTE
CON	CONNECTION	PE	PROFESSIONAL ENGINEER
COW	DOMESTIC COLD WATER	PH	PHASE
DHW	DOMESTIC HOT WATER	PIV	POST INDICATOR VALVE
DHWTR	DOMESTIC HOT WATER RETURN	PPM	PARTS PER MILLION
DTW	DOMESTIC TEMPERED WATER	PRV	PRESSURE REDUCING VALVE
DCV	DOUBLE CHECK VALVE	PS	POUNDS PER SQUARE INCH
DCV	DUAL CHECK VALVE	PSI	POUNDS PER SQUARE INCH
DCDA	DOUBLE CHECK DETECTOR ASSEMBLY	ORD	OVERFLOW ROOF DRAIN
DDCV	DOUBLE DETECTOR CHECK VALVE	RCP	RECIRCULATION PUMP
DF	DRINKING FOUNTAIN	RD	ROOF DRAIN
DFU	DRAINAGE FIXTURE UNIT	RH	ROOF HYDRANT
DIA	DIAMETER	ROB	ROD OUT BASIN
DN	DOWN	RPSA	REDUCED PRESSURE DETECTOR ASSEMBLY
DS	DOWNSPOUT	RPM	REVOLUTIONS PER MINUTE
DSN	DOWNSPOUT NOZZLE	RPZ	REDUCED PRESSURE ZONE BACKFLOW PREVENTER
DT	DRAIN TILE	S/ / SAN	SANITARY WASTE
DW	DISHWASHER	SC	SITE UTILITY CONTRACTOR
DWH	DOMESTIC WATER HEATER	SE	SEWAGE EJECTOR
DWS	DOMESTIC WATER SOFTENER	SH	SHOWER
EC	ELECTRICAL CONTRACTOR	SI	SOLIDS INTERCEPTOR
EDW	EMERGENCY EYE AND FACE WASH	SK	SINK
EPDM	ETHYLENE PROPYLENE DIENE MONOMER	SP	SUMP PUMP
ET	EXPANSION TANK	SQ	SQUARE FEET
ESH	EMERGENCY SHOWER	SS	SERVICE SINK
ESP	ELEVATOR SUMP PUMP	S.S.	STAINLESS STEEL
ETR	EXISTING TO REMAIN	ST	STORM
EWC	ELECTRIC WATER COOLER	SST	SECONDARY STORM (OVERFLOW)
EWV	ELECTRIC WATER HEATER	TB	THRUST BLOCK
FCO	FLOOR CLEANOUT	TD	TRENCH DRAIN
FD	FLOOR DRAIN	TMV	THERMOSTATIC MIXING VALVE
FOG	FATS, OILS AND GREASE	TRV	TEMPERATURE AND PRESSURE REDUCING VALVE
FPS	FEET PER SECOND	TYP	TYPICAL
FS	FLOOR SINK	UR	URNAL
FT	FEET	V	VENT
G	NATURAL GAS	VB	VACUUM BREAKER
GC	GENERAL CONTRACTOR	VTR	VENT THRU ROOF
GCO	GROUND CLEANOUT	W	WASTE
GI	GREASE INTERCEPTOR	WC	WATER CLOSET
GRD	GALLONS PER DAY	WCO	WALL CLEANOUT
GPH	GALLONS PER HOUR	WF	WASH FOUNTAIN
GPM	GALLONS PER MINUTE	WH	WALL HYDRANT
GT	GREASE TRAP	WHA	WATER HAMMER ARRESTOR
GW	GARAGE WASTE	WSB	WALL SUPPLY BOX
HB	HOSE BIBB	WSFU	WATER SUPPLY FIXTURE UNITS
HD	HEAD	YCO	YARD CLEANOUT
HP	HORSEPOWER	YH	YARD HYDRANT
HX	HEAT EXCHANGER		
IE	INVERT ELEVATION		
IWB	ICE MACHINE/REFRIGERATOR WALL BOX		
KS	KITCHEN STACK		
KEC	KITCHEN EQUIPMENT CONTRACTOR		
KED	KITCHEN EQUIPMENT DESIGNER		

NOTE: NOT ALL ABBREVIATIONS LISTED ABOVE MAY BE USED OR APPEAR IN THESE DRAWINGS

                                                    NOTE: NOT ALL ABBREVIATIONS LISTED ABOVE MAY BE USED OR APPEAR IN THESE DRAWINGS.

PLUMBING SYMBOLS			
GENERAL			
	FLOOR DRAIN		PIPE TEE, DOWN
	FLOOR SINK		PIPE TEE, 45° HORIZONTAL
	FLOOR CLEANOUT		PIPE TEE, 90° HORIZONTAL
	ROOF DRAIN		PIPE TEE, UP
	EMERGENCY SHUTOFF		PIPE UNION
	POINT OF CONNECTION OF NEW TO EXISTING WORK		THREADED HOSE CONNECTION
	POINT OF DEMOLITION TO EXISTING WORK		AIR CHAMBER
	ABBREVIATION		BALL VALVE
	EQUIPMENT TAG		BUTTERFLY VALVE
	NUMBER		CHECK VALVE
	ABBREVIATION		GAS COCK
	NUMBER		GATE VALVE
	MATCH LINE		GLOBE VALVE
	VIEW # SEE SHEET NO. XX ##		MANUAL BALANCING VALVE
	VIEW # SHEET #		NEEDLE VALVE
	VIEW # SECTION VIEW REFERENCE		OS&Y GATE VALVE
	KITCHEN EQUIPMENT TAG		PRESSURE REDUCING/REGULATING VALVE
PLUMBING			
	NEW PIPING		PRESSURE/SAFETY RELIEF VALVE
	EXISTING PIPING TO REMAIN		STRAINER
	EXISTING PIPING TO BE DEMOLISHED		STRAINER WITH BLOWDOWN VALVE
	NEW PIPE CONNECTION		THERMOSTATIC MIXING VALVE
	DIRECTION OF FLOW		BACKFLOW PREVENTER
	DIRECTION OF PIPE PITCH, DOWN		FLEXIBLE PIPE CONNECTOR (OR CONNECTION)
	PIPE BREAK LINE (OR CONTINUATION)		HOSE BIBB
	DOMESTIC COLD WATER PIPING		METER
	DOMESTIC HOT WATER SUPPLY PIPING		P-TRAP
	DOMESTIC HOT WATER RETURN PIPING		PIPE ALIGNMENT GUIDE
	DRAIN TILE PIPING		PIPE ANCHOR
	VENT PIPING		PIPE SLEEVE
	CLEANOUT		PIPE WELL
	ECCENTRIC PIPE REDUCER		PRESSURE GAUGE
	ORIFICE PIPE UNION		PRV STATION
	PIPE CAP		PUMP
	PIPE ELBOW, 30° HORIZONTAL		SHOWER
	PIPE ELBOW, 45° HORIZONTAL		TEST PLUG
	PIPE ELBOW, 90° HORIZONTAL		THERMOMETER
	PIPE ELBOW, TURNED DOWN		
	PIPE ELBOW, TURNED UP		
	PIPE REDUCER/INCREASER		
NOTE: NOT ALL SYMBOLS LISTED ABOVE MAY BE USED OR APPEAR IN THESE DRAWINGS.			



KEY PLAN:

ISSUE/REVISION:

REV.	DATE	DESCRIPTION
11/14/25		ISSUE FOR BID

PROJECT:

GUARANTEED RATE FIELD -
WASTE/VENT PIPING FY2026

333 W 35TH STREET,
CHICAGO, ILLINOIS 60616

DRAWING TITLE:

PLUMBING TITLE SHEET

DESIGNED BY: CF

CHECKED BY: MS


PROJECT NO: 25081

SCALE: NO SCALE

SHEET NO.

P0.001

KEY PLAN:

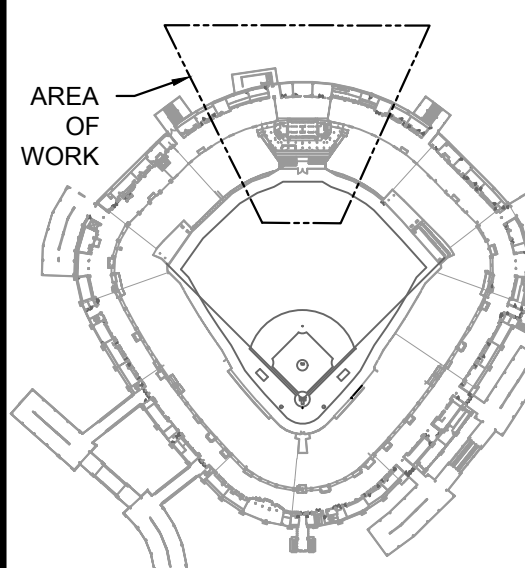

ISSUE/REVISION:

REV.	DATE	DESCRIPTION
11/14/25		ISSUE FOR BID

PROJECT:
GUARANTEED RATE FIELD -
WASTE/VENT PIPING FY2026


333 W 35TH STREET,
CHICAGO, ILLINOIS 60616

DRAWING TITLE:
PLUMBING PLAN - SERVICE
LEVEL - SECTION 1

DESIGNED BY: CF
CHECKED BY: MS
PROJECT NO: 25081
SCALE: 1/8" = 1'-0"

SHEET NO.

P1.S01

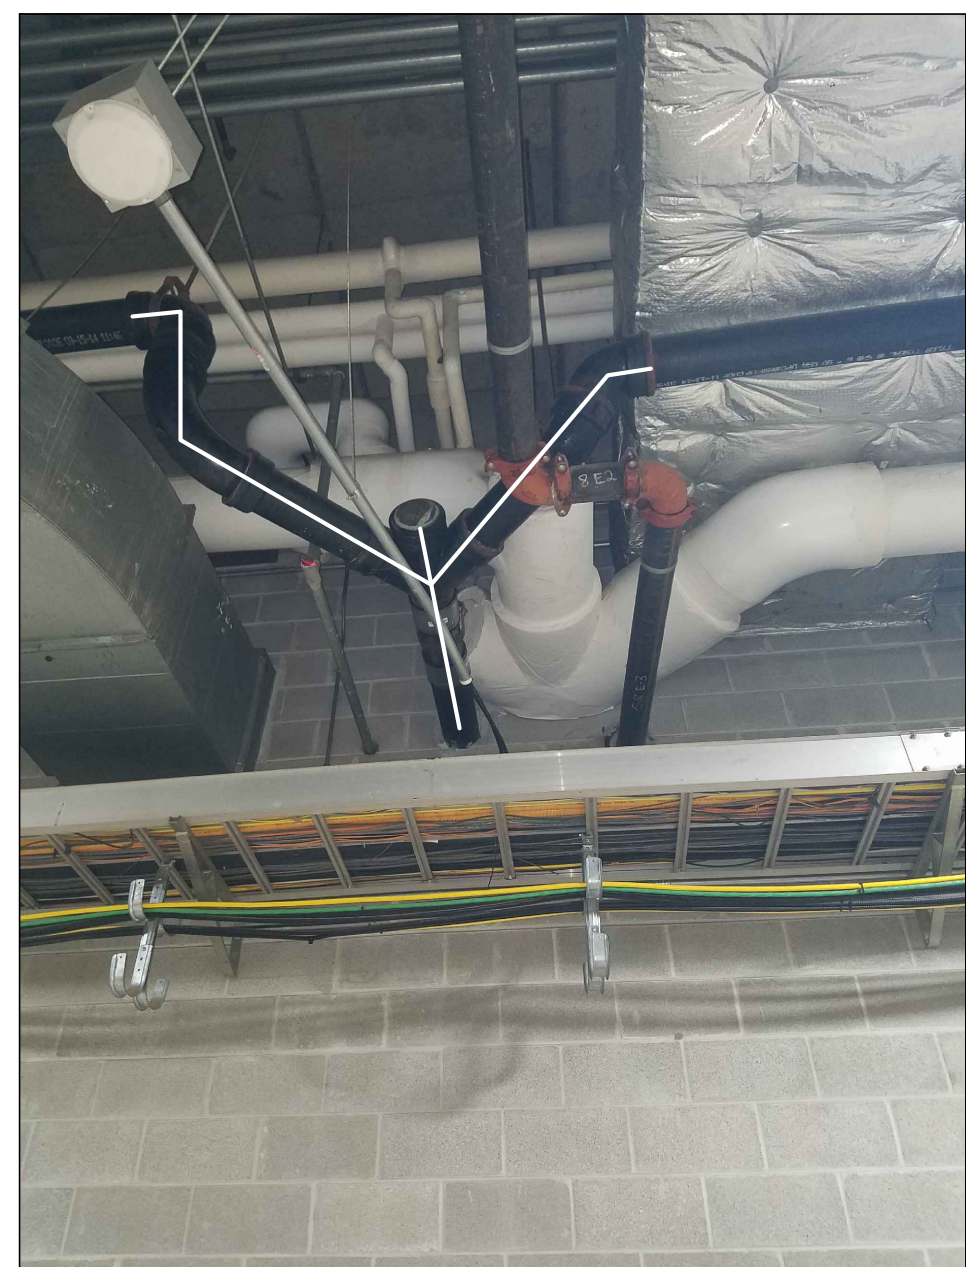

2 TUNNEL SERVICE 1.60.1 - SANITARY PIPING
SCALE: NO SCALE



3 MECHANICAL ROOM 1.1.5 - SANITARY PIPING
SCALE: NO SCALE



4 MECHANICAL ROOM 1.1.5 - SANITARY PIPING
SCALE: NO SCALE

KEYED PLUMBING SHEET NOTES

1. VERIFY LAVATORY FAUCET IS OLDER OBSOLETE SYMMONS FAUCET MODEL. WHERE OLDER OBSOLETE SYMMONS FAUCET MODEL IS PRESENT, REPLACE THE SYMMONS FAUCET WITH NEW REPLACEMENT SYMMONS FAUCET MODEL (SYMMONS MODEL S69608). REUSE EXISTING NON-FAUCET COMPONENTS SUCH AS WATER SUPPLY STOP VALVES, ETC. PROVIDE ALL NEW WATER SUPPLY TUBING AND NEW ADA PIPE INSULATION FOR P-TRAP, DRAINAGE PIPING, AND WATER PIPING. PROVIDE NEW SYMMONS MODEL 8210CK THERMOSTATIC MIXING VALVE. THE NUMBER OF FAUCETS TO VERIFY IS IDENTIFIED ON PLANS WITH CIRCLE TAG.
2. PORTIONS OF EXISTING PIPING ARE ORIGINAL AND ADJACENT PIPING HAS FAILED IN THE PAST. DEMOLISH AND REPLACE PIPING, FITTINGS, ETC. SEE PHOTOS ON THIS SHEET.




KEYED PLUMBING SHEET NOTES

1. VERIFY LAVATORY FAUCET IS OLDER OBSOLETE SYMMONS FAUCET MODEL. WHERE OLDER OBSOLETE SYMMONS FAUCET MODEL IS PRESENT, REPLACE THE SYMMONS FAUCET WITH NEW REPLACEMENT SYMMONS FAUCET MODEL (SYMMONS MODEL S6606). REUSE EXISTING NON-FAUCET COMPONENTS SUCH AS WATER SUPPLY STOP VALVES, ETC. PROVIDE ALL NEW WATER SUPPLY TUBING AND NEW ADA PIPE INSULATION FOR P-TRAP, DRAINAGE PIPING, AND WATER PIPING. PROVIDE NEW SYMMONS MODEL 82100K THERMOSTATIC MIXING VALVE. THE NUMBER OF FAUCETS TO VERIFY IS IDENTIFIED ON PLANS WITH CIRCLE TAG.
2. REPLACE TANK #1 OF TWO TANKS. OTHER TANK SHALL STAY OPERATIONAL DURING REPLACEMENT OF THIS TANK VIA EXISTING ISOLATION VALVES.
3. REPLACE TANK #2 OF TWO TANKS. OTHER TANK SHALL STAY OPERATIONAL DURING REPLACEMENT OF THIS TANK VIA EXISTING ISOLATION VALVES.
4. PROVIDE FULL DEMOLITION OF EXISTING TANK WITH EGRESS OUT OF THE BUILDING. PROVIDE FULL INSTALLATION OF NEW TANK WITH INGRESS INTO THE BUILDING.



1 PLUMBING PLAN - SERVICE LEVEL - SECTION 3 ENLARGED
SCALE: 1/8\"/>

KEY PLAN:

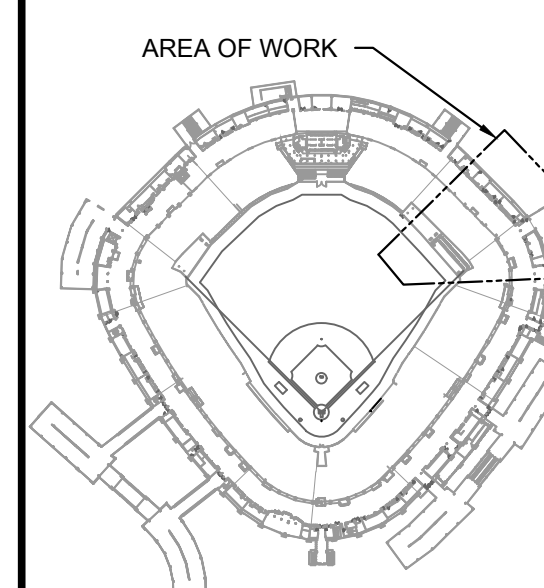

ISSUE/REVISION:

REV.	DATE	DESCRIPTION
1	11/14/25	ISSUE FOR BID

PROJECT:
GUARANTEED RATE FIELD -
WASTE/VENT PIPING FY2026

333 W 35TH STREET,
CHICAGO, ILLINOIS 60616

DRAWING TITLE:
PLUMBING PLAN - SERVICE
LEVEL - SECTION 3

DESIGNED BY: CF
CHECKED BY: MS
PROJECT NO: 25081
SCALE: 1/8\"/>

SHEET NO.


P1.S03



KEYED PLUMBING SHEET NOTES

1. VERIFY LAVATORY FAUCET IS OLDER OBSOLETE SYMMONS FAUCET MODEL. WHERE OLDER OBSOLETE SYMMONS FAUCET MODEL IS PRESENT, REPLACE THE SYMMONS FAUCET WITH NEW REPLACEMENT SYMMONS FAUCET MODEL (SYMMONS MODEL 566666). REUSE EXISTING NON-FAUCET COMPONENTS SUCH AS WATER SUPPLY STOP VALVES, ETC. PROVIDE ALL NEW WATER SUPPLY TUBING AND NEW ADA PIPE INSULATION FOR P-TRAP, DRAINAGE PIPING, AND WATER PIPING. PROVIDE NEW SYMMONS MODEL 8210CK THERMOSTATIC MIXING VALVE. THE NUMBER OF FAUCETS TO VERIFY IS IDENTIFIED ON PLANS WITH CIRCLE TAG.

1 PLUMBING PLAN - SERVICE LEVEL - SECTION 4 ENLARGED

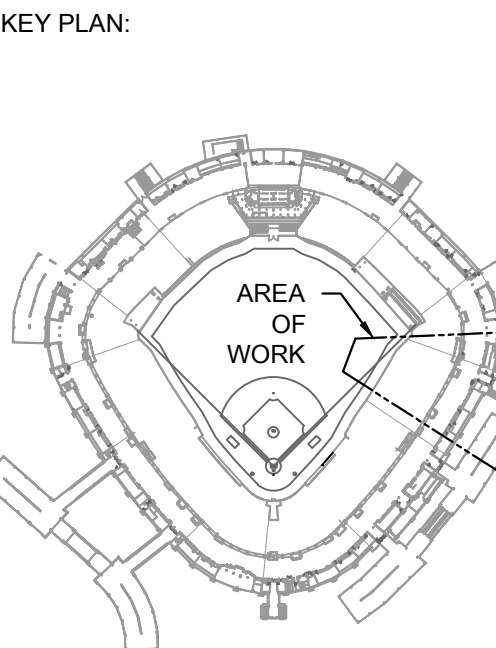

ISSUE/REVISION:		
REV.	DATE	DESCRIPTION
11/14/25		ISSUE FOR BID


PROJECT:
GUARANTEED RATE FIELD -
WASTE/VENT PIPING FY2026

333 W 35TH STREET,
CHICAGO, ILLINOIS 60616

DRAWING TITLE:
PLUMBING PLAN - SERVICE
LEVEL - SECTION 4

DESIGNED BY: CF
CHECKED BY: MS
PROJECT NO: 25081
SCALE: 1/8" = 1'-0"

SHEET NO.

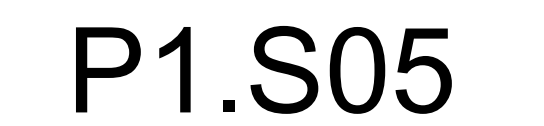




KEYED PLUMBING SHEET NOTES

1. VERIFY LAVATORY FAUCET IS OLDER OBSOLETE SYMMONS FAUCET MODEL. WHERE OLDER OBSOLETE SYMMONS FAUCET MODEL IS PRESENT, REPLACE THE SYMMONS FAUCET WITH NEW REPLACEMENT SYMMONS FAUCET MODEL (SYMMONS MODEL S666B). REUSE EXISTING NON-FAUCET COMPONENTS SUCH AS WATER SUPPLY STOP VALVES, ETC. PROVIDE ALL NEW WATER SUPPLY TUBING AND NEW ADA PIPE INSULATION FOR P-TRAP, DRAINAGE PIPING, AND WATER PIPING. PROVIDE NEW SYMMONS MODEL 82000 THERMOSTATIC MIXING VALVE. THE NUMBER OF FAUCETS TO VERIFY IS IDENTIFIED ON PLANS WITH CIRCLE TAG.
2. PROVIDE NEW ARW WATTS FRPP BLUELINE RIONFUSE OF (ELECTROFUSION) PIPING AND FITTINGS TO REPLACE EXISTING PORTIONS OF BEER STAND DRAINAGE PIPING. PROVIDE ADDITIONAL HANGERS AND SUPPORTS AS NECESSARY FOR THE DIFFERENT MATERIAL INSTALLED.
3. PROVIDE NEW ARW WATTS FRPP BLUELINE RIONFUSE OF (ELECTROFUSION) PIPING AND FITTINGS TO REPLACE EXISTING PORTIONS OF BEER STAND VENT PIPING. PROVIDE ADDITIONAL HANGERS AND SUPPORTS AS NECESSARY FOR THE DIFFERENT MATERIAL INSTALLED.

KEY PLAN:

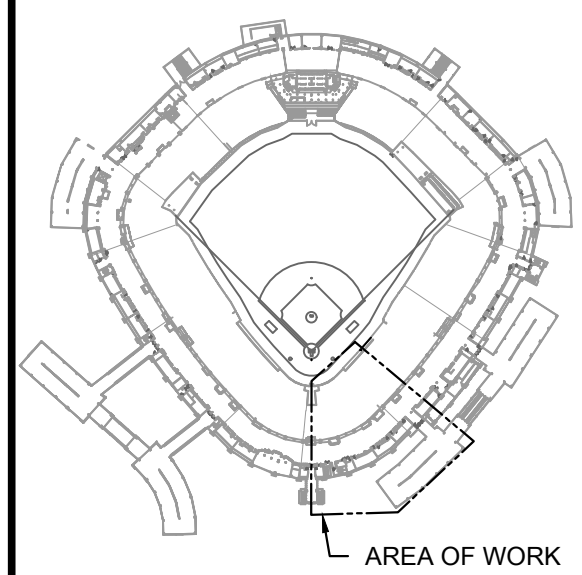

ISSUE/REVISION:

REV.	DATE	DESCRIPTION
11/14/25		ISSUE FOR BID

PROJECT:
GUARANTEED RATE FIELD -
WASTE/VENT PIPING FY2026

333 W 35TH STREET,
CHICAGO, ILLINOIS 60616

DRAWING TITLE:
PLUMBING PLAN - SERVICE
LEVEL - SECTION 6

DESIGNED BY: CF
CHECKED BY: MS
PROJECT NO.: 25081
SCALE: 1/8" = 1'-0"

SHEET NO.

P1.S06

-



SCALE: NO SCALE

SCALE: NO SCALE



①

SCALE: 1/8" = 1'-0"



A diagram of a baseball field showing the layout of the bases and pitcher's mound. The diagram is a top-down view of the diamond, with the pitcher's mound at the center. The bases are labeled: First Base, Second Base, Third Base, and Home. The diagram shows the paths of the bases and the pitcher's mound.

E/REVISION:

DATE	DESCRIPTION
------	-------------

ECT:
 GUARANTEED RATE FIELD -
 WASTE/VENT PIPING FY2026

35TH STREET,
CHICAGO, ILLINOIS 60616

CLIMBING PLAN - SERVICE
LEVEL - SECTION 7

KED BY: MS

E: $1/8" = 1'-0"$

P1.507



#

- [illegible]



UE/REVISION:

[illegible]

PROJECT:
GUARANTEED RATE FIELD -
WASTE/WENT PIPING FY2026

W 35TH STREET,
CHICAGO, ILLINOIS 60616

DRAWING TITLE:
PLUMBING PLAN - SERVICE
LEVEL - SECTION 8

SIGNED BY: CF


RECKED BY: MS

PROJECT NO:	25081
-------------	-------

SCALE:	1/8" = 1'-0"
--------	--------------

SHEET NO. _____

P1.S08

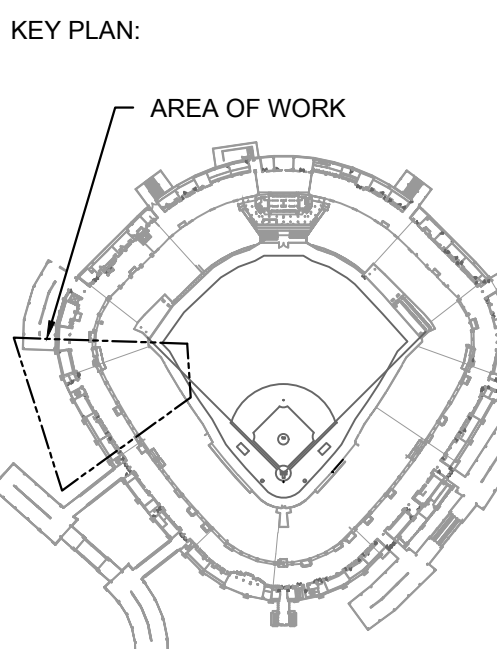[illegible]

PROJECT:
GUARANTEED RATE FIELD -
WASTE/VENT PIPING FY2026


333 W 35TH STREET,
CHICAGO, ILLINOIS 60616

DRAWING TITLE:

PLUMBING PLAN - SERVICE
LEVEL - SECTION 9

DESIGNED BY:	CF
CHECKED BY:	MS
PROJECT NO:	25081
SCALE:	1/8" = 1'-0"
SHEET NO.	

P1.S09

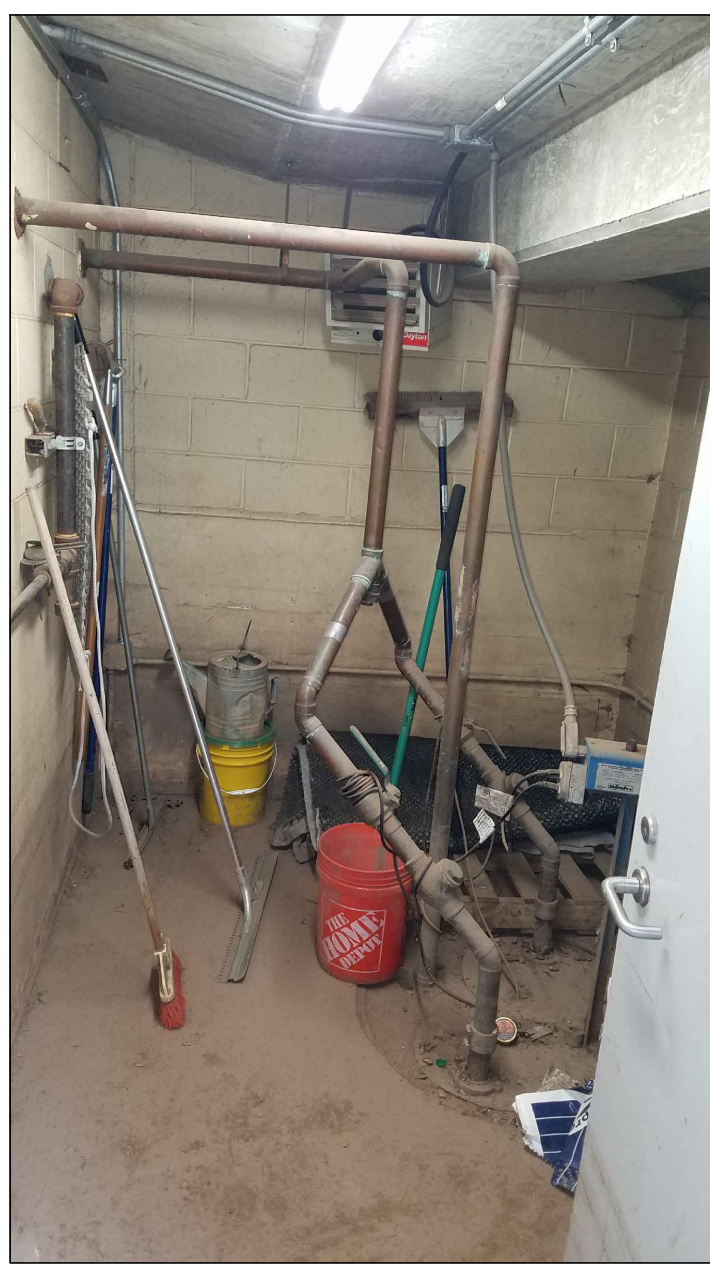


2 STORAGE 1.51.1 - SUMP PUMP
SCALE: NO SCALE




3 STORAGE 1.51.1 - SUMP PUMP
SCALE: NO SCALE



4 STORAGE 1.51.1 - SUMP PUMP
SCALE: NO SCALE

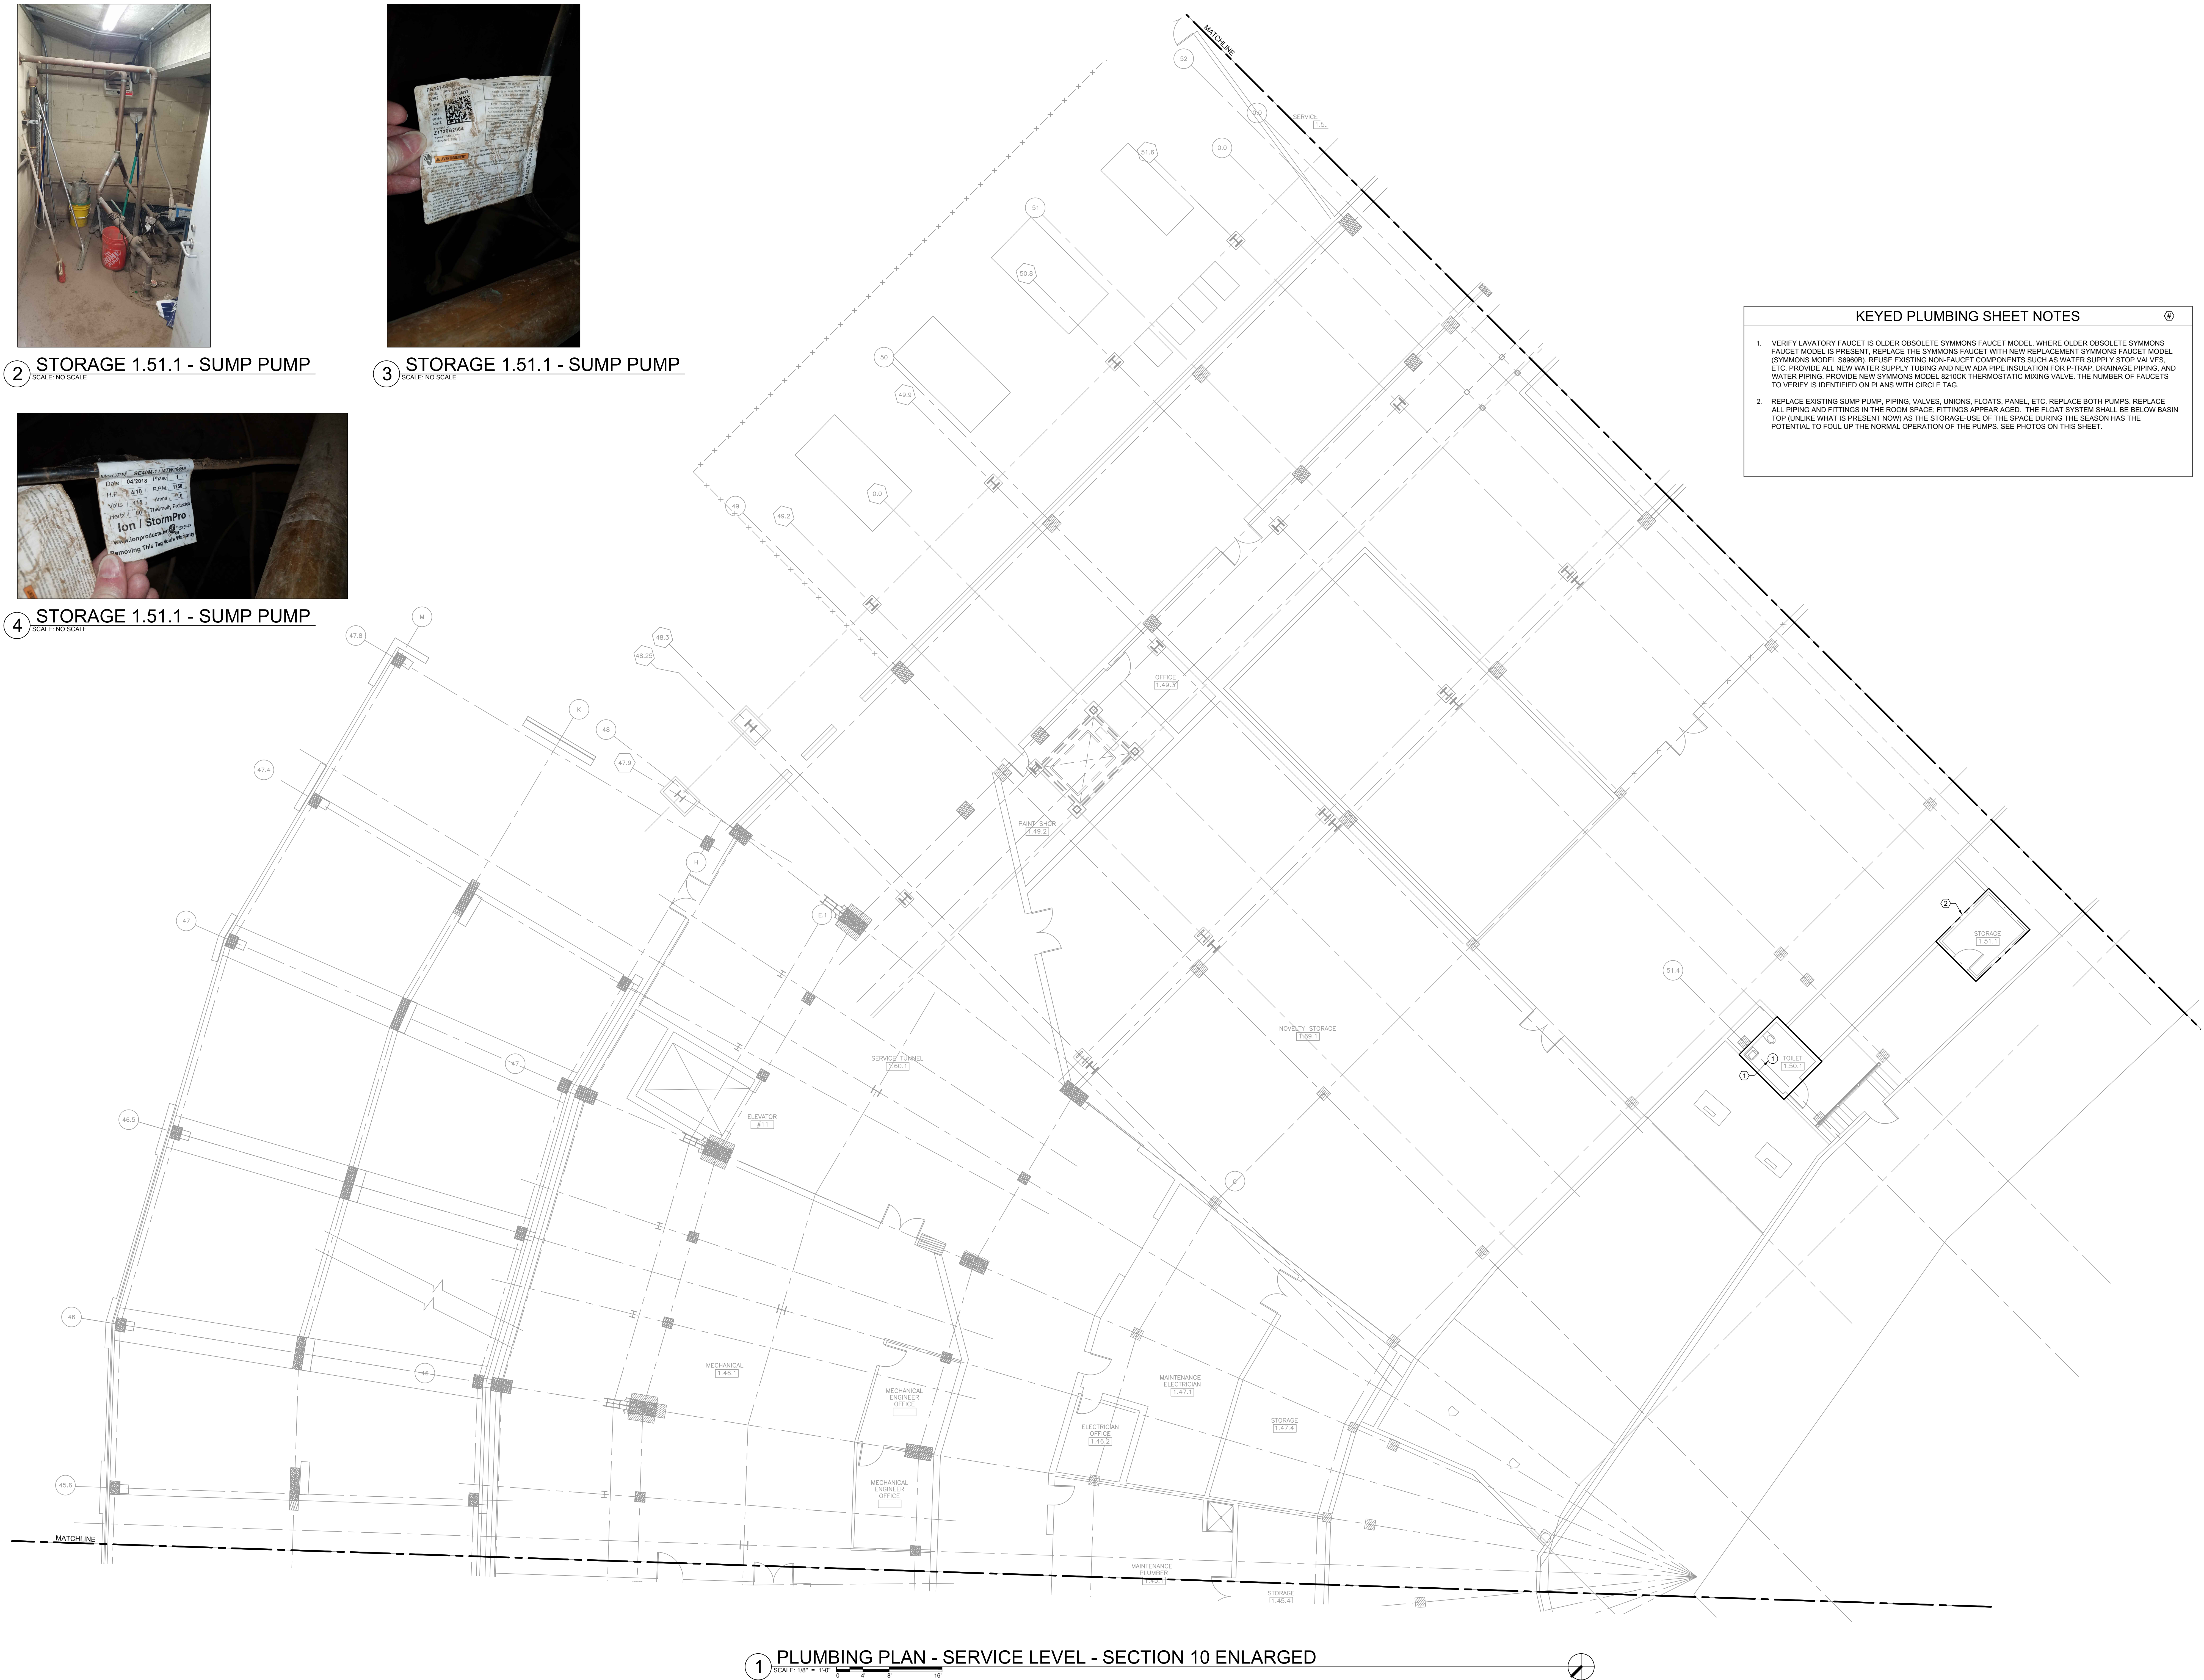

- KEYED PLUMBING SHEET NOTES
1. VERIFY LAVATORY FAUCET IS OLDER OBSOLETE SYMMONS FAUCET MODEL. WHERE OLDER OBSOLETE SYMMONS FAUCET MODEL IS PRESENT, REPLACE THE SYMMONS FAUCET WITH NEW REPLACEMENT SYMMONS FAUCET MODEL (SYMMONS MODEL S8960B). REUSE EXISTING NON-FAUCET COMPONENTS SUCH AS WATER SUPPLY STOP VALVES, ETC. PROVIDE ALL NEW WATER SUPPLY TUBING AND NEW ADA PIPE INSULATION FOR P-TRAP, DRAINAGE PIPING, AND WATER PIPING. PROVIDE NEW SYMMONS MODEL 8210CK THERMOSTATIC MIXING VALVE. THE NUMBER OF FAUCETS TO VERIFY IS IDENTIFIED ON PLANS WITH CIRCLE TAG.
 2. REPLACE EXISTING SUMP PUMP, PIPING, VALVES, UNIONS, FLOATS, PANEL, ETC. REPLACE BOTH PUMPS. REPLACE ALL PIPING AND FITTINGS IN THE ROOM SPACE. FITTINGS APPEAR AGED. THE FLOAT SYSTEM SHALL BE BELOW BASIN TOP UNLIKE WHAT IS PRESENT NOW! AS THE STORAGE-USE OF THE SPACE DURING THE SEASON HAS THE POTENTIAL TO FOUL UP THE NORMAL OPERATION OF THE PUMPS. SEE PHOTOS ON THIS SHEET.

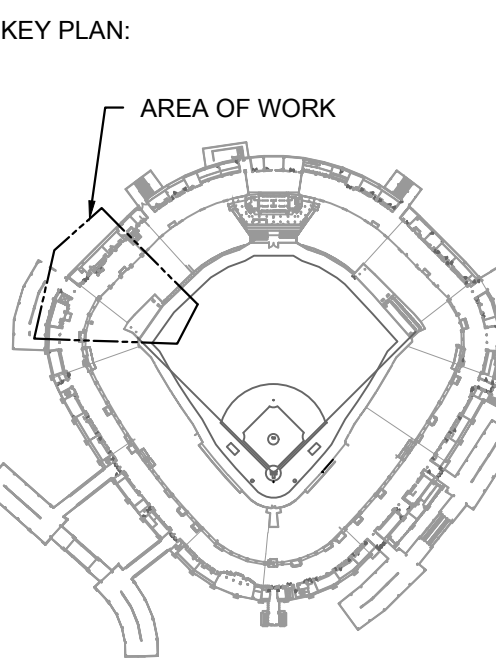

ISSUE/REVISION:		
REV.	DATE	DESCRIPTION
11/14/25		ISSUE FOR BID

PROJECT:
GUARANTEED RATE FIELD -
WASTE/VENT PIPING FY2026



333 W 35TH STREET,
CHICAGO, ILLINOIS 60616

DRAWING TITLE:
PLUMBING PLAN - SERVICE
LEVEL - SECTION 10

DESIGNED BY: CF
CHECKED BY: MS
PROJECT NO: 25081
SCALE: 1/8" = 1'-0"

SHEET NO.

P1.S10

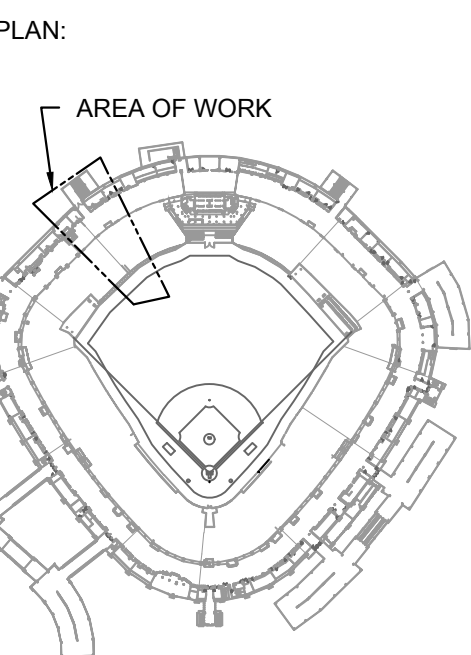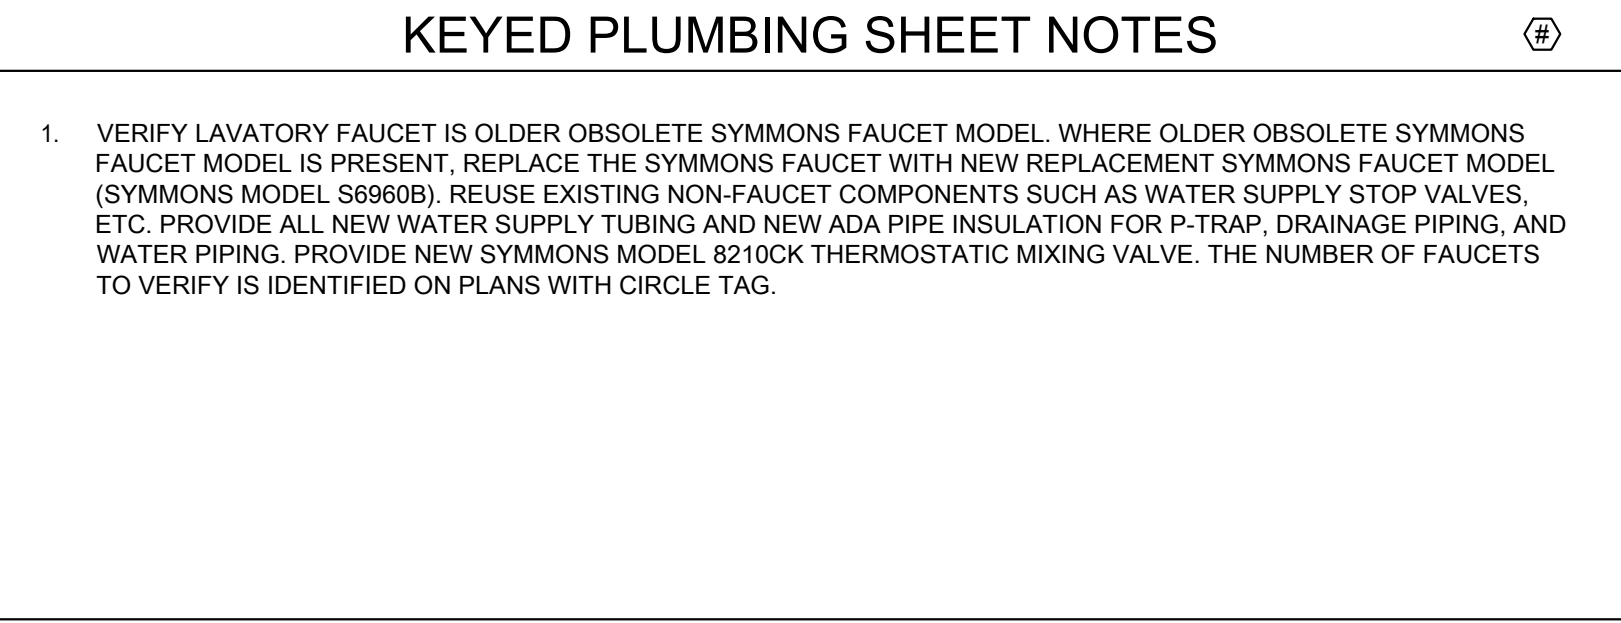[illegible]


PROJECT:
GUARANTEED RATE FIELD -
STEAM/VENT PIPING FY2026
1550 W. 35TH STREET,
CHICAGO, ILLINOIS 60616

CLIMBING PLAN - SERVICE LEVEL - SECTION 11

DESIGNED BY:	CF
DRAWN BY:	MS
PROJECT NO:	25081
SCALE:	1/8" = 1'-0"

T NO.


P1.S11

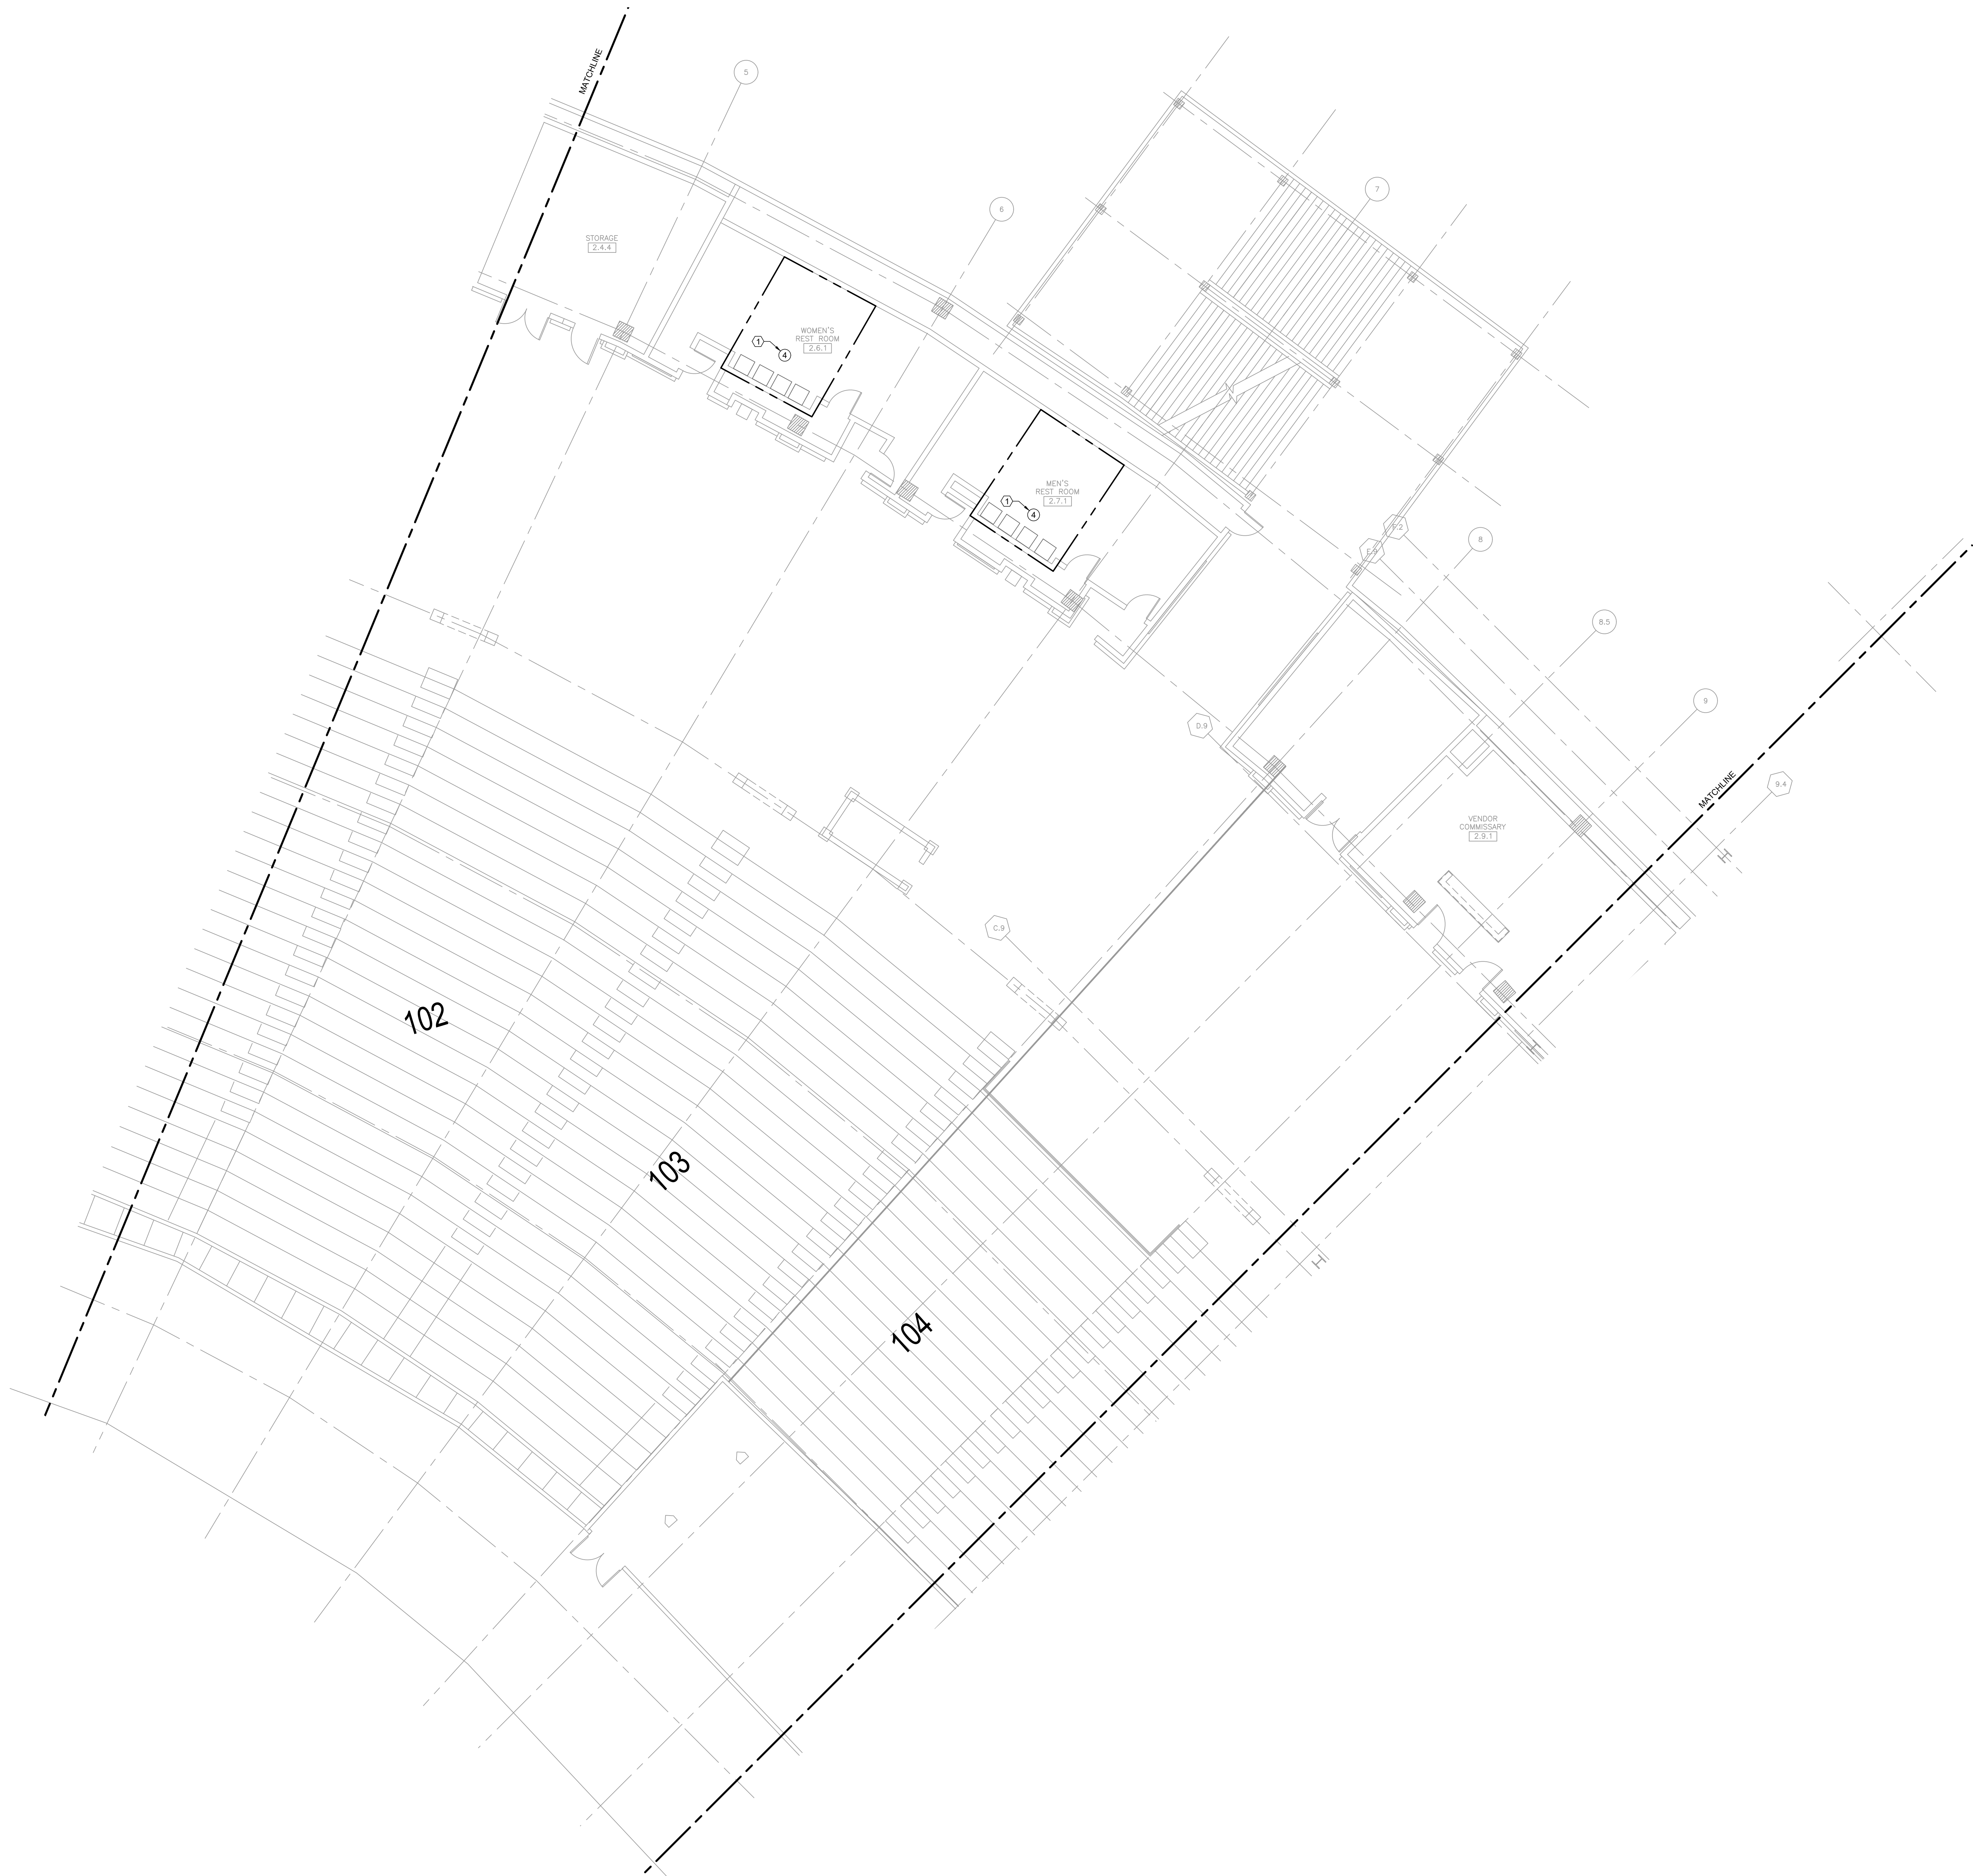

KEYED PLUMBING SHEET NOTES

1. VERIFY LAVATORY FAUCET IS OLDER OBSOLETE SYMMONS FAUCET MODEL. WHERE OLDER OBSOLETE SYMMONS FAUCET MODEL IS PRESENT, REPLACE THE SYMMONS FAUCET WITH NEW REPLACEMENT SYMMONS FAUCET MODEL (SYMMONS MODEL S69608). REUSE EXISTING NON-FAUCET COMPONENTS SUCH AS WATER SUPPLY STOP VALVES, ETC. PROVIDE ALL NEW WATER SUPPLY TUBING AND NEW ADA PIPE INSULATION FOR P-TRAP, DRAINAGE PIPING, AND WATER PIPING. PROVIDE NEW SYMMONS MODEL 8210CK THERMOSTATIC MIXING VALVE. THE NUMBER OF FAUCETS TO VERIFY IS IDENTIFIED ON PLANS WITH CIRCLE TAG.

1 PLUMBING PLAN - 100 LEVEL - SECTION 2 ENLARGED
SCALE: 1/8" = 1'-0"

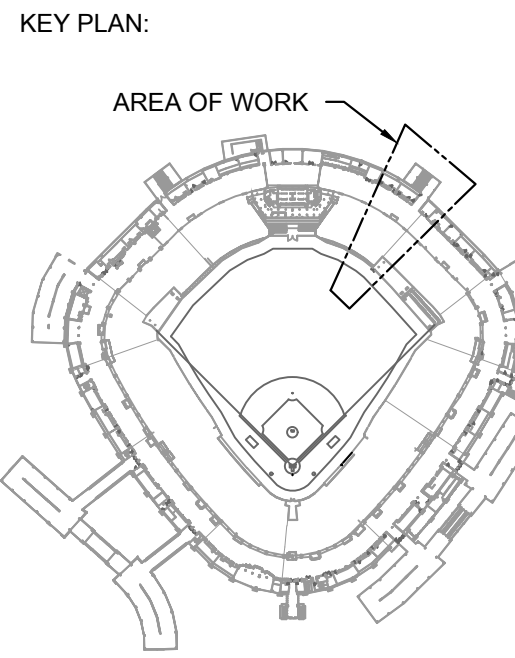

ISSUE/REVISION:		
REV.	DATE	DESCRIPTION
11/14/25		ISSUE FOR BID

PROJECT:
GUARANTEED RATE FIELD -
WASTE/VENT PIPING FY2026

333 W 35TH STREET,
CHICAGO, ILLINOIS 60616

DRAWING TITLE:
PLUMBING PLAN - LEVEL 100 -
SECTION 2


DESIGNED BY: CF
CHECKED BY: MS
PROJECT NO: 25081
SCALE: 1/8" = 1'-0"

SHEET NO.
P1.102

KEYED PLUMBING SHEET NOTES

1.

VERIFY LAVATORY FAUCET IS OLDER OBSOLETE SYMMONS FAUCET MODEL. WHERE OLDER OBSOLETE SYMMONS FAUCET MODEL IS PRESENT, REPLACE THE SYMMONS FAUCET WITH NEW REPLACEMENT SYMMONS FAUCET MODEL (SYMMONS MODEL S6606B). REUSE EXISTING NON-FAUCET COMPONENTS SUCH AS WATER SUPPLY STOP VALVES, ETC. PROVIDE ALL NEW WATER SUPPLY TUBING AND NEW ADA PIPE INSULATION FOR P-TRAP, DRAINAGE PIPING, AND WATER PIPING. PROVIDE NEW SYMMONS MODEL 82100K THERMOSTATIC MIXING VALVE. THE NUMBER OF FAUCETS TO VERIFY IS IDENTIFIED ON PLANS WITH CIRCLE TAG.

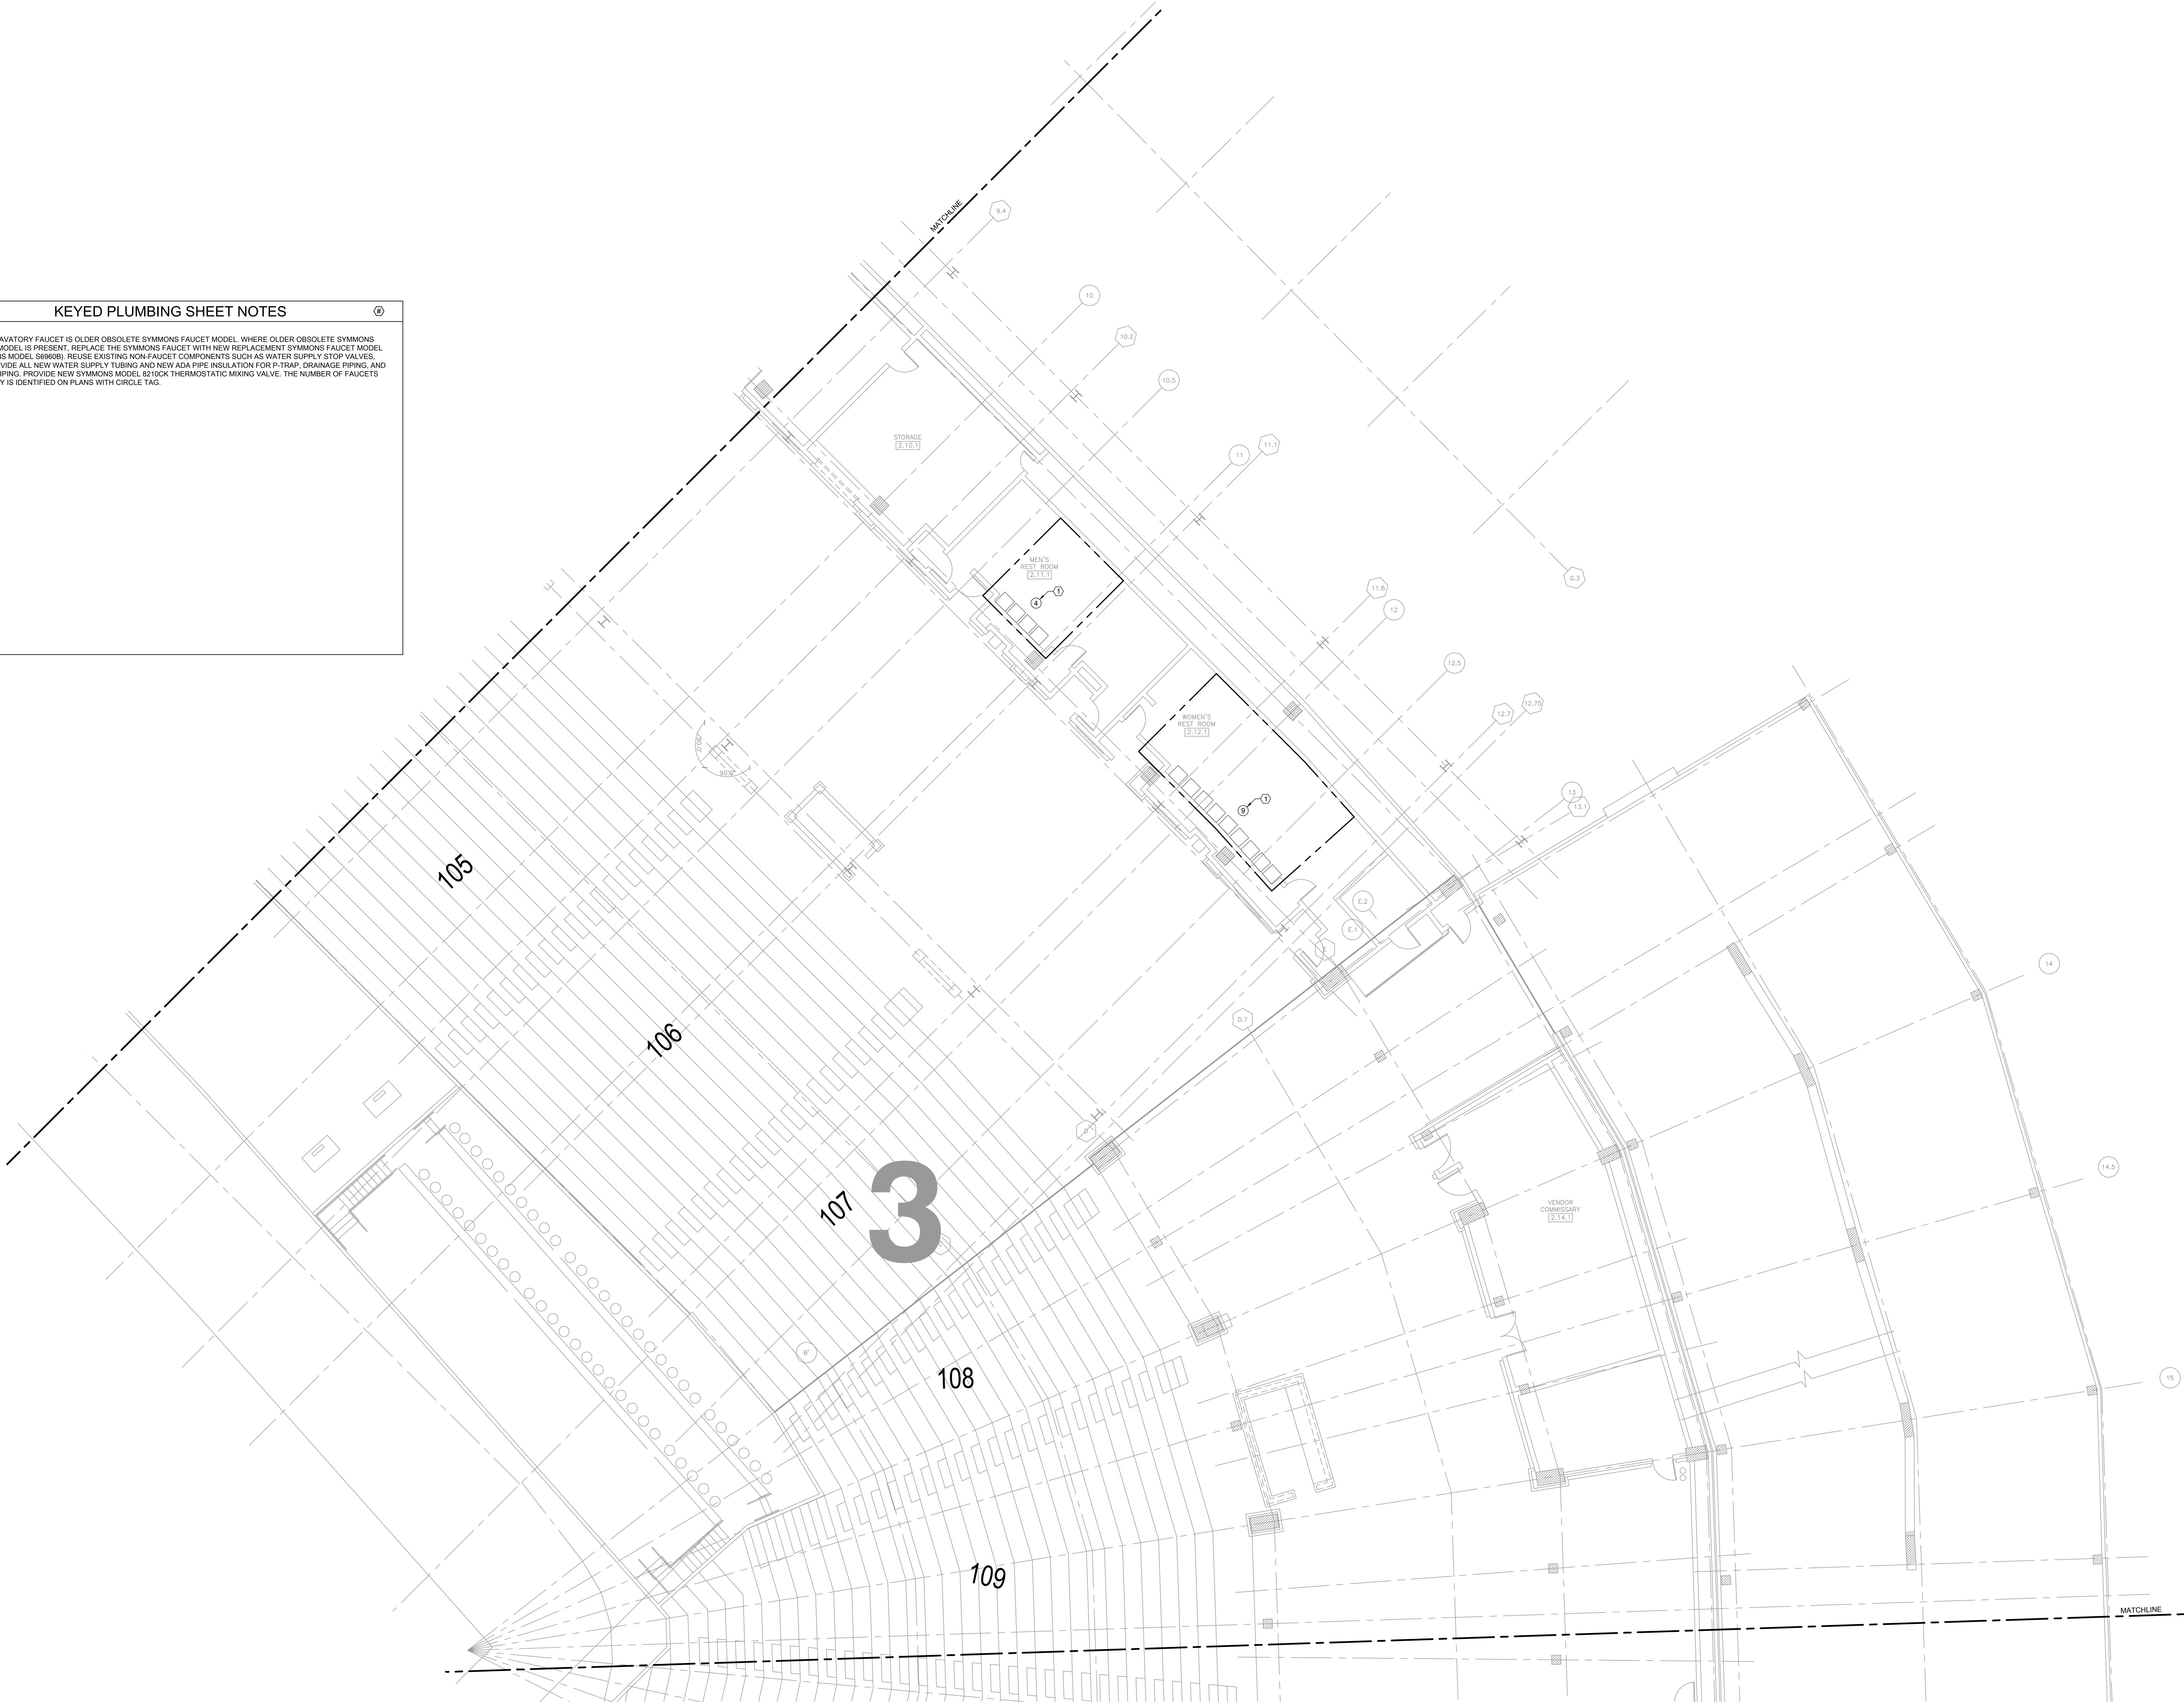


1

PLUMBING PLAN - 100 LEVEL - SECTION 3 ENLARGED

SCALE: 1/8" = 1'-0"

0 2 4 8 16

North Arrow

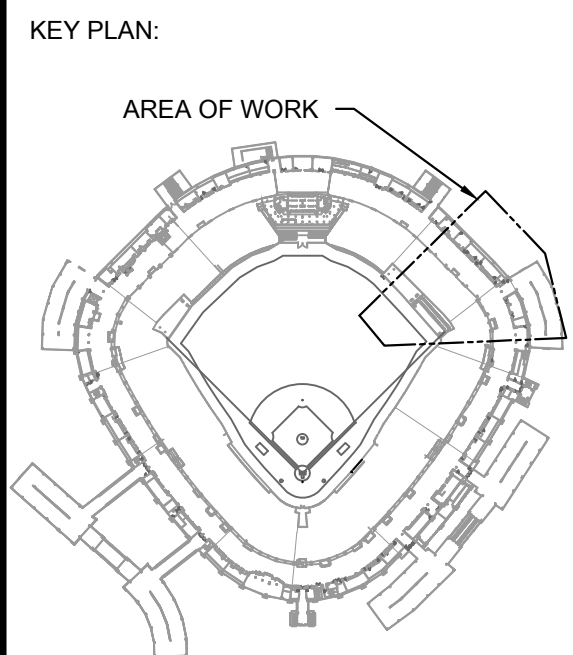

ISSUE/REVISION:		
REV.	DATE	DESCRIPTION
1	11/14/25	ISSUE FOR BID

PROJECT:
GUARANTEED RATE FIELD -
WASTE/VENT PIPING FY2026

333 W 35TH STREET,
CHICAGO, ILLINOIS 60616

DRAWING TITLE:
PLUMBING PLAN - LEVEL 100 -
SECTION 3

DESIGNED BY: CF
CHECKED BY: MS
PROJECT NO: 25081
SCALE: 1/8" = 1'-0"

SHEET NO.
P1.103




KEYED PLUMBING SHEET NOTES

1. VERIFY LAVATORY FAUCET IS OLDER OBSOLETE SYMMONS FAUCET MODEL WHERE OLDER OBSOLETE SYMMONS FAUCET MODEL IS PRESENT. REPLACE THE SYMMONS FAUCET WITH NEW REPLACEMENT SYMMONS FAUCET MODEL (SYMMONS MODEL 566606). REUSE EXISTING NON-FAUCET COMPONENTS SUCH AS WATER SUPPLY STOP VALVES, ETC. PROVIDE ALL NEW WATER SUPPLY TUBING AND NEW ADA PIPE INSULATION FOR P-TRAP, DRAINAGE PIPING, AND WATER PIPING. PROVIDE NEW SYMMONS MODEL 8210CK THERMOSTATIC MIXING VALVE. THE NUMBER OF FAUCETS TO VERIFY IS IDENTIFIED ON PLANS WITH CIRCLE TAG.

1 PLUMBING PLAN - 100 LEVEL - SECTION 4 ENLARGED

KEY PLAN:

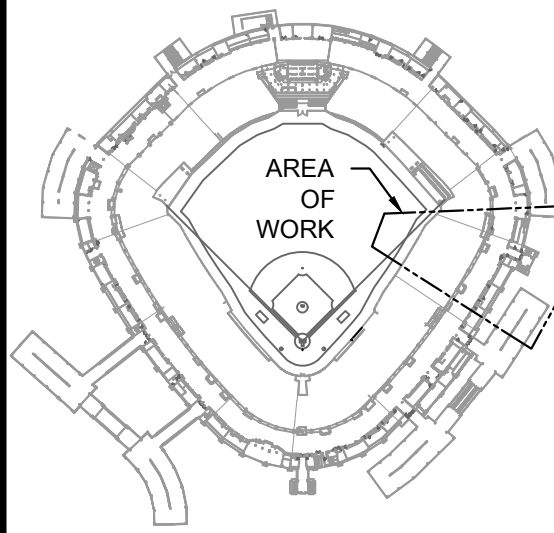

ISSUE/REVISION:

REV.	DATE	DESCRIPTION
11/14/25		ISSUE FOR BID

PROJECT:
GUARANTEED RATE FIELD -
WASTE/VENT PIPING FY2026

333 W 35TH STREET,
CHICAGO, ILLINOIS 60616

DRAWING TITLE:
PLUMBING PLAN - LEVEL 100 -
SECTION 4


DESIGNED BY: CF
CHECKED BY: MS
PROJECT NO: 25081
SCALE: 1/8" = 1'-0"

SHEET NO.

KEYED PLUMBING SHEET NOTES

1. VERIFY LAVATORY FAUCET IS OLDER OBSOLETE SYMMONS FAUCET MODEL. WHERE OLDER OBSOLETE SYMMONS FAUCET MODEL IS PRESENT, REPLACE THE SYMMONS FAUCET WITH NEW REPLACEMENT SYMMONS FAUCET MODEL (SYMMONS MODEL 3666B). REUSE EXISTING NON-FAUCET COMPONENTS SUCH AS WATER SUPPLY STOP VALVES, ETC. PROVIDE ALL NEW WATER SUPPLY TUBING AND NEW ADA PIPE INSULATION FOR P-TRAP, DRAINAGE PIPING, AND WATER PIPING. PROVIDE NEW SYMMONS MODEL 82300K THERMOSTATIC MIXING VALVE. THE NUMBER OF FAUCETS TO VERIFY IS IDENTIFIED ON PLANS WITH CIRCLE TAG.
2. PROVIDE NEW DECK DRAIN TO REPLACE EXISTING FAILING DECK DRAIN; PROVIDE SMITH MODEL 1410 TO REPLACE EXISTING UNIT. PROVIDE NEW ARW WATTS FRPP BLUELINE RIONFUSE OF (ELECTROFUSION) PIPING AND FITTINGS TO REPLACE EXISTING PORTIONS OF BEER STAND DRAINAGE PIPING UP TO NEW DECK DRAIN.
3. PROVIDE NEW ARW WATTS FRPP BLUELINE RIONFUSE OF (ELECTROFUSION) PIPING AND FITTINGS TO REPLACE EXISTING PORTIONS OF BEER STAND VENT PIPING. PROVIDE ADDITIONAL HANGERS AND SUPPORTS AS NECESSARY FOR THE DIFFERENT MATERIAL INSTALLED.

KEY PLAN:

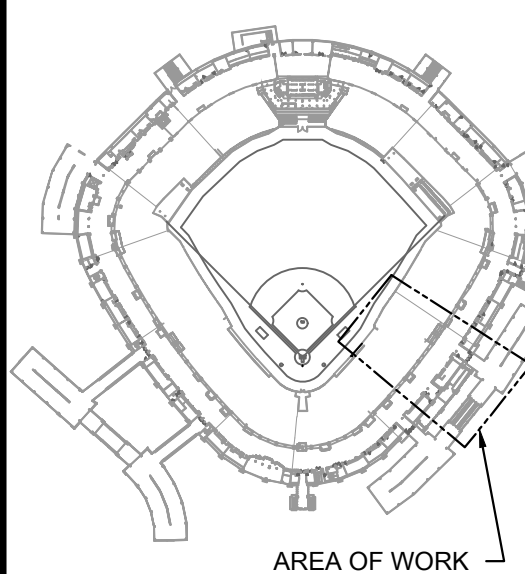

ISSUE/REVISION:

REV.	DATE	DESCRIPTION
1	11/14/25	ISSUE FOR BID

PROJECT:

GUARANTEED RATE FIELD -
WASTE/VENT PIPING FY2026

333 W 35TH STREET,
CHICAGO, ILLINOIS 60616

DRAWING TITLE:

PLUMBING PLAN - LEVEL 100 -
SECTION 5


 
DESIGNED BY: CF
CHECKED BY: MS
PROJECT NO: 25081
SCALE: 1/8" = 1'-0"

SHEET NO.

P1.105

1 PLUMBING PLAN - 100 LEVEL - SECTION 5 ENLARGED


SCALE: 1/8" = 1'-0"

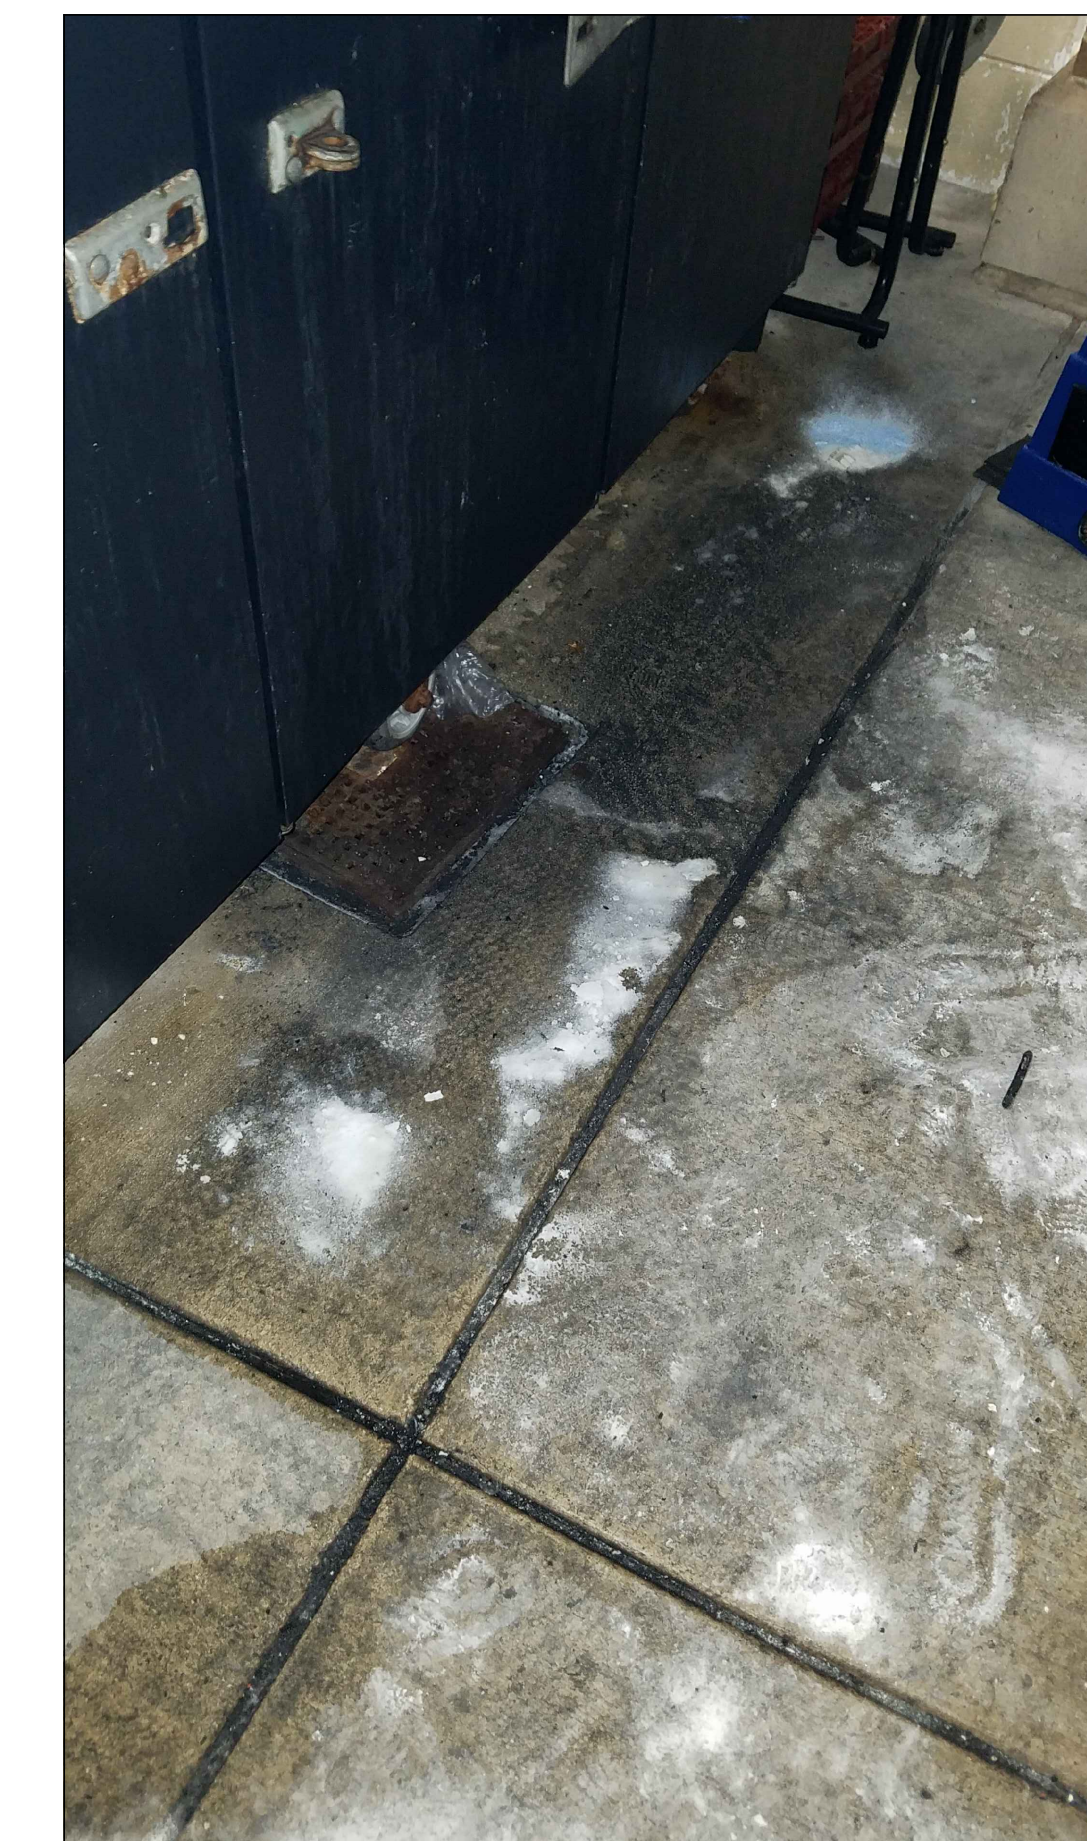

2 BEER STAND - FLOOR DRAIN
SCALE: NO SCALE



1. VERIFY LAVATORY FAUCET IS OLDER OBSOLETE SYMONS FAUCET MODEL. WHERE OLDER OBSOLETE SYMONS FAUCET MODEL IS PRESENT, REPLACE THE SYMONS FAUCET WITH NEW REPLACEMENT SYMONS FAUCET MODEL. SYMONS FAUCET MODEL NUMBER: 800-967-0000. PROVIDE ALL NECESSARY PARTS AND SUPPLIES TO COMPLETE. PROVIDE ALL NEW WATER SUPPLY TUBING AND NEW DRAIN PIPING INCLUDING VALVE FOR "P-TAP". DRAINAGE PIPING, AND SINK DISPOSAL PROVIDED BY OTHER TRADES. PROVIDE A KITCHEN AREA IDENTIFICATION TAG VALUE. NAME OF FAUCETS TO VERIFY IS IDENTIFIED ON PLANS WITH CIRCLE TAG.
- PROVIDE NEW DECK DRAIN TO REPLACE EXISTING FAILING DECK DRAIN. PROVIDE SMITH MODEL 1410 TO REPLACE EXISTING DECK DRAIN. PROVIDE NEW DRAIN MATES TO MATCH EXISTING DRAIN MATES. HANGING TO REPLACE EXISTING PORTS OF BEER STAND DRAINAGE PIPING UP TO NEW DECK DRAIN.
- PROVIDE NEW ARV WATTS FRPP BULKHEAD LINEURFSE OF (ELECTROFUSION PIPING AND FITTINGS TO REPLACE) CONNECTIONS OF OLD BRASS COPPER PIPE. PROVIDE ADDITIONAL MANAGERS AND SUPPORTS AS NEEDED FOR THE DIFFERENT MATERIAL INSTALLED.

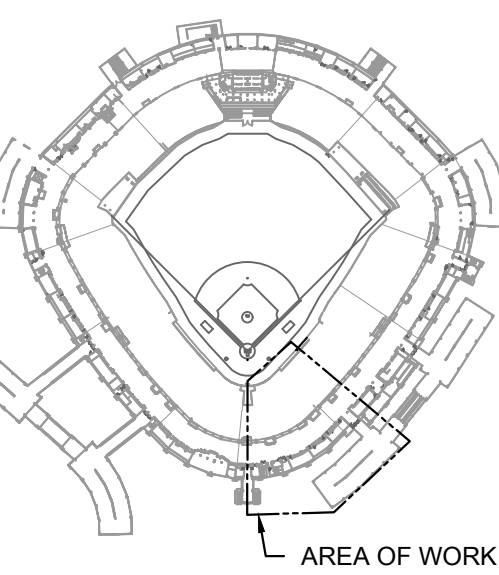

SUE/REVISION:

[illegible]

PROJECT: GUARANTEED RATE FIELD - WASTE/VENT PIPING FY2026

3 W 35TH STREET,
CHICAGO, ILLINOIS 60616

DRAWING TITLE:
PLUMBING PLAN - LEVEL 100 -
SECTION 6

DESIGNED BY:	CF
CHECKED BY:	MS
PROJECT NO:	25081
SCALE:	1/8" = 1'-0"

SHEET NO.

P1.106



- KEYED PLUMBING SHEET NOTES**
1. VERIFY LAVATORY FAUCET IS OLDER OBSOLETE SYMMONS FAUCET MODEL. WHERE OLDER OBSOLETE SYMMONS FAUCET MODEL IS PRESENT, REPLACE THE SYMMONS FAUCET WITH NEW REPLACEMENT SYMMONS FAUCET MODEL (SYMMONS MODEL 5860B). REUSE EXISTING NON-FAUCET COMPONENTS SUCH AS WATER SUPPLY STOP VALVES, ETC. PROVIDE ALL NEW WATER SUPPLY TUBING AND NEW ADA PIPE INSULATION FOR P-TRAP, DRAINAGE PIPING, AND WATER PIPING. PROVIDE NEW SYMMONS MODEL 6210CK THERMOSTATIC MIXING VALVE. THE NUMBER OF FAUCETS TO VERIFY IS IDENTIFIED ON PLANS WITH CIRCLE TAG.
 2. PROVIDE NEW DECK DRAIN TO REPLACE EXISTING FAILING DECK DRAIN. PROVIDE SMITH MODEL 1410 TO REPLACE EXISTING UNIT. PROVIDE NEW ARW WATTS FRPP BLUELINE RIONUSE OF (ELECTROFUSION) PIPING AND FITTINGS TO REPLACE EXISTING PORTIONS OF BEER STAND DRAINAGE PIPING UP TO NEW DECK DRAIN.
 3. PROVIDE NEW ARW WATTS FRPP BLUELINE RIONUSE OF (ELECTROFUSION) PIPING AND FITTINGS TO REPLACE EXISTING PORTIONS OF BEER STAND VENT PIPING. PROVIDE ADDITIONAL HANGERS AND SUPPORTS AS NECESSARY FOR THE DIFFERENT MATERIAL INSTALLED.


 


2 BEER STAND - FLOOR DRAIN

SCALE: NO SCALE

1 PLUMBING PLAN - 100 LEVEL - SECTION 7 ENLARGED

SCALE: 1/8" = 1'-0"

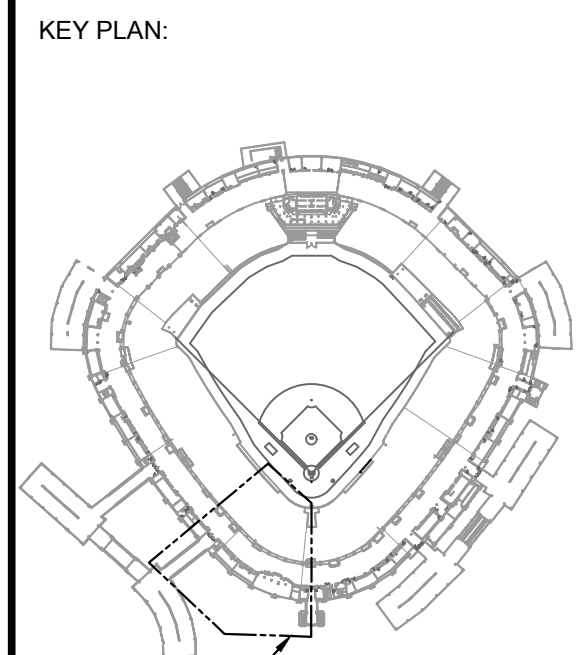

AREA OF WORK

ISSUE/REVISION:		
REV.	DATE	DESCRIPTION
11/14/25		ISSUE FOR BID

PROJECT:
GUARANTEED RATE FIELD -
WASTE/VENT PIPING FY2026

333 W 35TH STREET,
CHICAGO, ILLINOIS 60616

DRAWING TITLE:
PLUMBING PLAN - LEVEL 100 -
SECTION 7

DESIGNED BY: CF
CHECKED BY: MS
PROJECT NO: 25081
SCALE: 1/8" = 1'-0"
SHEET NO.




2 BEER STAND - FLOOR DRAIN
SCALE: NO SCALE



1 PLUMBING PLAN - 100 LEVEL - SECTION 8 ENLARGED
SCALE: 1/8" = 1'-0"

- KEYED PLUMBING SHEET NOTES
1. VERIFY LAVATORY FAUCET IS OLDER OBSOLETE SYMMONS FAUCET MODEL. WHERE OLDER OBSOLETE SYMMONS FAUCET MODEL IS PRESENT, REPLACE THE SYMMONS FAUCET WITH NEW REPLACEMENT SYMMONS FAUCET MODEL (SYMMONS MODEL 569698). REUSE EXISTING NON-FAUCET COMPONENTS SUCH AS WATER SUPPLY STOP VALVES, ETC. PROVIDE ALL NEW WATER SUPPLY TUBING AND NEW ADA PIPE INSULATION FOR P-TRAP, DRAINAGE PIPING, AND WATER PIPING. PROVIDE NEW SYMMONS MODEL 8210CK THERMOSTATIC MIXING VALVE. THE NUMBER OF FAUCETS TO VERIFY IS IDENTIFIED ON PLANS WITH CIRCLE TAG.
 2. PROVIDE NEW DECK DRAIN TO REPLACE EXISTING FAILING DECK DRAIN. PROVIDE SMITH MODEL 1410 TO REPLACE EXISTING UNIT. PROVIDE NEW ARW WATTS FRPP BLUELINE RIONFUSE CF (ELECTROFUSION) PIPING AND FITTINGS TO REPLACE EXISTING PORTIONS OF BEER STAND DRAINAGE PIPING UP TO NEW DECK DRAIN.
 3. PROVIDE NEW ARW WATTS FRPP BLUELINE RIONFUSE CF (ELECTROFUSION) PIPING AND FITTINGS TO REPLACE EXISTING PORTIONS OF BEER STAND VENT PIPING. PROVIDE ADDITIONAL HANGERS AND SUPPORTS AS NECESSARY FOR THE DIFFERENT MATERIAL INSTALLED.

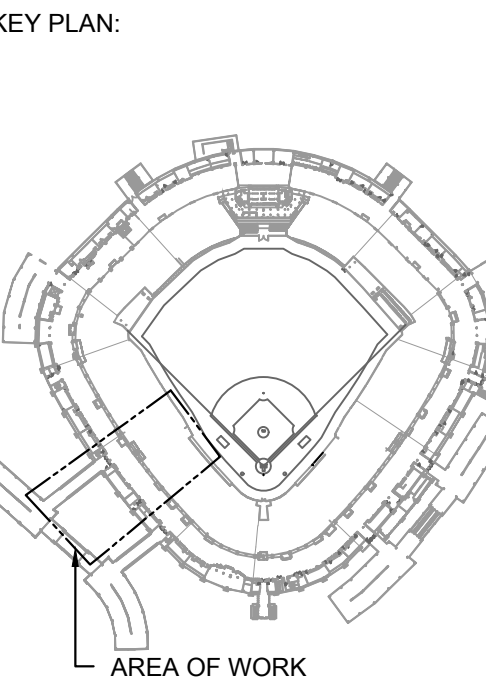

ISSUE/REVISION:		
REV.	DATE	DESCRIPTION
11/14/25		ISSUE FOR BID

PROJECT:
GUARANTEED RATE FIELD -
WASTE/VENT PIPING FY2026

333 W 35TH STREET,
CHICAGO, ILLINOIS 60616

DRAWING TITLE:
PLUMBING PLAN - LEVEL 100 -
SECTION 8

DESIGNED BY: CF
CHECKED BY: MS
PROJECT NO: 25081
SCALE: 1/8" = 1'-0"

SHEET NO.



KEY PLAN:

AREA OF WORK

The key plan shows the overall layout of the stadium, including the pitch, stands, and surrounding areas. A dashed line indicates the 'AREA OF WORK' on the left side of the stadium.

[illegible]

PROJECT: **GUARANTEED RATE FIELD -
WASTE/VENT PIPING FY2026**


**333 W 35TH STREET,
CHICAGO, ILLINOIS 60616**

DRAWING TITLE: **PLUMBING PLAN - LEVEL 100 -
SECTION 9**

DESIGNED BY:	CF
CHECKED BY:	MS
PROJECT NO:	25081
SCALE:	1/8" = 1'-0"
SHEET NO.	

P1.109



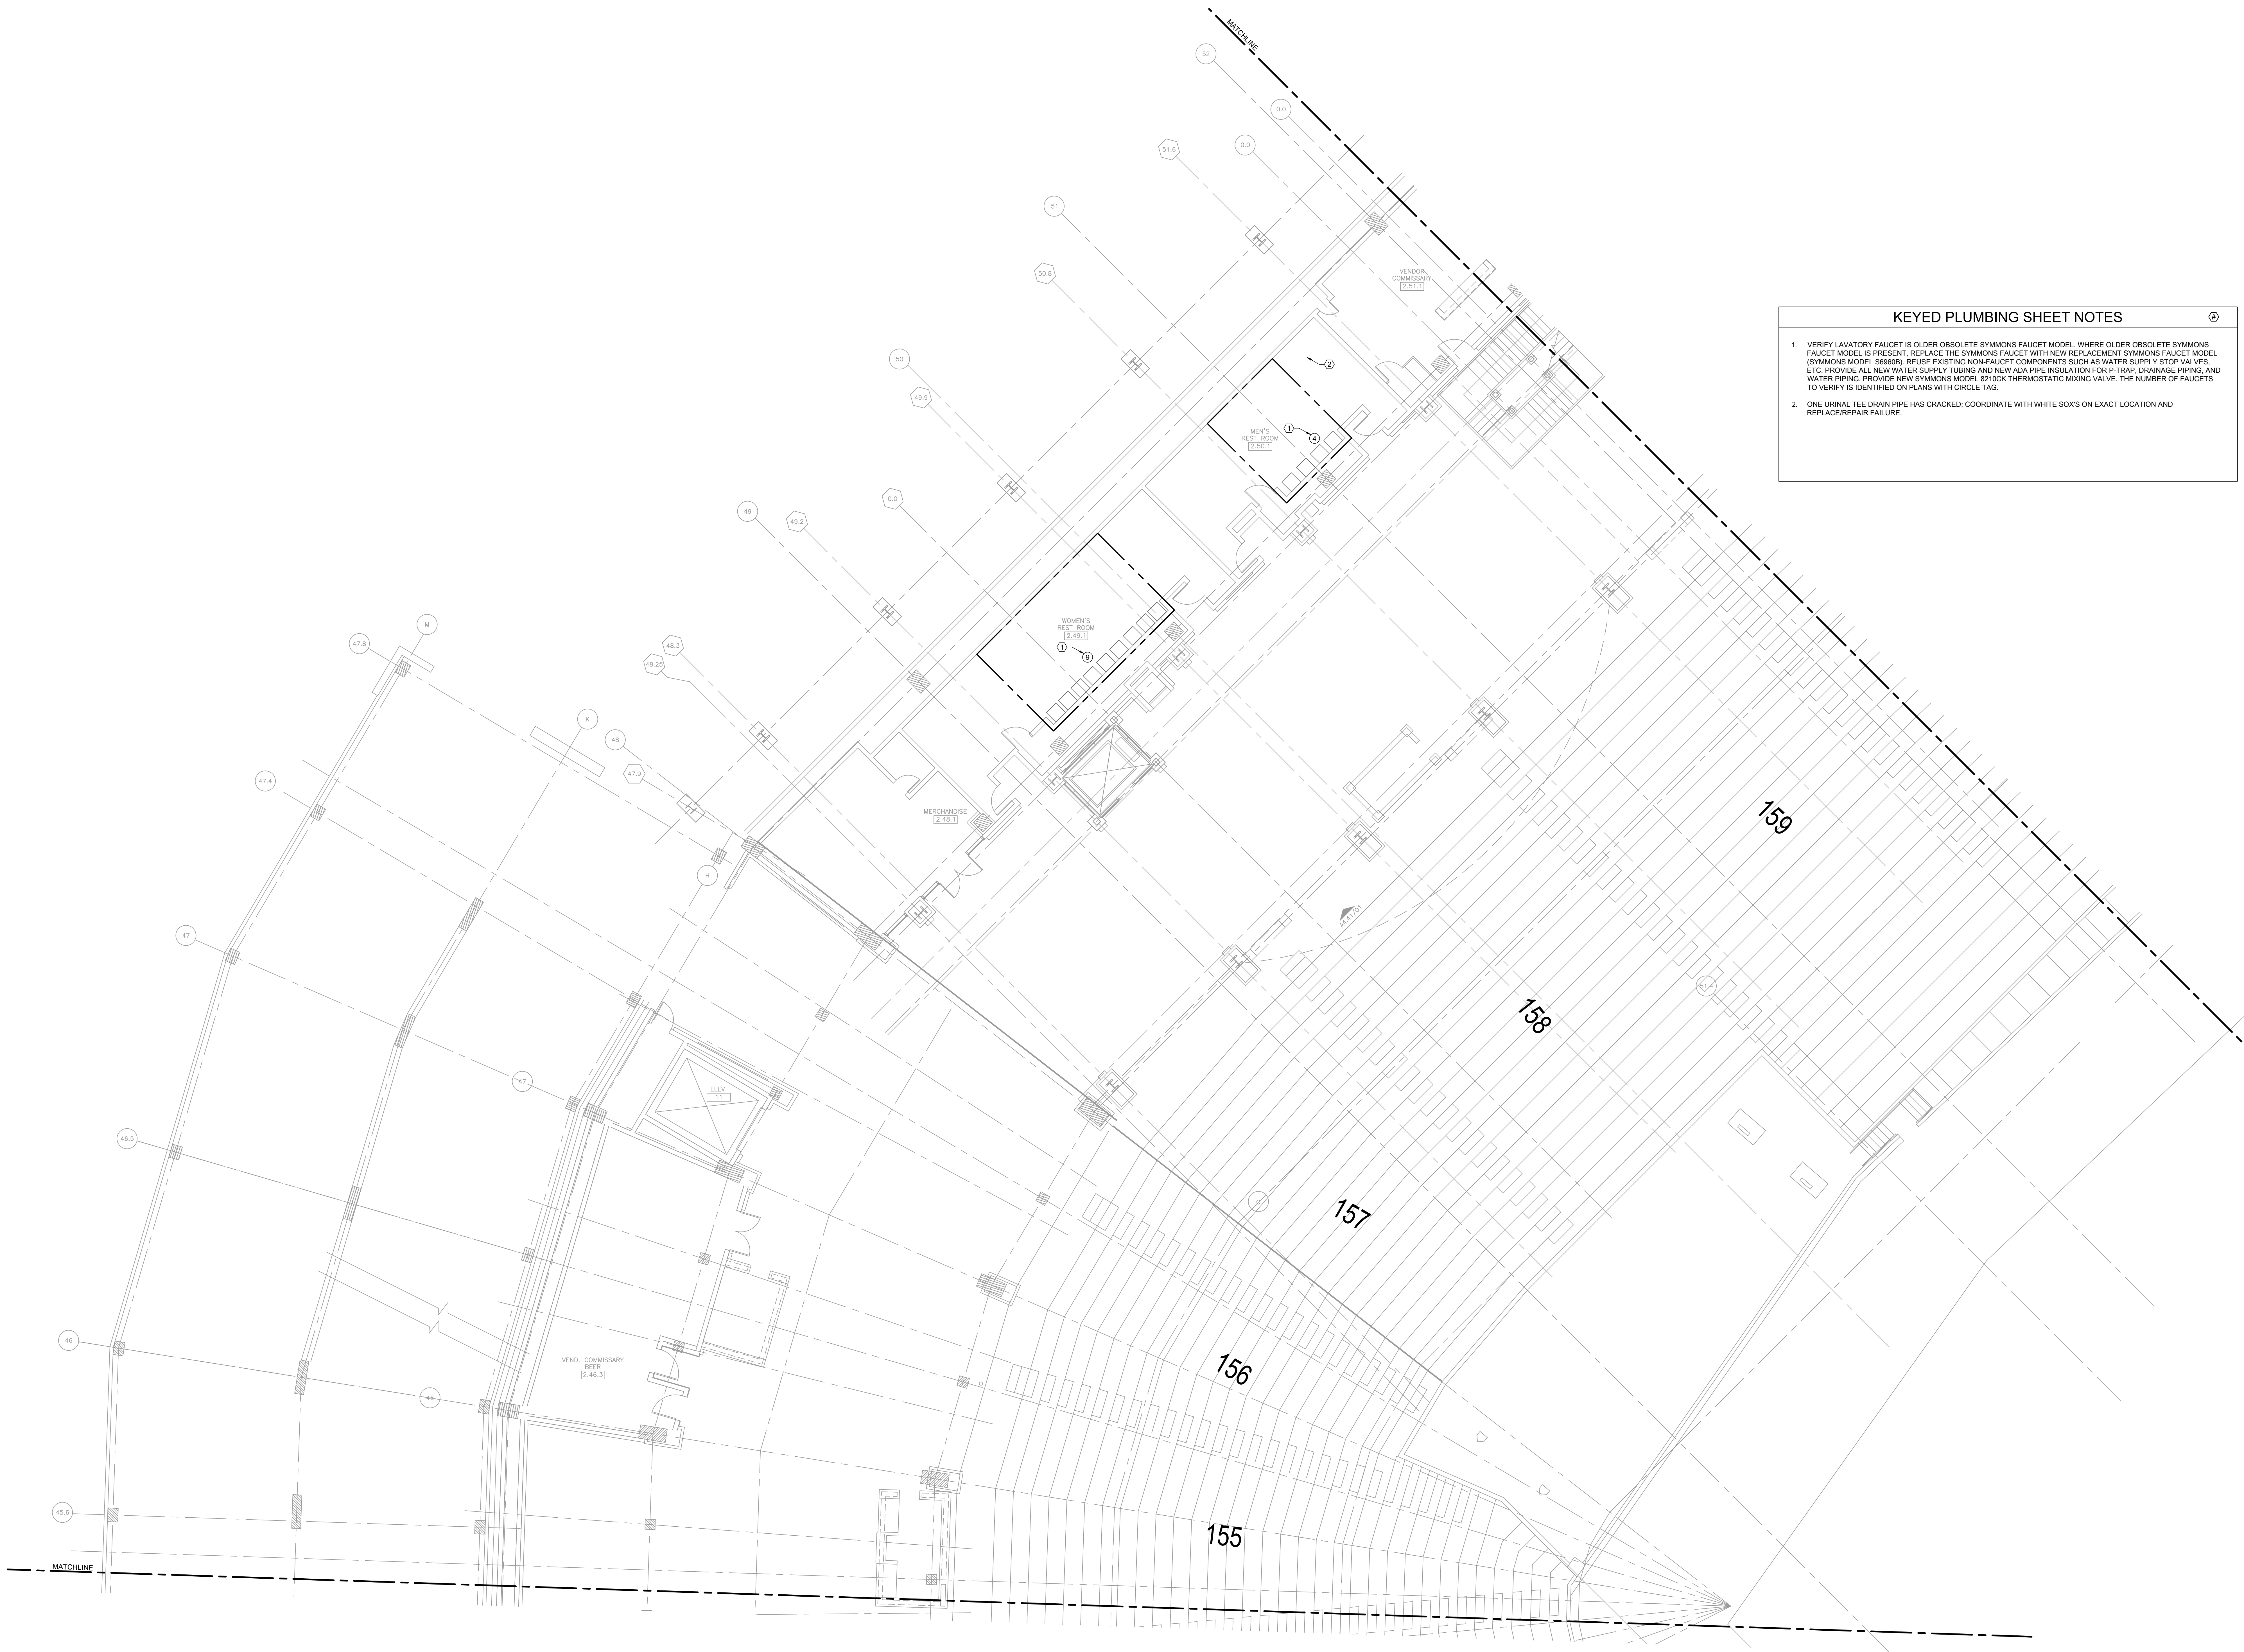

KEYED PLUMBING SHEET NOTES

1.

VERIFY LAVATORY FAUCET IS OLDER OBSOLETE SYMMONS FAUCET MODEL. WHERE OLDER OBSOLETE SYMMONS FAUCET MODEL IS PRESENT, REPLACE THE SYMMONS FAUCET WITH NEW REPLACEMENT SYMMONS FAUCET MODEL (SYMMONS MODEL S8980B). REUSE EXISTING NON-FAUCET COMPONENTS SUCH AS WATER SUPPLY STOP VALVES, ETC. PROVIDE ALL NEW WATER SUPPLY TUBING AND NEW ADA PIPE INSULATION FOR P-TRAP, DRAINAGE PIPING, AND WATER PIPING. PROVIDE NEW SYMMONS MODEL S210CK THERMOSTATIC MIXING VALVE. THE NUMBER OF FAUCETS TO VERIFY IS IDENTIFIED ON PLANS WITH CIRCLE TAG.

2.


ONE URINAL TEE DRAIN PIPE HAS CRACKED; COORDINATE WITH WHITE SOX'S ON EXACT LOCATION AND REPLACE/REPAIR FAILURE.

1 PLUMBING PLAN - 100 LEVEL - SECTION 10 ENLARGED

SCALE: 1/8" = 1'-0"

10

10

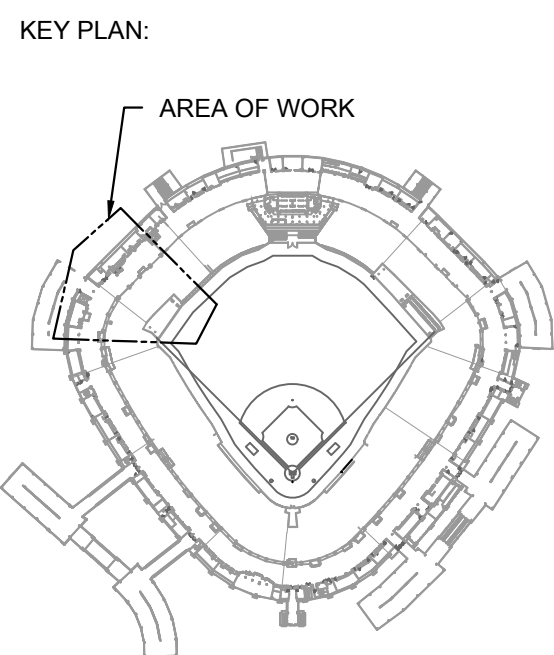

ISSUE/REVISION:

REV.	DATE	DESCRIPTION
11/14/25		ISSUE FOR BID

PROJECT:


GUARANTEED RATE FIELD - WASTE/VENT PIPING FY2026

333 W 35TH STREET, CHICAGO, ILLINOIS 60616

DRAWING TITLE:

PLUMBING PLAN - LEVEL 100 - SECTION 10

DESIGNED BY:	CF
CHECKED BY:	MS
PROJECT NO:	25081
SCALE:	1/8" = 1'-0"
SHEET NO.	

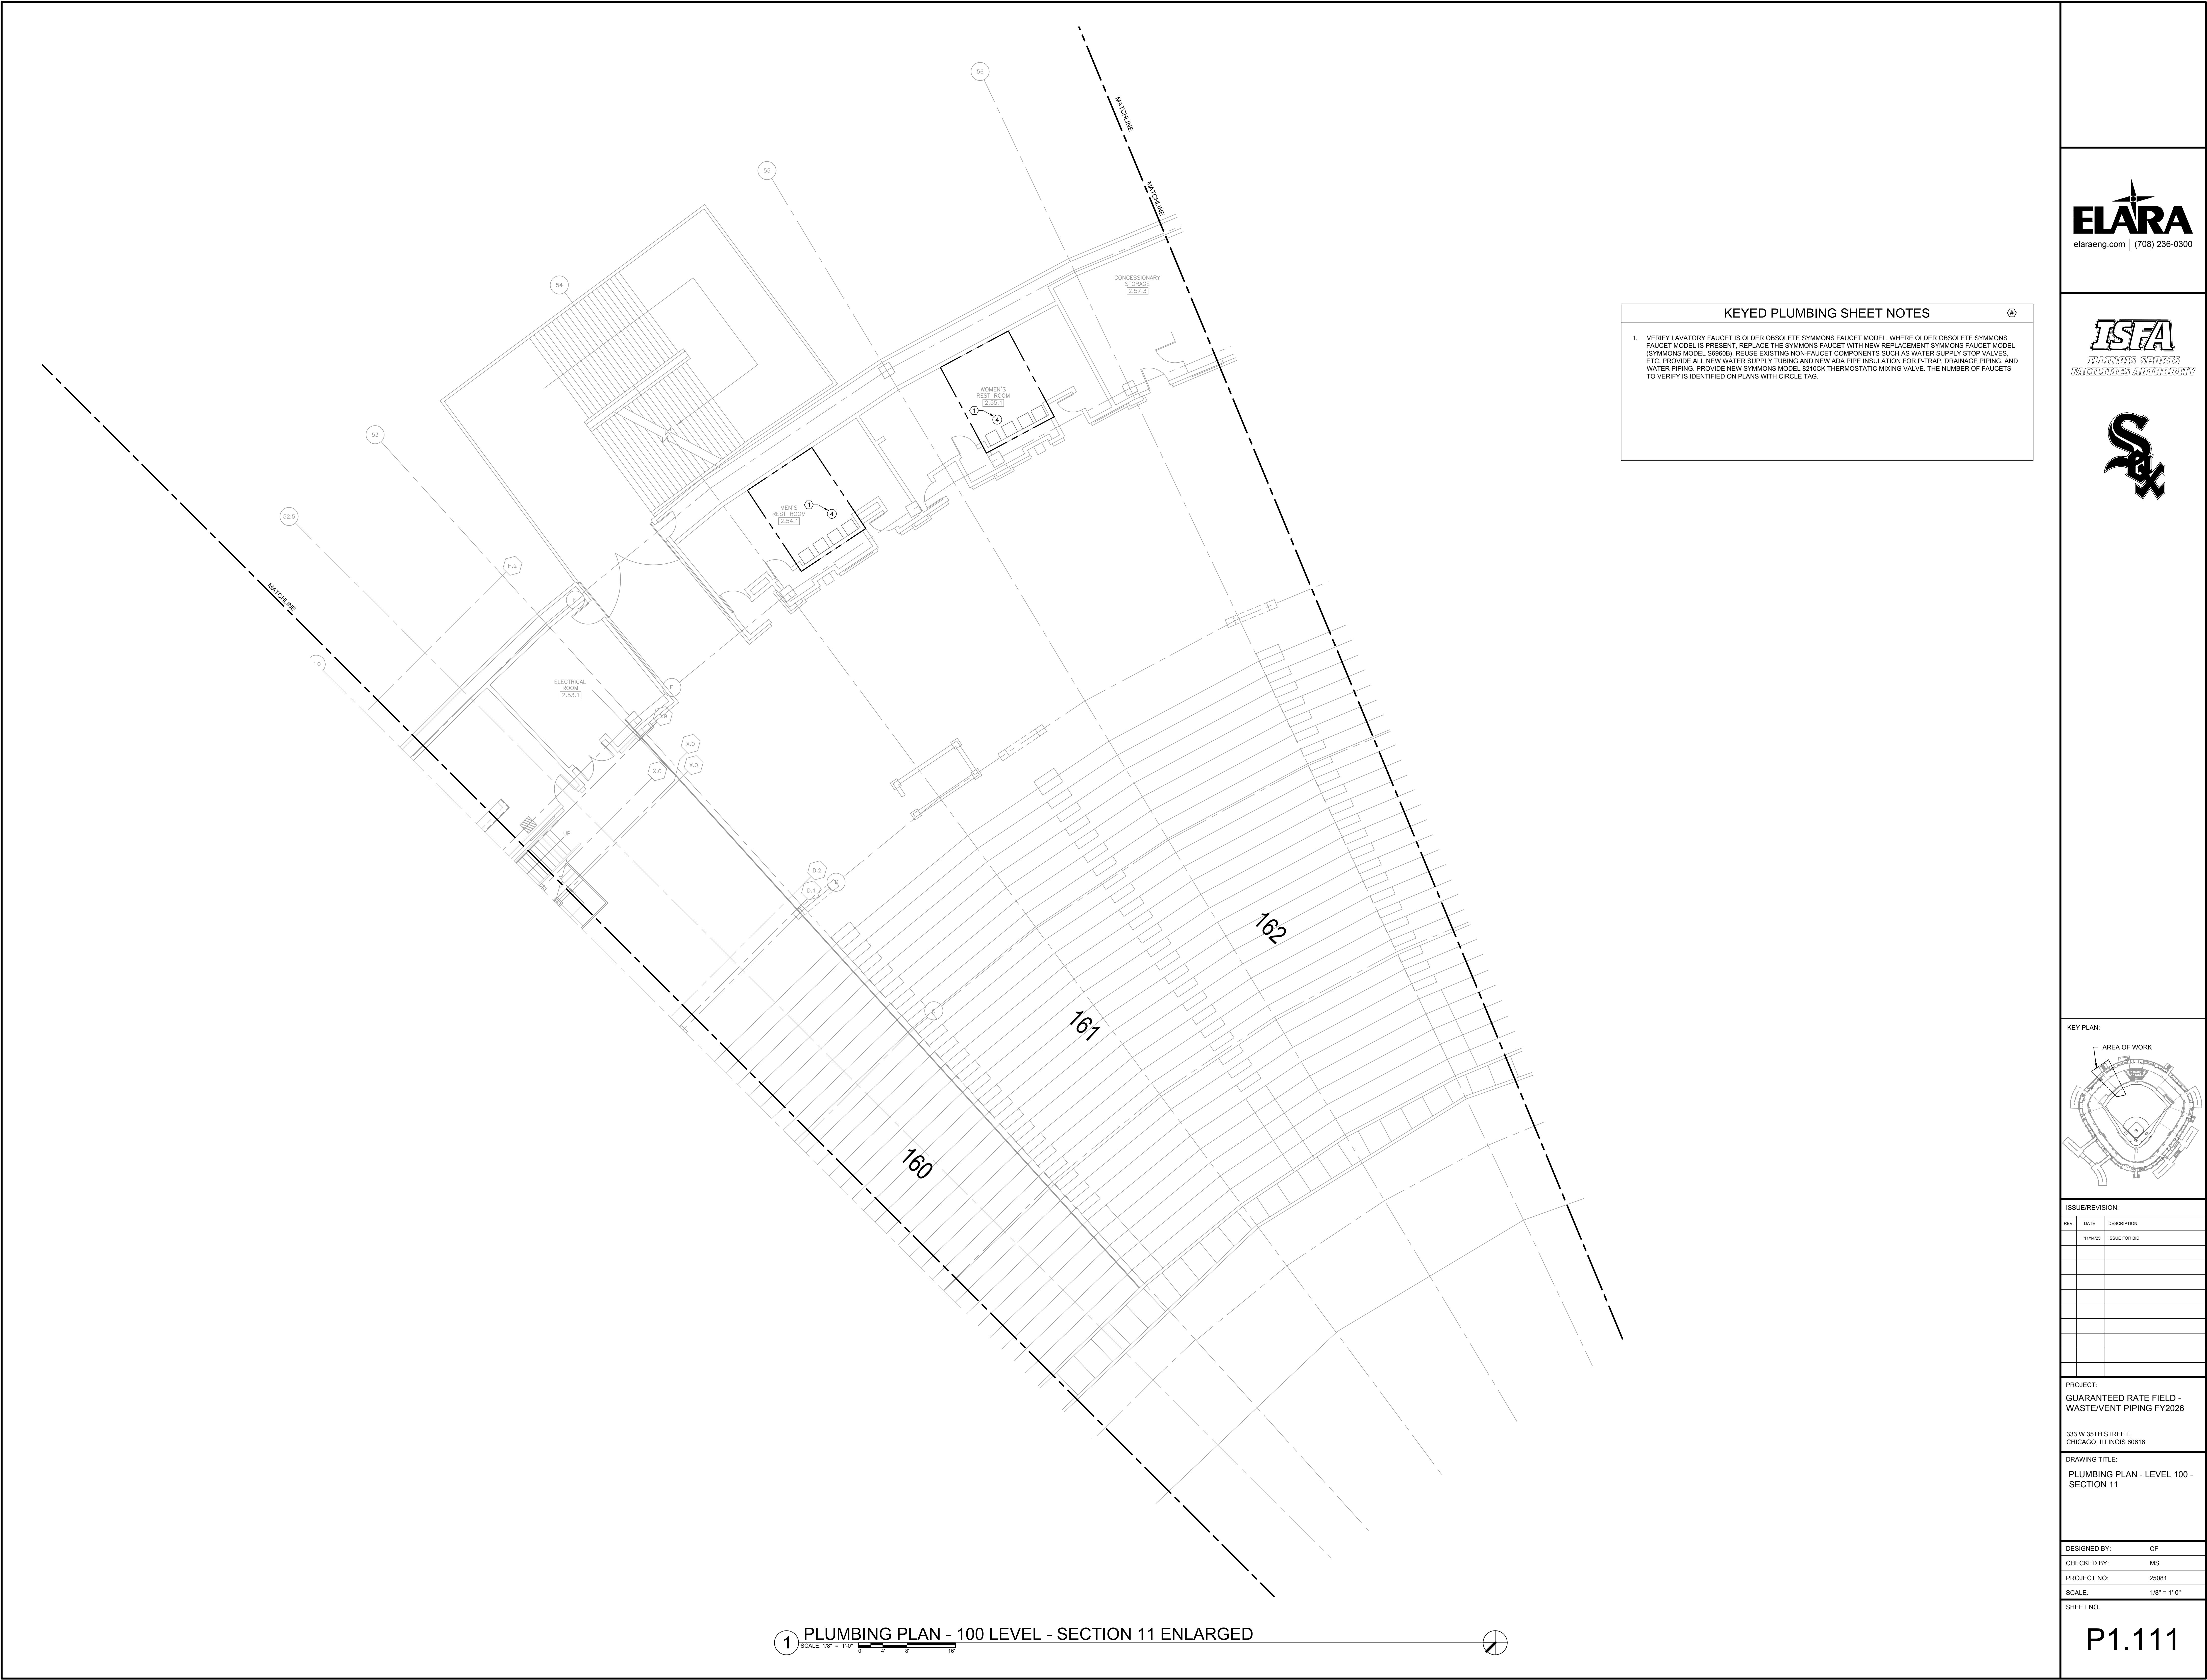

KEYED PLUMBING SHEET NOTES

1. VERIFY LAVATORY FAUCET IS OLDER OBSOLETE SYMMONS FAUCET MODEL. WHERE OLDER OBSOLETE SYMMONS FAUCET MODEL IS PRESENT, REPLACE THE SYMMONS FAUCET WITH NEW REPLACEMENT SYMMONS FAUCET MODEL (SYMMONS MODEL S8960B). REUSE EXISTING NON-FAUCET COMPONENTS SUCH AS WATER SUPPLY STOP VALVES, ETC. PROVIDE ALL NEW WATER SUPPLY TUBING AND NEW ADA PIPE INSULATION FOR P-TRAP, DRAINAGE PIPING, AND WATER PIPING. PROVIDE NEW SYMMONS MODEL S210CK THERMOSTATIC MIXING VALVE. THE NUMBER OF FAUCETS TO VERIFY IS IDENTIFIED ON PLANS WITH CIRCLE TAG.




elaraeng.com | (708) 236-0300



INLAND SPOKES
FACILITIES AUTHORITY

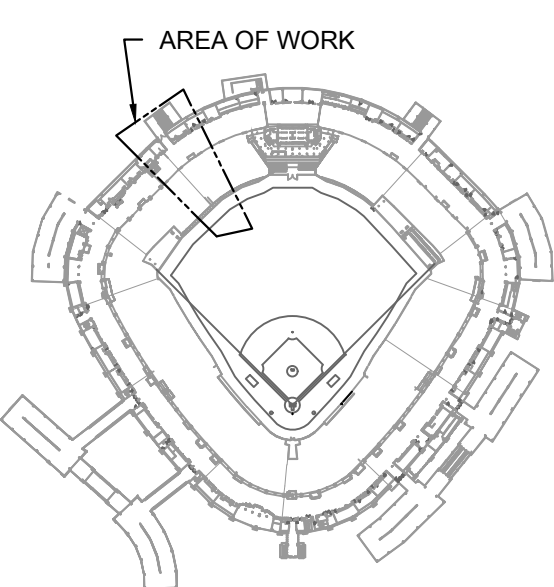

KEY PLAN:


ISSUE/REVISION:

REV.	DATE	DESCRIPTION
1	11/14/25	ISSUE FOR BID


PROJECT:
GUARANTEED RATE FIELD -
WASTE/VENT PIPING FY2026

333 W 35TH STREET,
CHICAGO, ILLINOIS 60616

DRAWING TITLE:
PLUMBING PLAN - LEVEL 100 -
SECTION 11

DESIGNED BY: CF
CHECKED BY: MS
PROJECT NO: 25081
SCALE: 1/8" = 1'-0"

SHEET NO.
P1.111

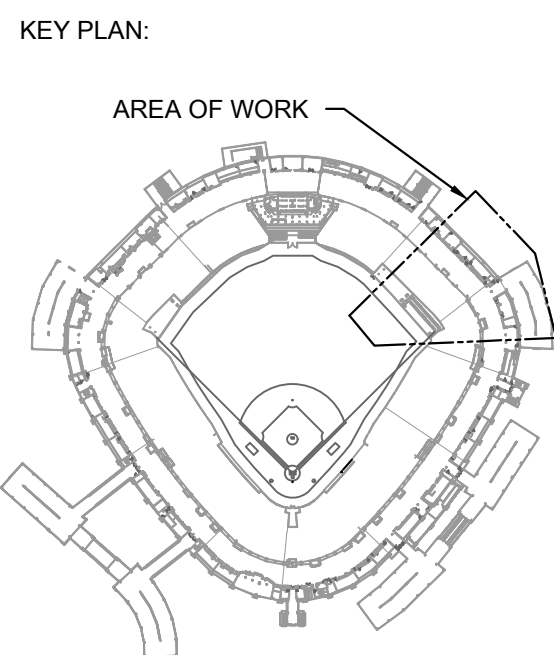

ISSUE/REVISION:		
REV.	DATE	DESCRIPTION
1	11/14/25	ISSUE FOR BID

PROJECT:
GUARANTEED RATE FIELD -
WASTE/VENT PIPING FY2026

333 W 35TH STREET,
CHICAGO, ILLINOIS 60616

DRAWING TITLE:
PLUMBING PLAN - LEVEL 200 -
SECTION 3

DESIGNED BY: CF
CHECKED BY: MS
PROJECT NO: 25081
SCALE: 1/8" = 1'-0"

SHEET NO.

P1.203

KEYED PLUMBING SHEET NOTES

1. VERIFY LAVATORY FAUCET IS OLDER OBSOLETE SYMMONS FAUCET MODEL. WHERE OLDER OBSOLETE SYMMONS FAUCET MODEL IS PRESENT, REPLACE THE SYMMONS FAUCET WITH NEW REPLACEMENT SYMMONS FAUCET MODEL (SYMMONS MODEL S6606). REUSE EXISTING NON-FAUCET COMPONENTS SUCH AS WATER SUPPLY STOP VALVES, ETC. PROVIDE ALL NEW WATER SUPPLY TUBING AND NEW ADA PIPE INSULATION FOR P-TRAP, DRAINAGE PIPING, AND WATER PIPING. PROVIDE NEW SYMMONS MODEL 8210CK THERMOSTATIC MIXING VALVE. THE NUMBER OF FAUCETS TO VERIFY IS IDENTIFIED ON PLANS WITH CIRCLE TAG.


1 PLUMBING PLAN - 200 LEVEL - SECTION 3 ENLARGED
SCALE: 1/8" = 1'-0"



KEYED PLUMBING SHEET NOTES

1. VERIFY LAVATORY FAUCET IS OLDER OBSOLETE SYMMONS FAUCET MODEL, WHERE OLDER OBSOLETE SYMMONS FAUCET MODEL IS PRESENT, REPLACE THE SYMMONS FAUCET WITH NEW REPLACEMENT SYMMONS FAUCET MODEL (SYMMONS MODEL 568606). REUSE EXISTING NON-FAUCET COMPONENTS SUCH AS WATER SUPPLY STOP VALVES, ETC. PROVIDE ALL NEW WATER SUPPLY TUBING AND NEW ADA PIPE INSULATION FOR P-TRAP, DRAINAGE PIPING, AND WATER PIPING. PROVIDE NEW SYMMONS MODEL 8210CK THERMOSTATIC MIXING VALVE. THE NUMBER OF FAUCETS TO VERIFY IS IDENTIFIED ON PLANS WITH CIRCLE TAG.

1 PLUMBING PLAN - 200 LEVEL - SECTION 4 ENLARGED

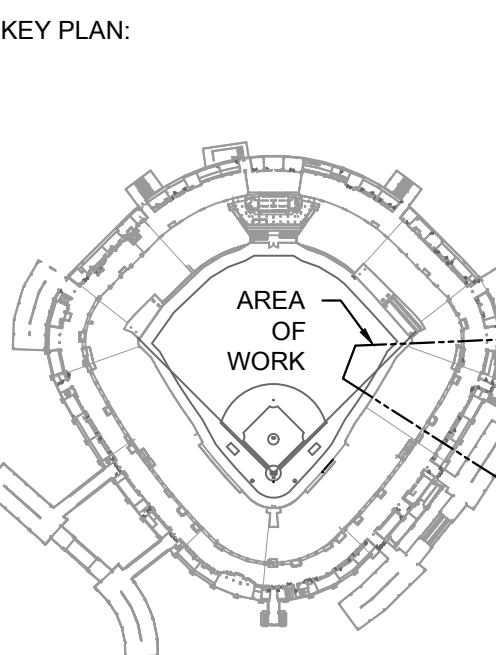

ISSUE/REVISION:		
REV.	DATE	DESCRIPTION
1	11/14/25	ISSUE FOR BID



PROJECT:
GUARANTEED RATE FIELD -
WASTE/VENT PIPING FY2026

333 W 35TH STREET,
CHICAGO, ILLINOIS 60616

DRAWING TITLE:
PLUMBING PLAN - LEVEL 200 -
SECTION 4

DESIGNED BY: CF
CHECKED BY: MS
PROJECT NO: 25081
SCALE: 1/8" = 1'-0"

SHEET NO.
P1.204

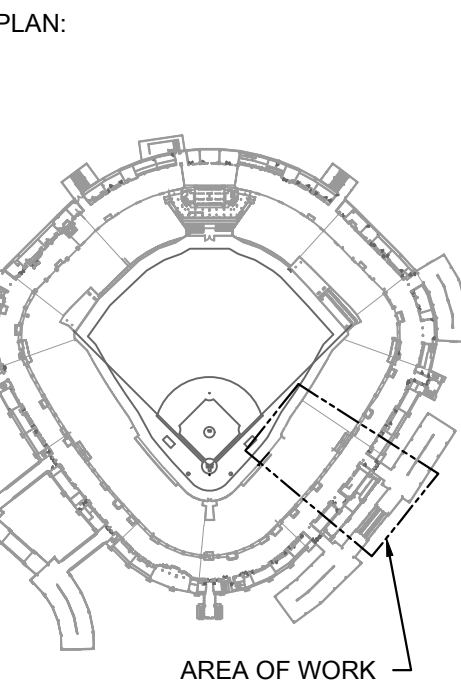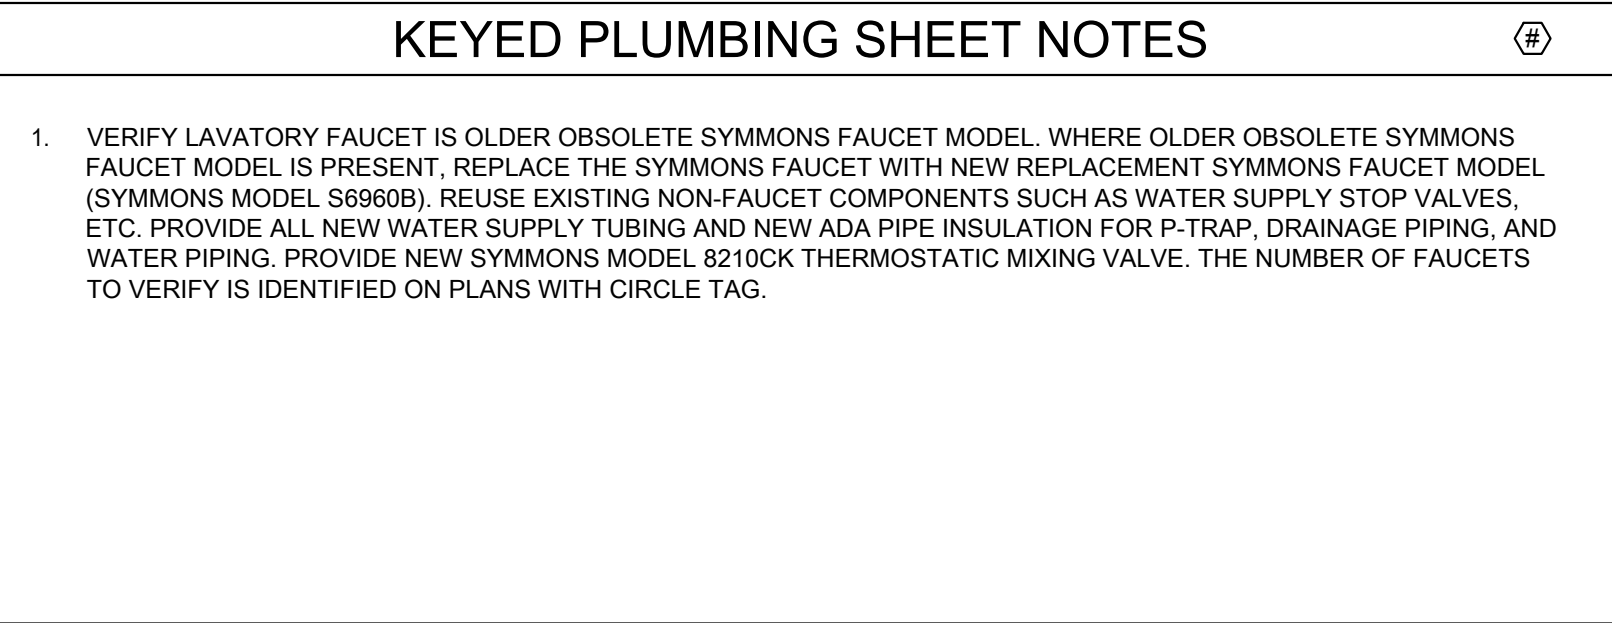[illegible]

ECT:
 GUARANTEED RATE FIELD -
 WASTE/VENT PIPING FY2026



35TH STREET,
CHICAGO, ILLINOIS 60616

CLIMBING PLAN - LEVEL 200 -
SECTION 5

DESIGNED BY:	CF
CHECKED BY:	MS
PROJECT NO:	25081
SCALE:	1/8" = 1'-0"

T NO.

P1.205

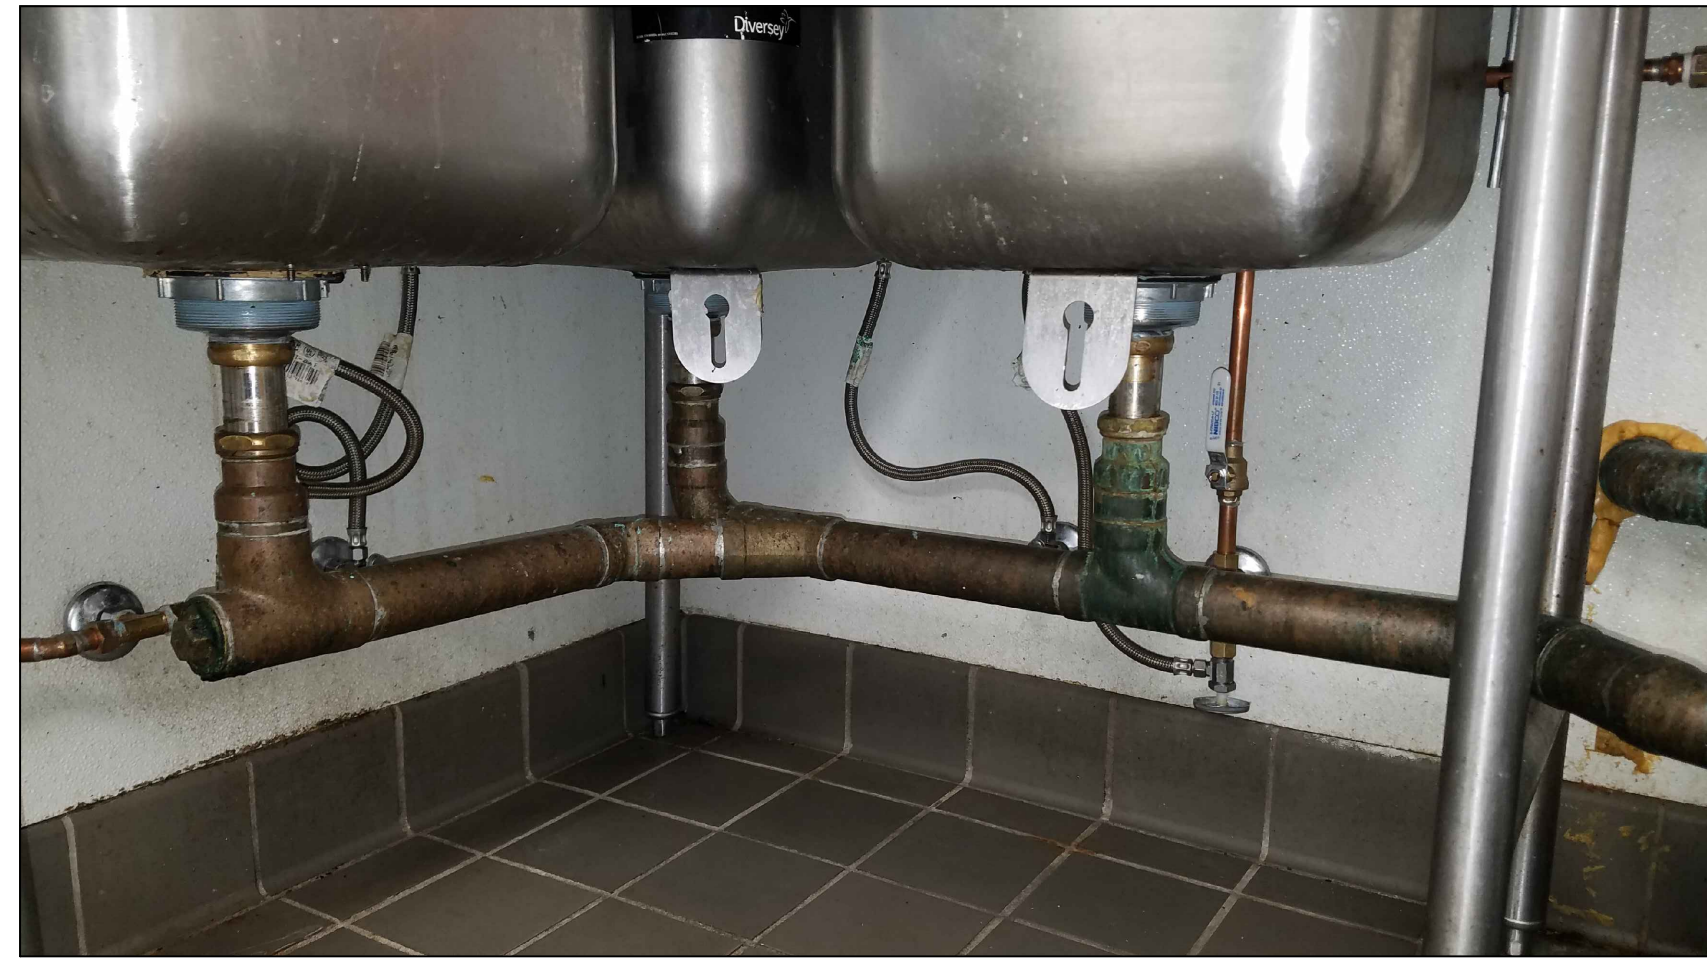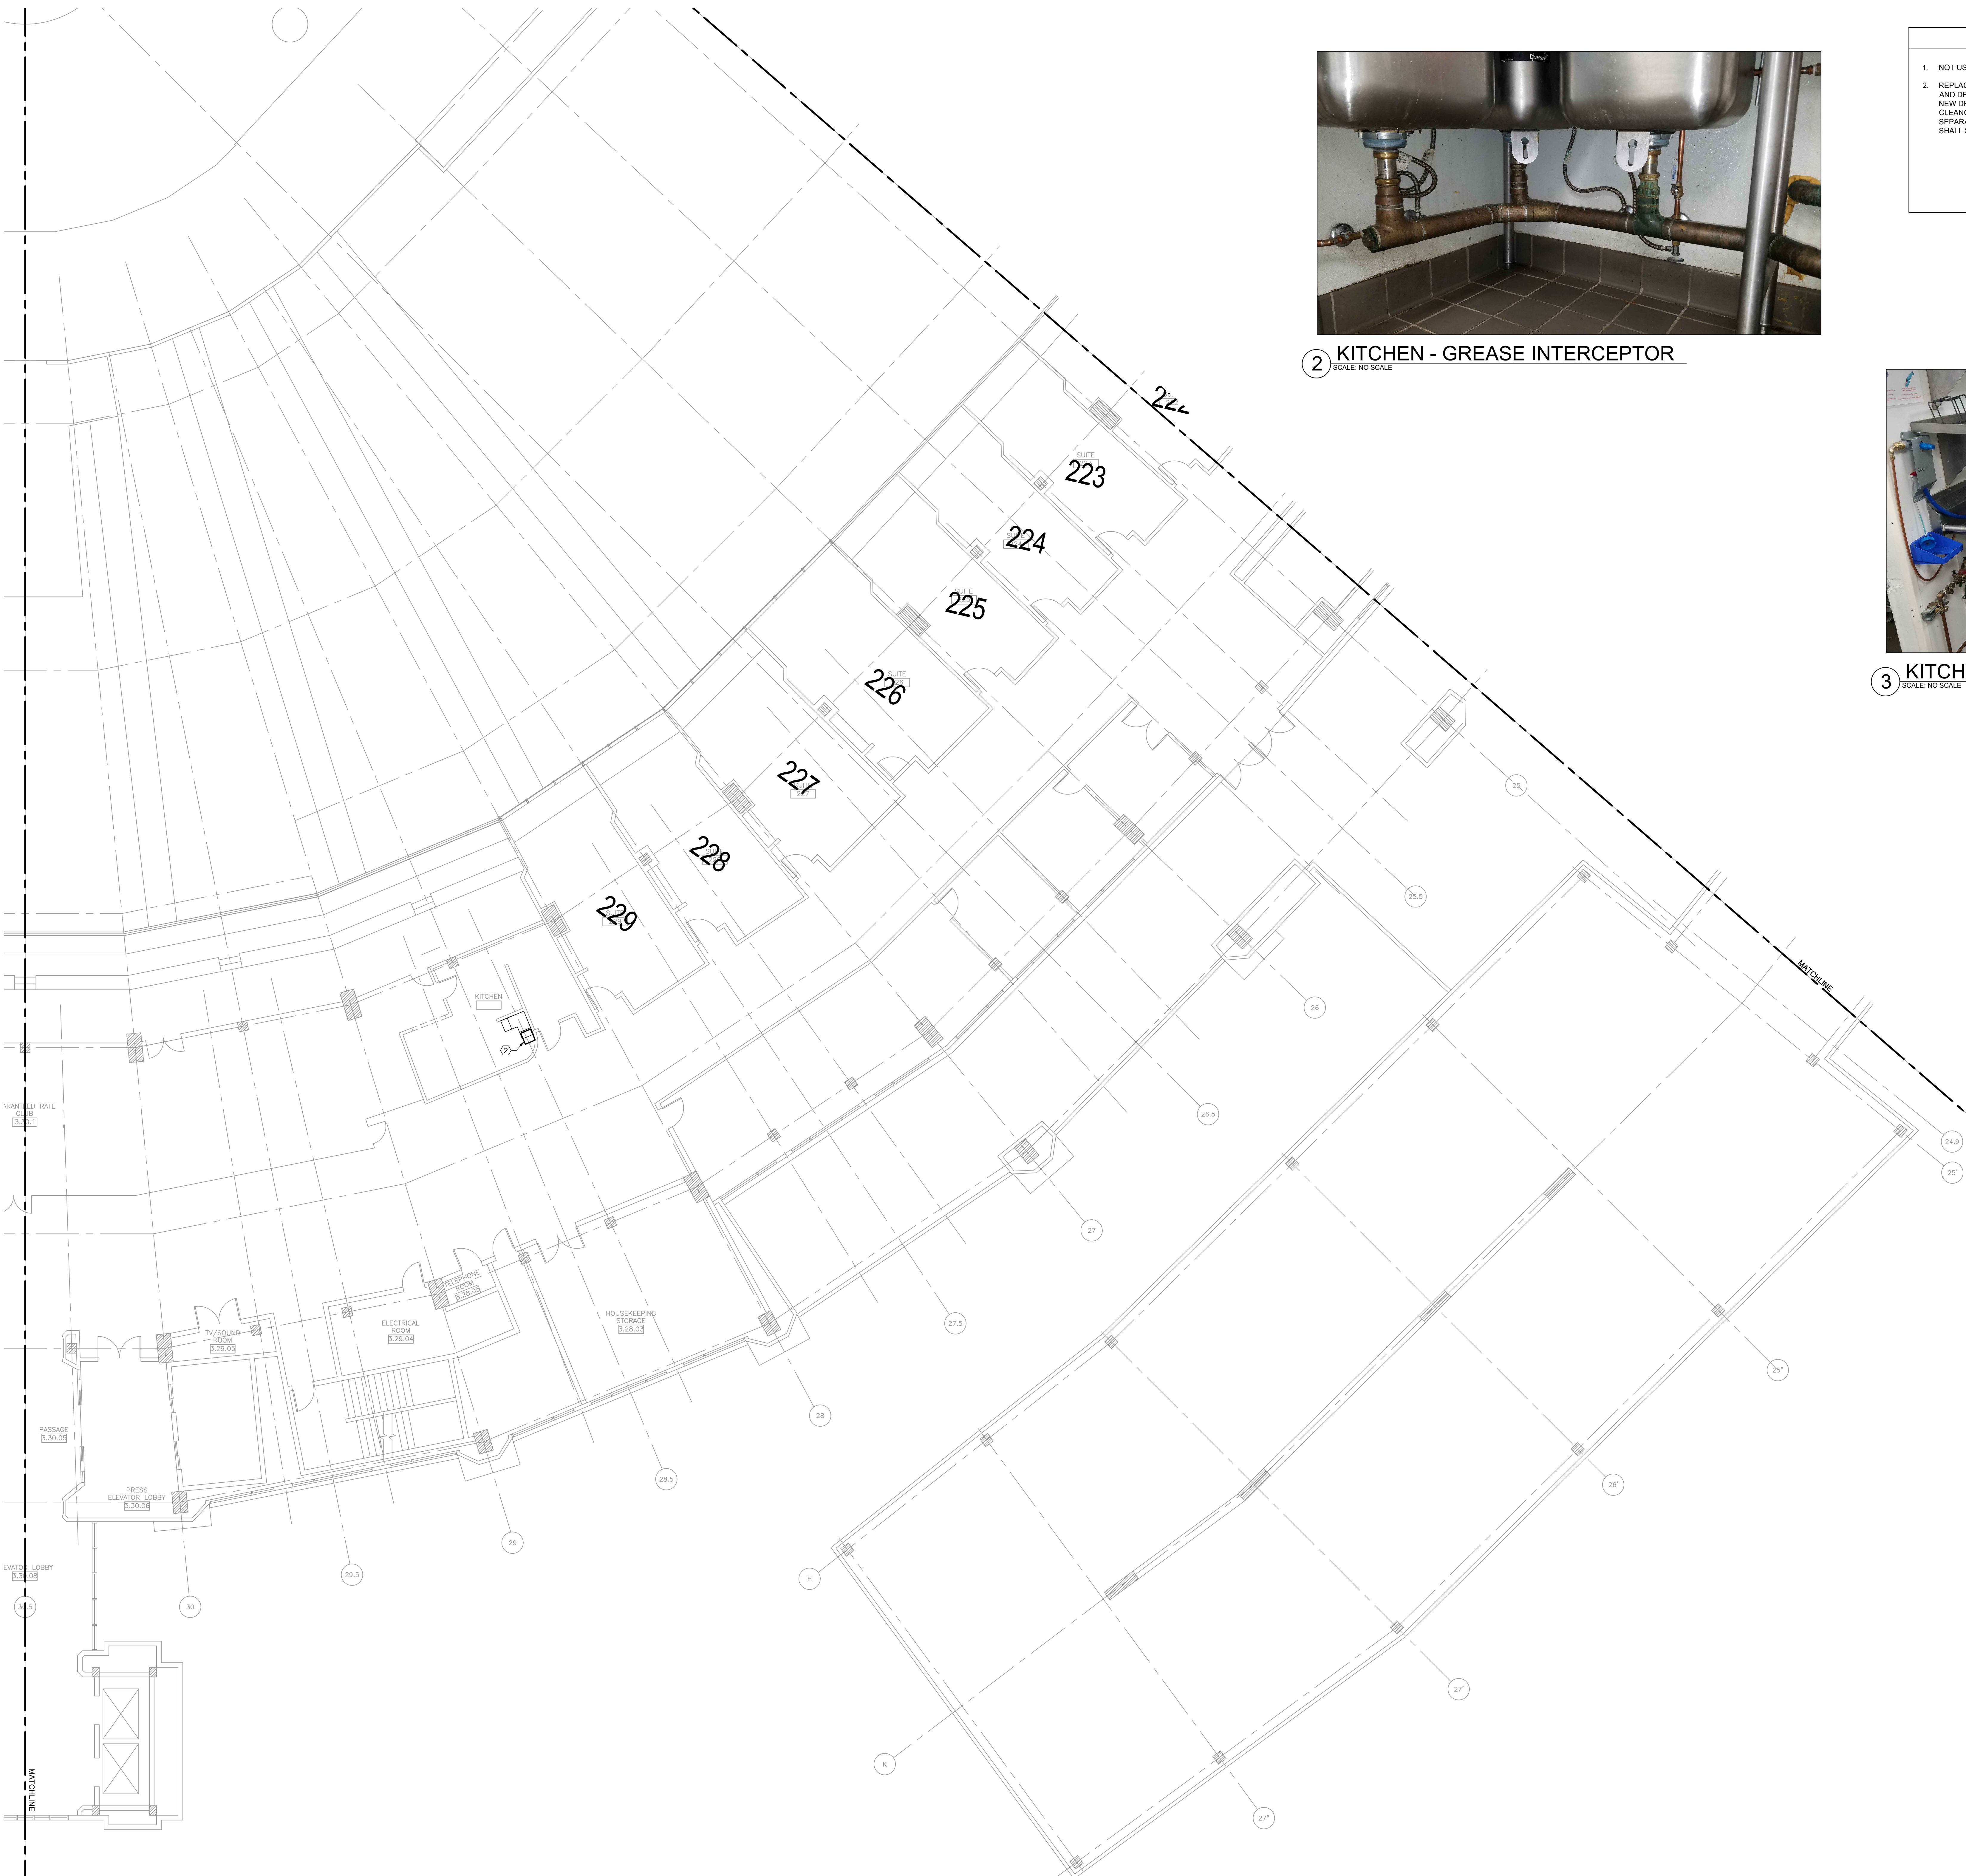


2 KITCHEN - GREASE INTERCEPTOR
SCALE: NO SCALE


KEYED PLUMBING SHEET NOTES	
1.	NOT USED.
2.	REPLACE EXISTING GREASE INTERCEPTOR WITH NEW GREASE INTERCEPTOR. REPLACE EXISTING DRAINAGE PIPING AND DRAIN STOPPER AT EACH COMPARTMENT OF THE THREE-COMPARTMENT SINK WITH NEW DRAINAGE PIPING AND NEW DRAIN STOPPER. REPLACE EXISTING DOWNSTREAM DRAINAGE PIPING FROM THE GREASE INTERCEPTOR WITH CLEANOUT ABOVE FLOOR WITH NEW PIPING AND NEW CLEANOUT. SEE PHOTOS ON THIS SHEET. PROVIDE ROCKFORD SEPARATOR MODEL GF-1820-L WITH EPOXY COATING (INSIDE AND OUTSIDE) AND CAST IRON OUTLET FITTINGS. UNIT SHALL SITE ON FLOOR SIMILAR TO EXISTING INSTALLATION.



3 KITCHEN - GREASE INTERCEPTOR
SCALE: NO SCALE

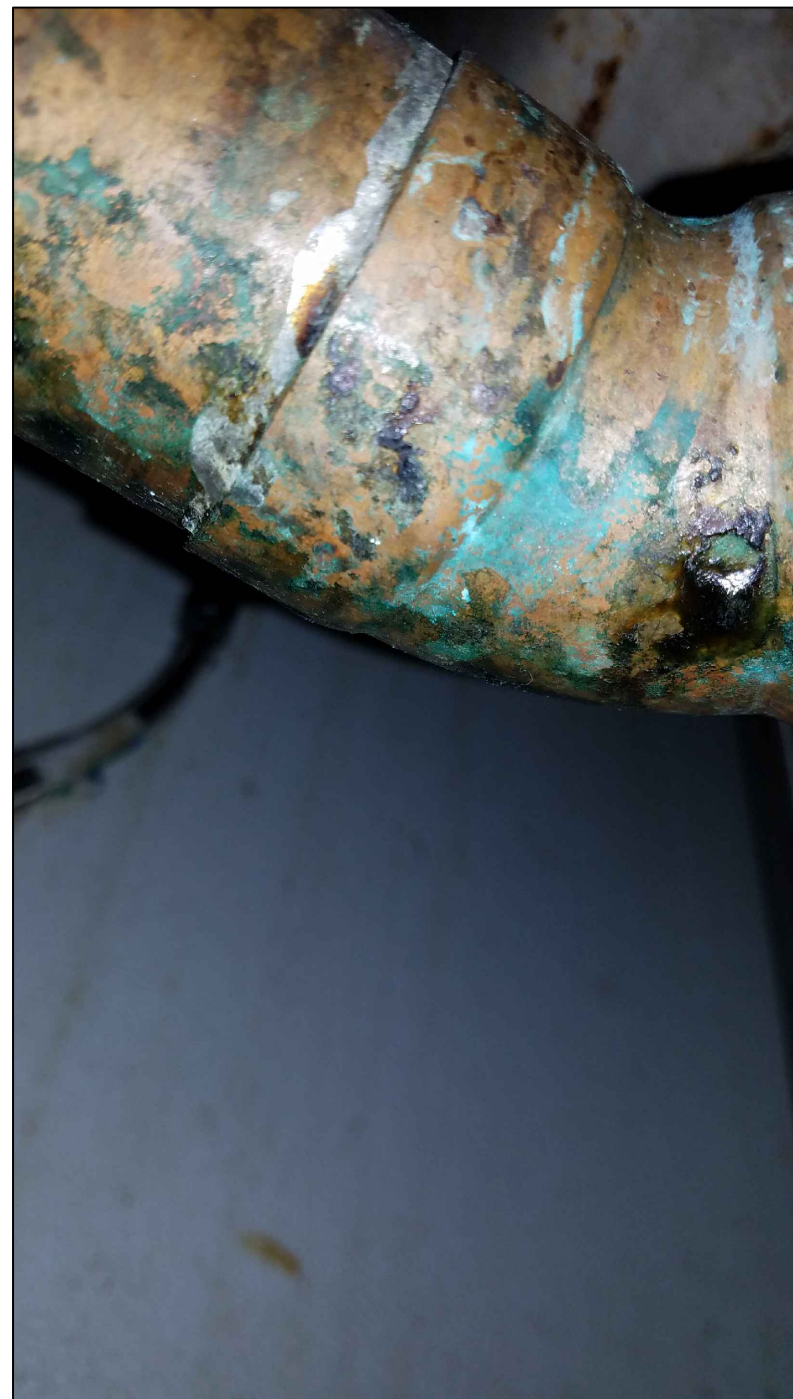

4 KITCHEN - GREASE INTERCEPTOR
SCALE: NO SCALE

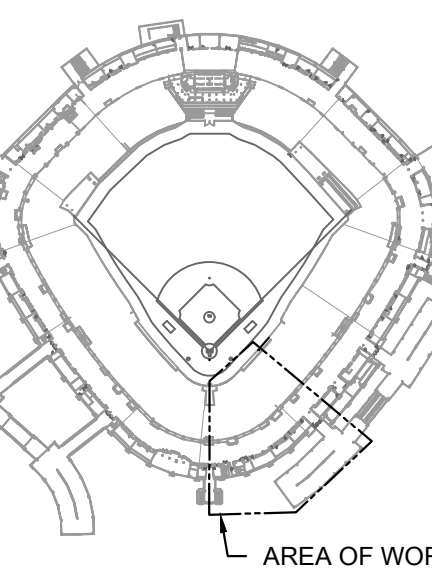

REV.	DATE	DESCRIPTION
11/14/20		ISSUE FOR BID



KEYED PLUMBING SHEET NOTES


1. VERIFY LAVATORY FAUCET IS OLDER OBSOLETE SYMMONS FAUCET MODEL. WHERE OLDER OBSOLETE SYMMONS FAUCET MODEL IS PRESENT, REPLACE THE SYMMONS FAUCET WITH NEW REPLACEMENT SYMMONS FAUCET MODEL (SYMMONS MODEL 588608). REUSE EXISTING NON-FAUCET COMPONENTS SUCH AS WATER SUPPLY STOP VALVES, ETC. PROVIDE ALL NEW WATER SUPPLY TUBING AND NEW ADA PIPE INSULATION FOR P-TRAP, DRAINAGE PIPING, AND WATER PIPING. PROVIDE NEW SYMMONS MODEL 6210CK THERMOSTATIC MIXING VALVE. THE NUMBER OF FAUCETS TO VERIFY IS IDENTIFIED ON PLANS WITH CIRCLE TAG.

1 PLUMBING PLAN - 200 LEVEL - SECTION 7 ENLARGED

SCALE: 1/8" = 1'-0"



KEY PLAN:

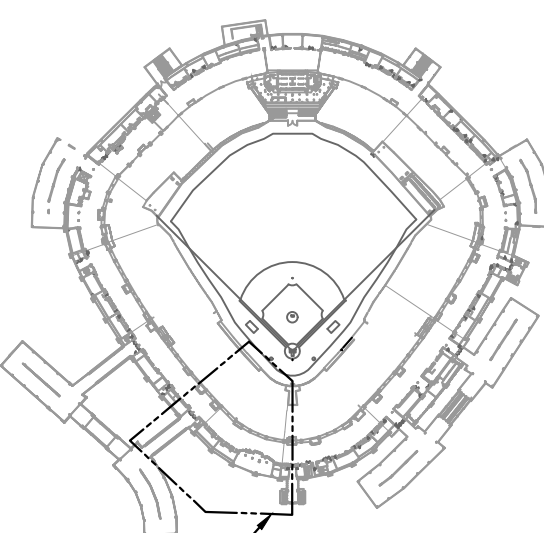

AREA OF WORK:

ISSUE/REVISION:

REV.	DATE	DESCRIPTION
11/14/25		ISSUE FOR BID

PROJECT:
GUARANTEED RATE FIELD -
WASTE/VENT PIPING FY2026

333 W 35TH STREET,
CHICAGO, ILLINOIS 60616

DRAWING TITLE:
PLUMBING PLAN - LEVEL 200 -
SECTION 7

DESIGNED BY: CF
CHECKED BY: MS
PROJECT NO: 25081
SCALE: 1/8" = 1'-0"

SHEET NO.

P1.207



1 PLUMBING PLAN - 200 LEVEL - SECTION 8 ENLARGED

KEYED PLUMBING SHEET NOTES

1. VERIFY LAVATORY FAUCET IS OLDER OBSOLETE SYMMONS FAUCET MODEL. WHERE OLDER OBSOLETE SYMMONS FAUCET MODEL IS PRESENT, REPLACE THE SYMMONS FAUCET WITH NEW REPLACEMENT SYMMONS FAUCET MODEL (SYMMONS MODEL S6960B). REUSE EXISTING NON-FAUCET COMPONENTS SUCH AS WATER SUPPLY STOP VALVES, ETC. PROVIDE ALL NEW WATER SUPPLY TUBING AND NEW ADA PIPE INSULATION FOR P-TRAP, DRAINAGE PIPING, AND WATER PIPING. PROVIDE NEW SYMMONS MODEL B210CK THERMOSTATIC MIXING VALVE. THE NUMBER OF FAUCETS TO VERIFY IS IDENTIFIED ON PLANS WITH CIRCLE TAG.




elaraeng.com | (708) 236-0300



INLAND SPOKE
FACILITIES AUTHORITY

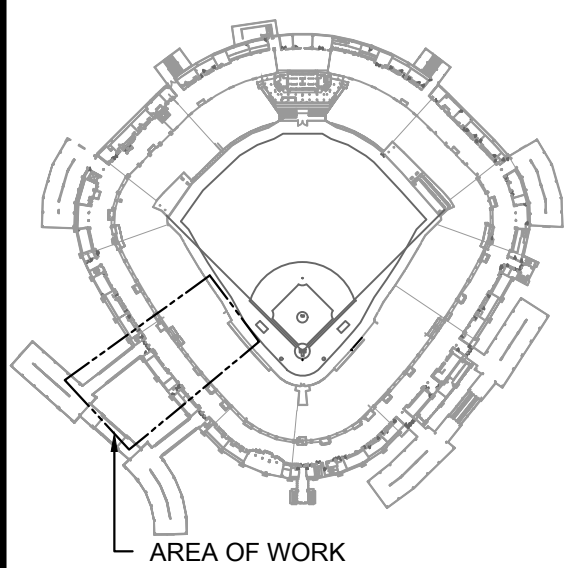

KEY PLAN:

ISSUE/REVISION:

REV.	DATE	DESCRIPTION
1	11/14/25	ISSUE FOR BID


PROJECT:
GUARANTEED RATE FIELD -
WASTE/VENT PIPING FY2026

333 W 35TH STREET,
CHICAGO, ILLINOIS 60616

DRAWING TITLE:
PLUMBING PLAN - LEVEL 200 -
SECTION 8

DESIGNED BY: CF
CHECKED BY: MS
PROJECT NO: 25081
SCALE: 1/8" = 1'-0"

SHEET NO.
P1.208

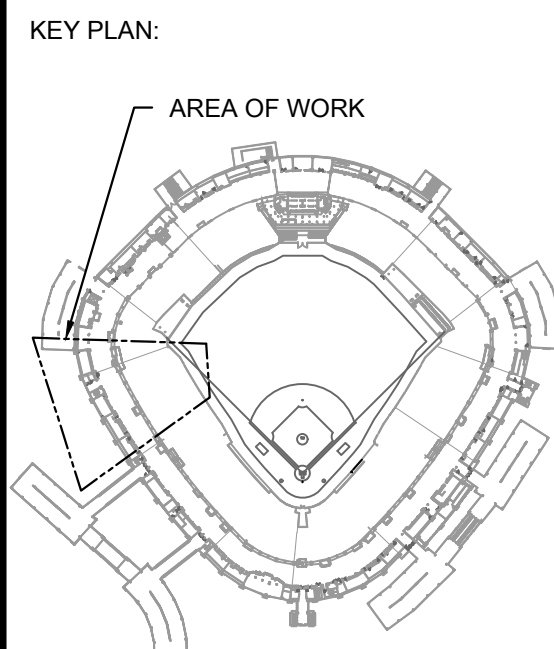[illegible]

PROJECT:
GUARANTEED RATE FIELD -
WASTE/VENT PIPING FY2026

333 W 35TH STREET,
CHICAGO, ILLINOIS 60616


DRAWING TITLE:

PLUMBING PLAN - LEVEL 200 -
SECTION 9

DESIGNED BY:	CF
CHECKED BY:	MS
PROJECT NO:	25081
SCALE:	1/8" = 1'-0"

SHEET NO.


P1.209

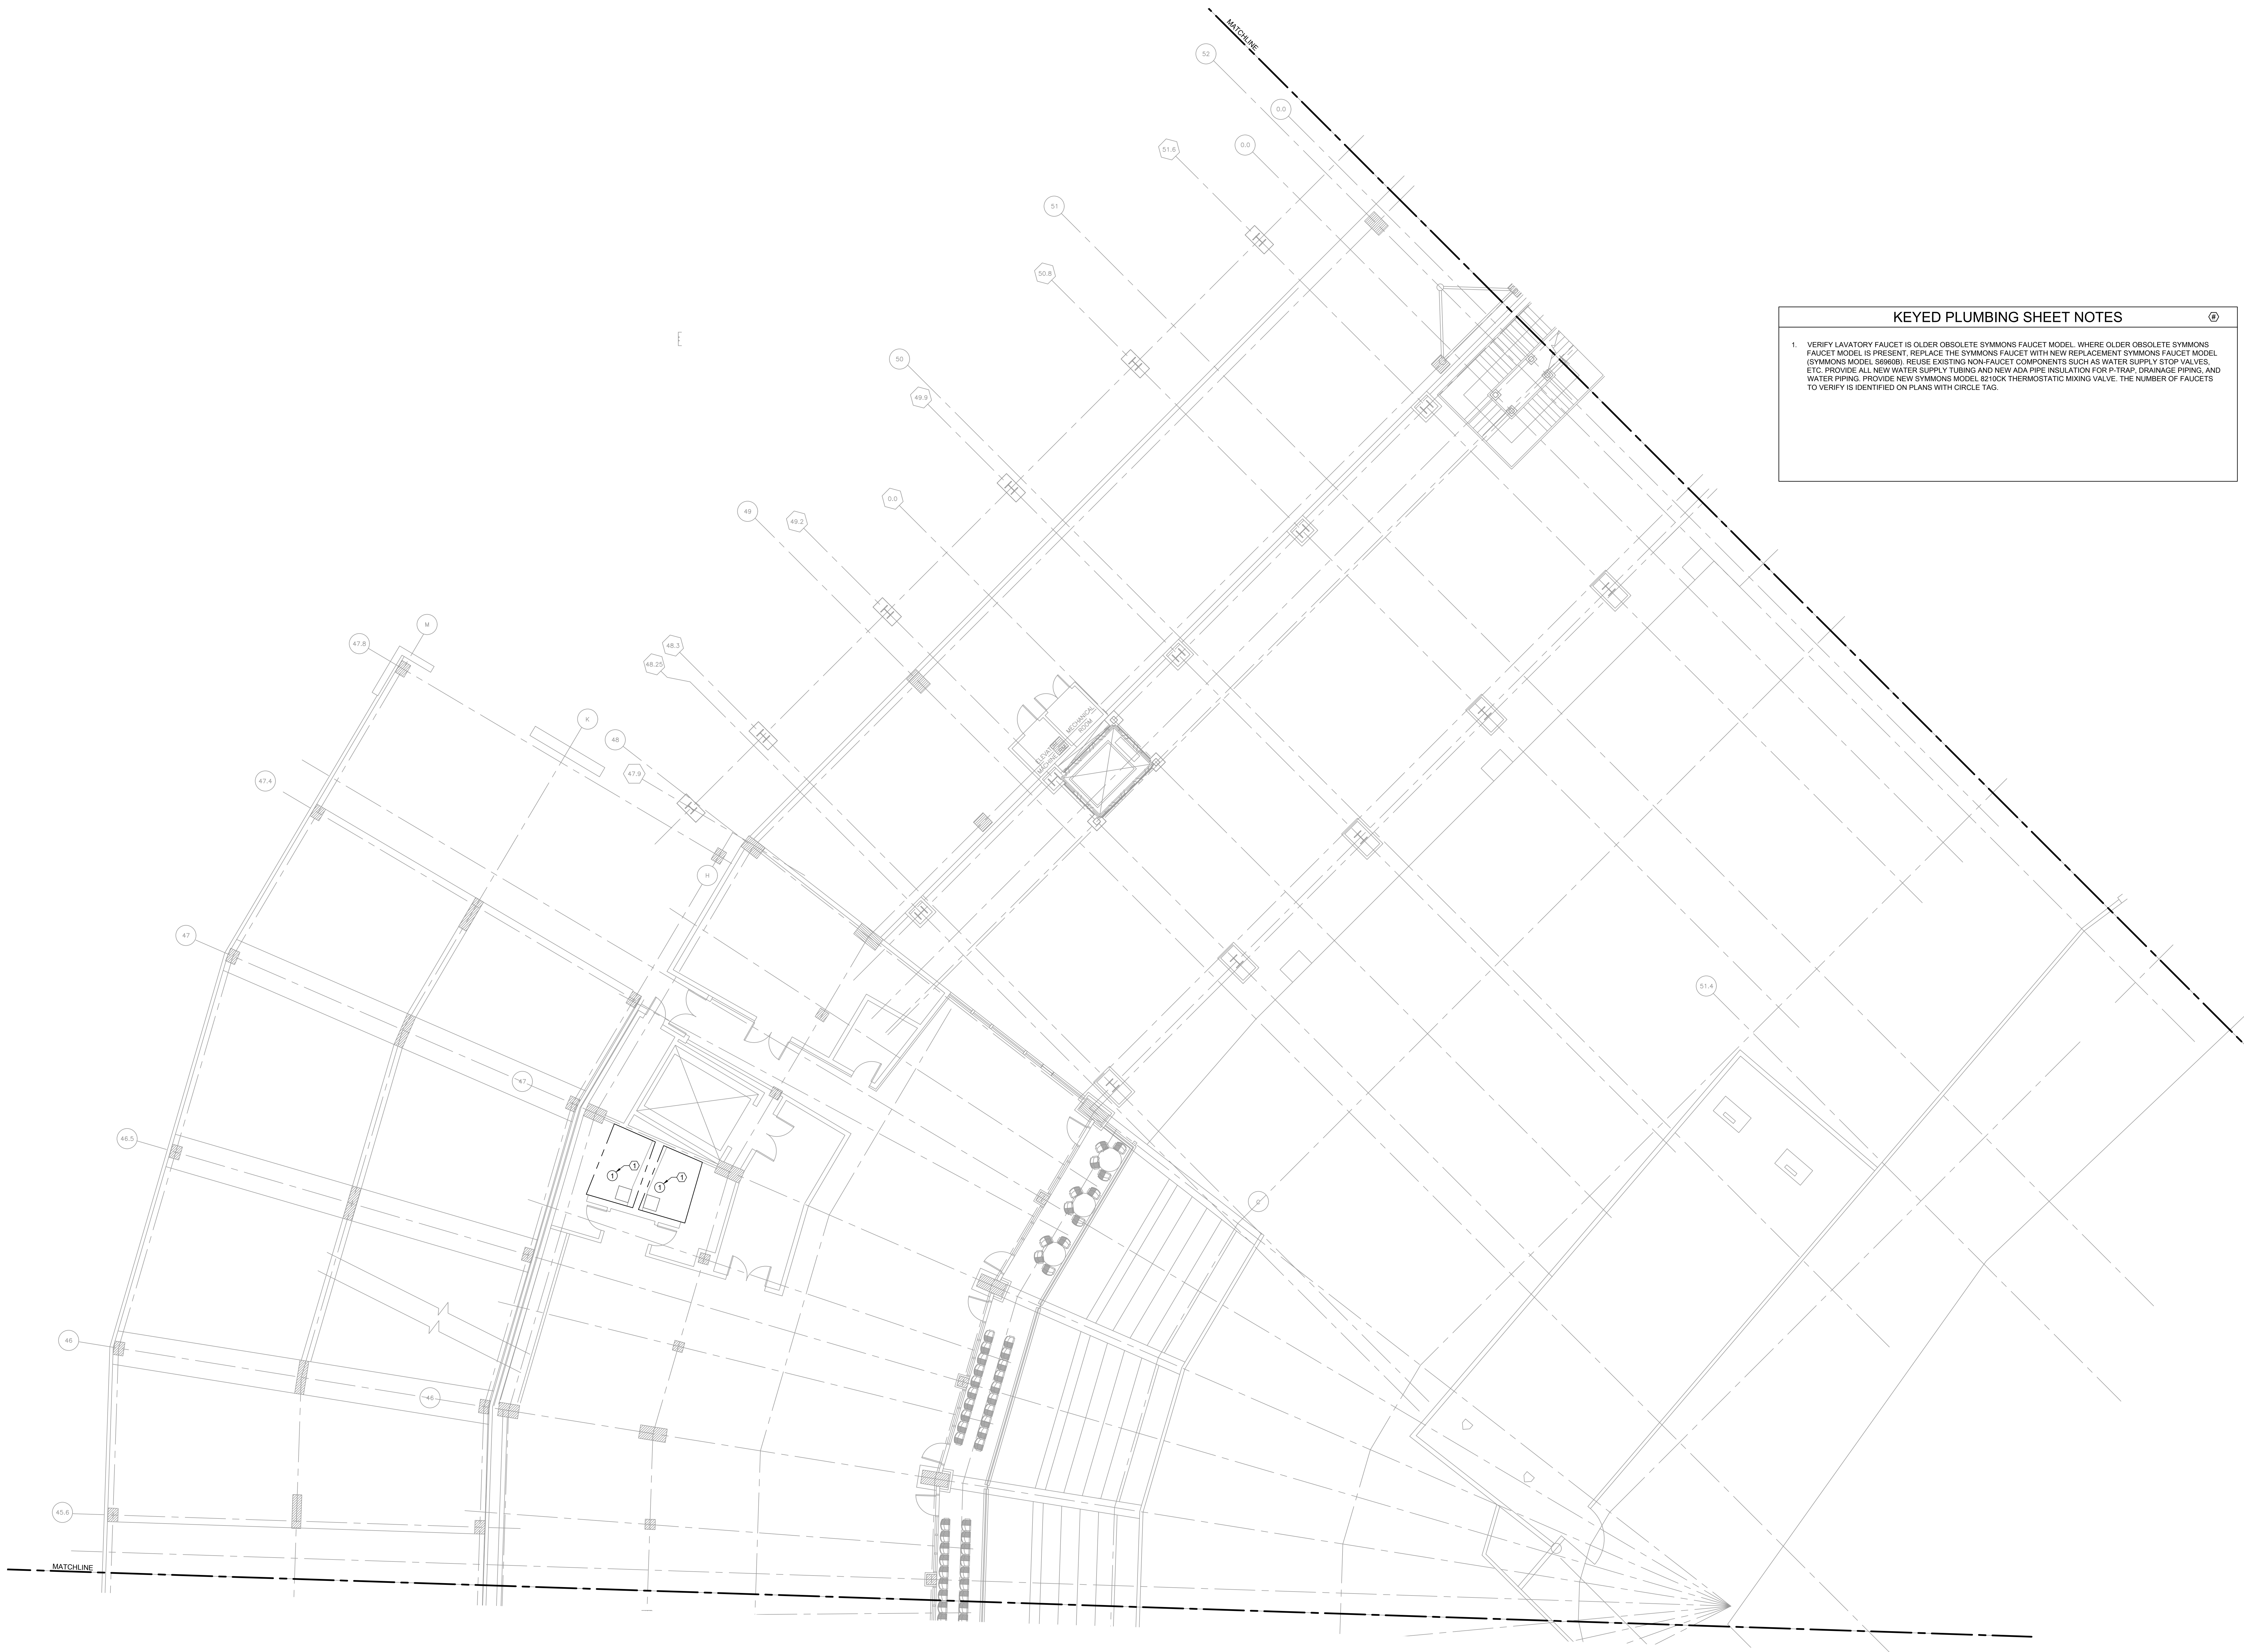

KEYED PLUMBING SHEET NOTES

1. VERIFY LAVATORY FAUCET IS OLDER OBSOLETE SYMMONS FAUCET MODEL. WHERE OLDER OBSOLETE SYMMONS FAUCET MODEL IS PRESENT, REPLACE THE SYMMONS FAUCET WITH NEW REPLACEMENT SYMMONS FAUCET MODEL (SYMMONS MODEL 8980B). REUSE EXISTING NON-FAUCET COMPONENTS SUCH AS WATER SUPPLY STOP VALVES, ETC. PROVIDE ALL NEW WATER SUPPLY TUBING AND NEW ADA PIPE INSULATION FOR P-TRAP, DRAINAGE PIPING, AND WATER PIPING. PROVIDE NEW SYMMONS MODEL 8210CK THERMOSTATIC MIXING VALVE. THE NUMBER OF FAUCETS TO VERIFY IS IDENTIFIED ON PLANS WITH CIRCLE TAG.

1 PLUMBING PLAN - 200 LEVEL - SECTION 10 ENLARGED

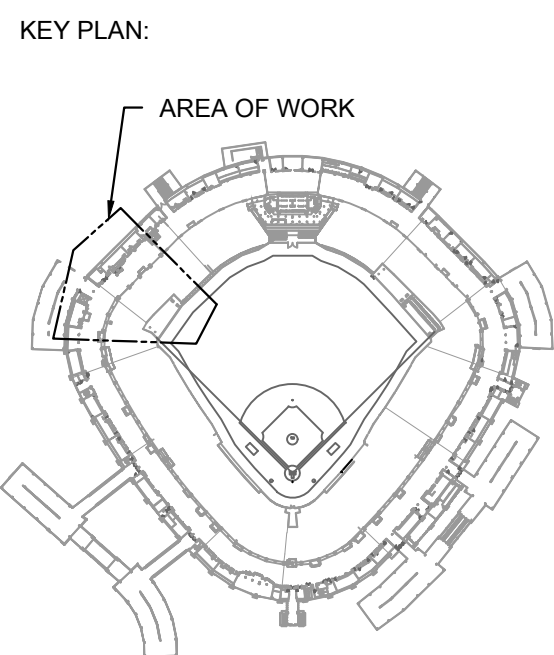

ISSUE/REVISION:

REV.	DATE	DESCRIPTION
11/14/25		ISSUE FOR BID

PROJECT:
GUARANTEED RATE FIELD -
WASTE/VENT PIPING FY2026

333 W 35TH STREET,
CHICAGO, ILLINOIS 60616

DRAWING TITLE:
PLUMBING PLAN - LEVEL 200 -
SECTION 10

DESIGNED BY: CF
CHECKED BY: MS
PROJECT NO: 25081
SCALE: 1/8" = 1'-0"


SHEET NO.
P1.210



KEYED PLUMBING SHEET NOTES

1. VERIFY LAVATORY FAUCET IS OLDER OBSOLETE SYMMONS FAUCET MODEL, WHERE OLDER OBSOLETE SYMMONS FAUCET MODEL IS PRESENT, REPLACE THE SYMMONS FAUCET WITH NEW REPLACEMENT SYMMONS FAUCET MODEL (SYMMONS MODEL 566606). REUSE EXISTING NON-FAUCET COMPONENTS SUCH AS WATER SUPPLY STOP VALVES, ETC. PROVIDE ALL NEW WATER SUPPLY TUBING AND NEW ADA PIPE INSULATION FOR P-TRAP, DRAINAGE PIPING, AND WATER PIPING. PROVIDE NEW SYMMONS MODEL 8210CK THERMOSTATIC MIXING VALVE. THE NUMBER OF FAUCETS TO VERIFY IS IDENTIFIED ON PLANS WITH CIRCLE TAG.

1 PLUMBING PLAN - 300 LEVEL - SECTION 4 ENLARGED

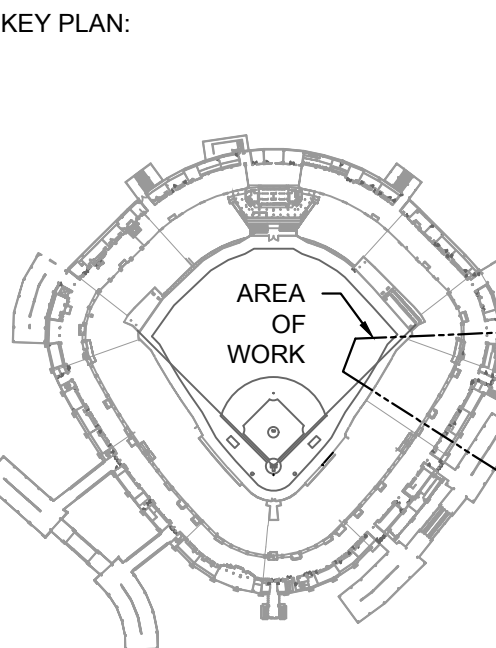

ISSUE/REVISION:		
REV.	DATE	DESCRIPTION
11/14/25		ISSUE FOR BID

PROJECT:
GUARANTEED RATE FIELD -
WASTE/VENT PIPING FY2026

333 W 35TH STREET,
CHICAGO, ILLINOIS 60616

DRAWING TITLE:
PLUMBING PLAN - LEVEL 300 -
SECTION 4

DESIGNED BY: CF
CHECKED BY: MS
PROJECT NO: 25081
SCALE: 1/8" = 1'-0"

SHEET NO.



KEYED PLUMBING SHEET NOTES

1. VERIFY LAVATORY FAUCET IS OLDER OBSOLETE SYMMONS FAUCET MODEL. WHERE OLDER OBSOLETE SYMMONS FAUCET MODEL IS PRESENT, REPLACE THE SYMMONS FAUCET WITH NEW REPLACEMENT SYMMONS FAUCET MODEL (SYMMONS MODEL S666B). REUSE EXISTING NON-FAUCET COMPONENTS SUCH AS WATER SUPPLY STOP VALVES, ETC. PROVIDE ALL NEW WATER SUPPLY TUBING AND NEW ADA PIPE INSULATION FOR P-TRAP, DRAINAGE PIPING, AND WATER PIPING. PROVIDE NEW SYMMONS MODEL S2100K THERMOSTATIC MIXING VALVE. THE NUMBER OF FAUCETS TO VERIFY IS IDENTIFIED ON PLANS WITH CIRCLE TAG.




elaraeng.com | (708) 236-0300



ILLINOIS SPORTS FACILITIES AUTHORITY



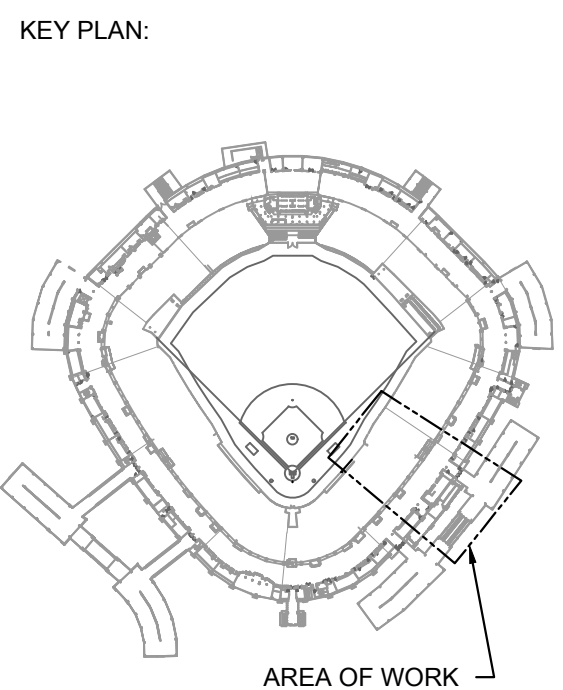

ISSUE/REVISION:		
REV.	DATE	DESCRIPTION
1	11/14/25	ISSUE FOR BID

PROJECT:
GUARANTEED RATE FIELD -
WASTE/VENT PIPING FY2026

333 W 35TH STREET,
CHICAGO, ILLINOIS 60616


DRAWING TITLE:
PLUMBING PLAN - LEVEL 300 -
SECTION 5

DESIGNED BY:	CF
CHECKED BY:	MS
PROJECT NO.:	25081
SCALE:	1/8" = 1'-0"
SHEET NO.	

P1.305




1. VERIFY LAVATORY FAUCET IS OLDER OBSOLETE SYMMONS FAUCET MODEL. WHERE OLDER OBSOLETE SYMMONS FAUCET MODEL IS PRESENT, REPLACE THE SYMMONS FAUCET WITH NEW REPLACEMENT SYMMONS FAUCET MODEL (SYMMONS MODEL 569606) REUSE EXISTING NON-FAUCET COMPONENTS SUCH AS WATER SUPPLY STOP VALVES, ETC. PROVIDE ALL NEW WATER SUPPLY TUBING AND NEW ADA PIPE INSULATION FOR P-TRAP, DRAINAGE PIPING, AND WATER PIPING. PROVIDE NEW SYMMONS MODEL 8210CK THERMOSTATIC MIXING VALVE. THE NUMBER OF FAUCETS TO VERIFY IS IDENTIFIED ON PLANS WITH CIRCLE TAG.
2. VIDEO SCOPE OWNER SUITE PIPING.

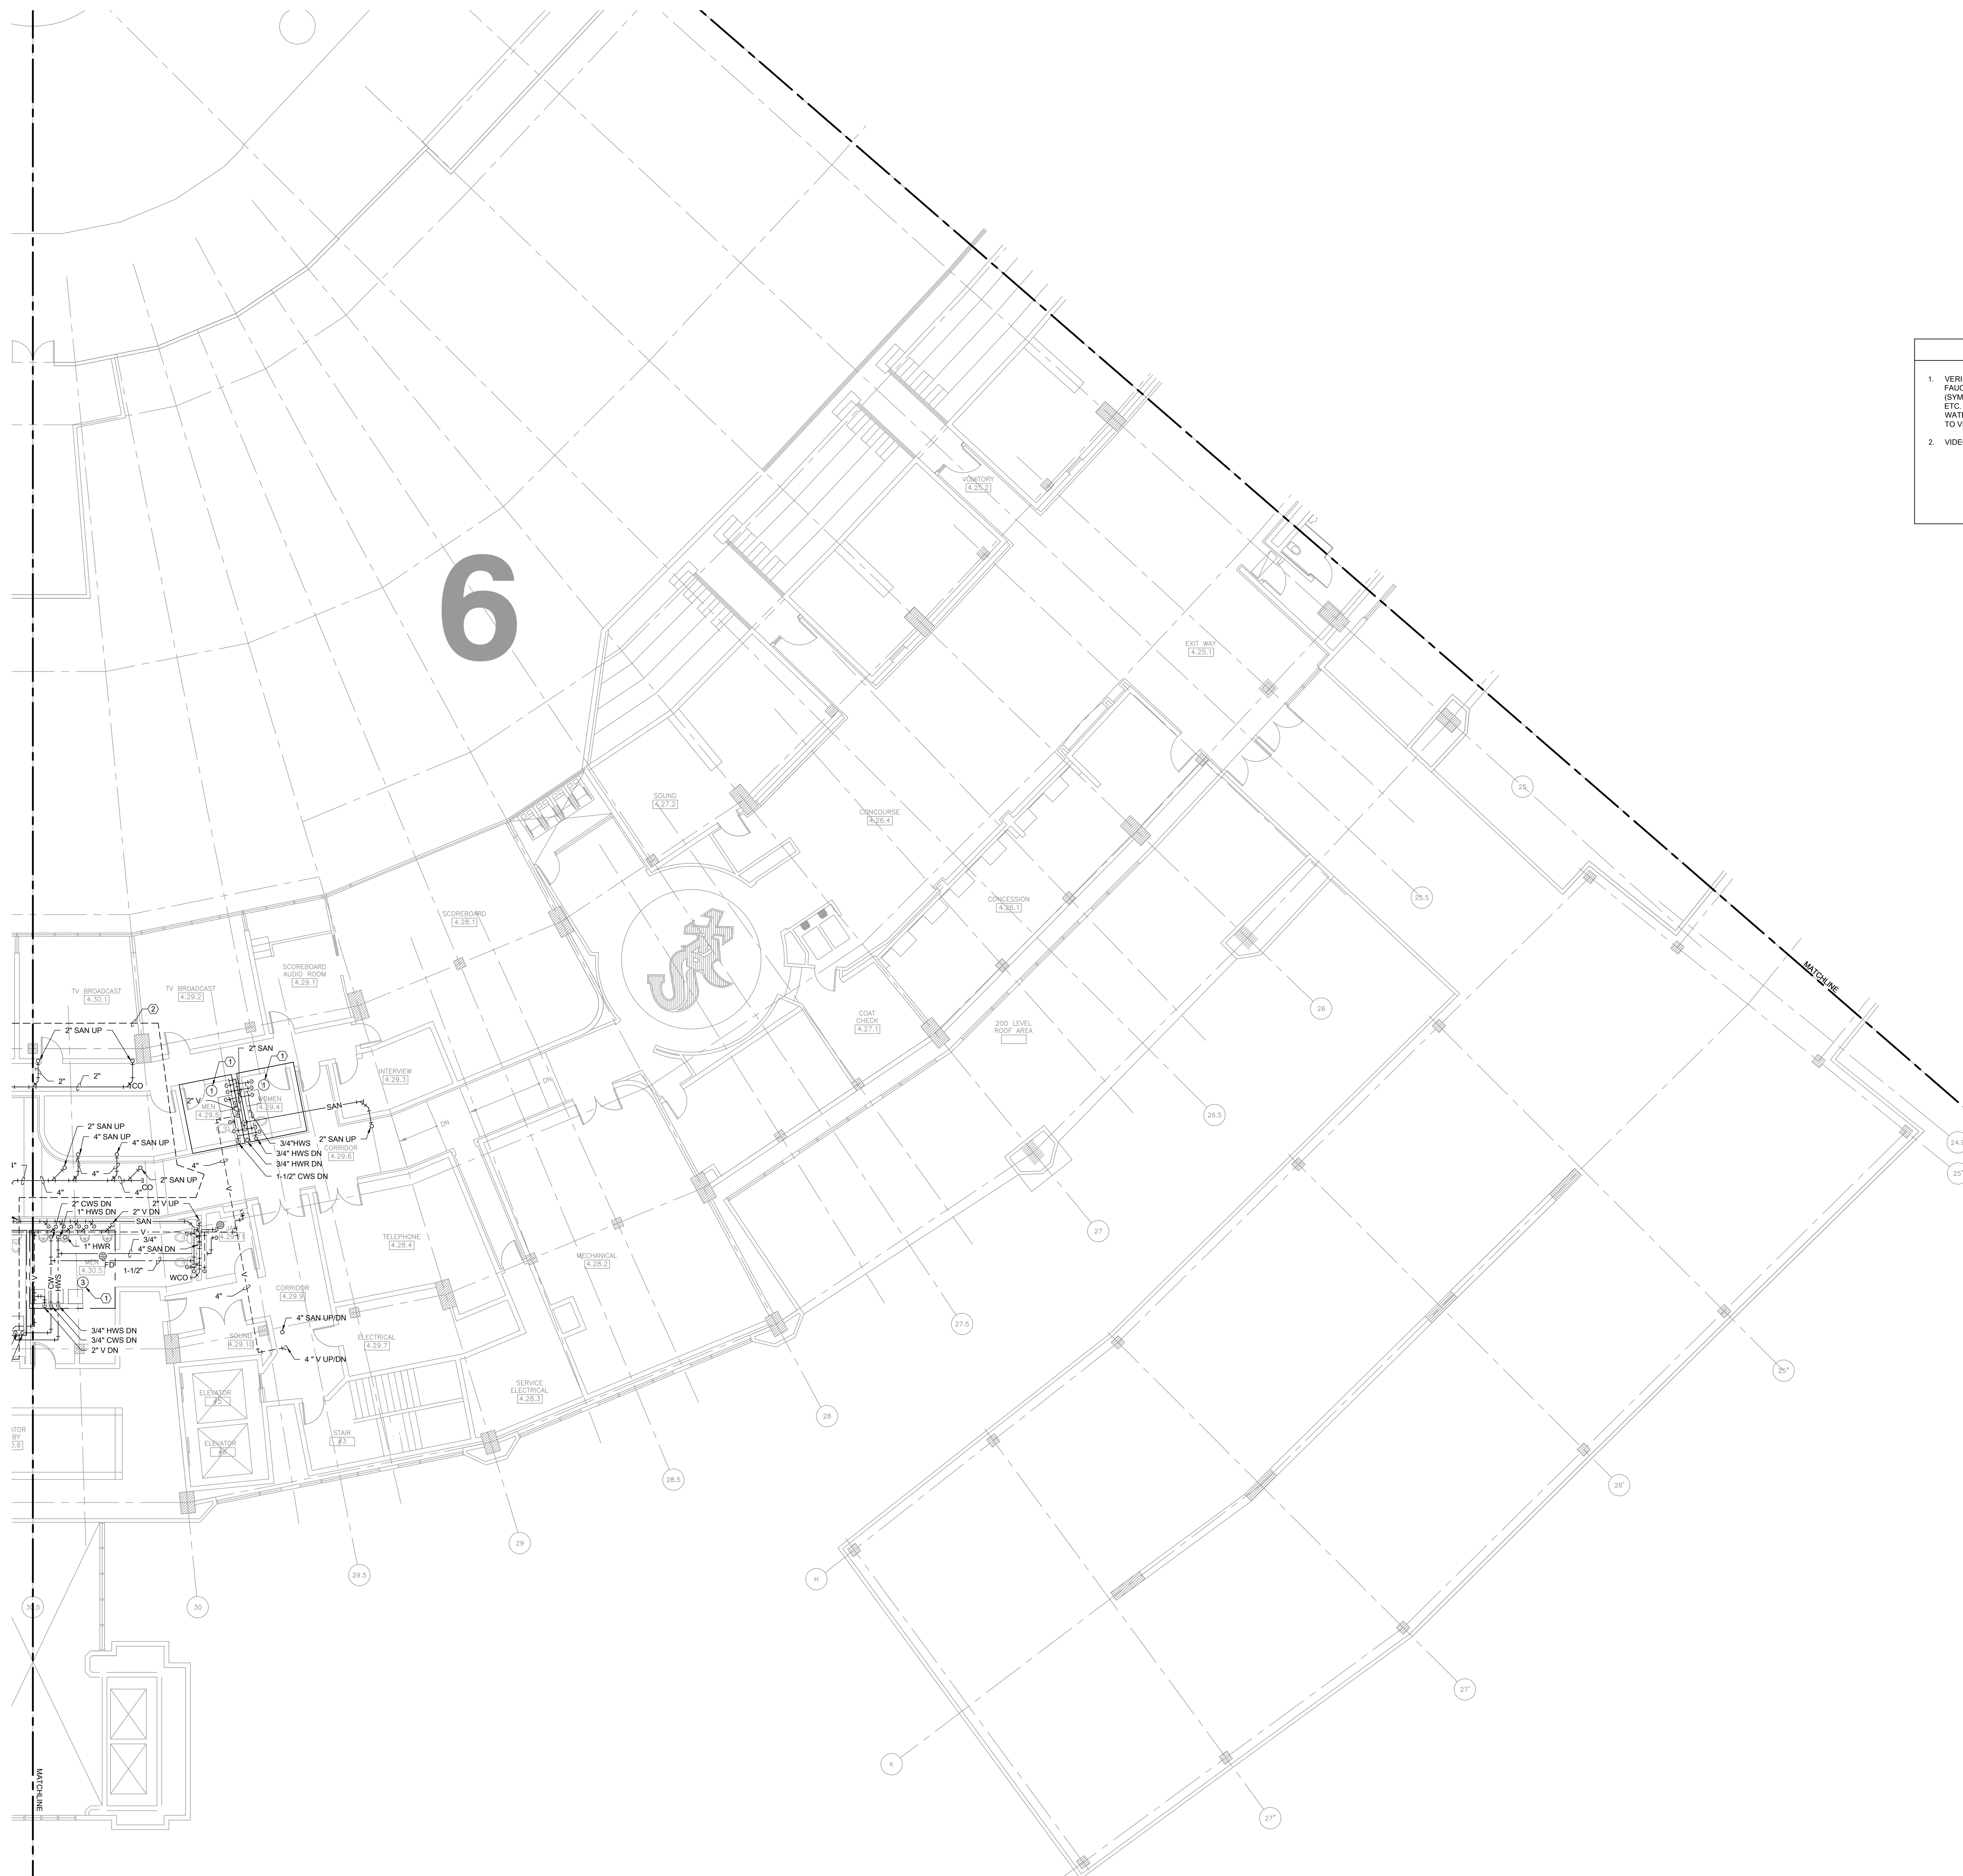

1 PLUMBING PLAN - 300 LEVEL - SECTION 6 ENLARGED
SCALE: 1/8" = 1'-0" 0 4' 8' 16'

Y PLAN:

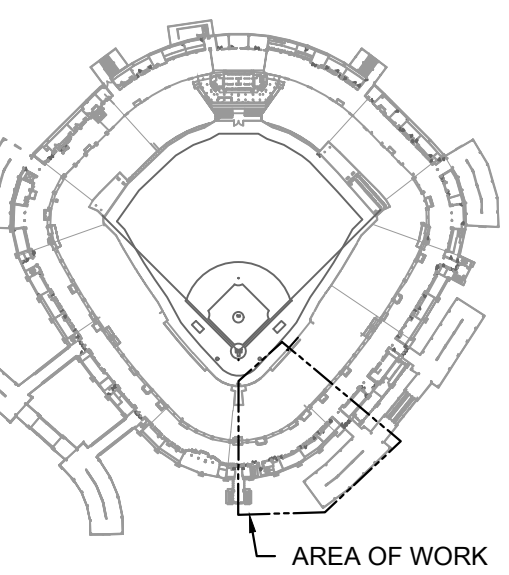

VALUE/REVISION:

[illegible]

PROJECT: GUARANTEED RATE FIELD - WASTE/VENT PIPING FY2026

W 35TH STREET,
CHICAGO, ILLINOIS 60616

DRAWING TITLE:
CLIMBING PLAN - LEVEL 300 -
SECTION 6

SIGNED BY:	CF
CHECKED BY:	MS
OBJECT NO:	25081
SCALE:	1/8" = 1'-0"
SHEET NO.	

P1.306


1. VERIFY LAVATORY FAUCETS. REPLACE OBSOLETE SYMMONS FAUCET MODEL, WHERE OLDER OBSOLETE SYMMONS FAUCET MODEL IS PRESENT, REPLACE THE SYMMONS FAUCET WITH NEW REPLACEMENT SYMMONS FAUCET MODEL (SYMMONS MODEL 569608). REUSE EXISTING NON-FAUCET COMPONENTS SUCH AS WATER SUPPLY STOP VALVES, ETC. PROVIDE ALL NEW WATER SUPPLY TUBING AND NEW ADA PIPE INSULATION FOR P-TRAP, DRAINAGE PIPING, AND WATER PIPING. PROVIDE NEW SYMMONS MODEL 8210CK THERMOSTATIC MIXING VALVE. THE NUMBER OF FAUCETS TO VERIFY IS IDENTIFIED ON PLANS WITH CIRCLE TAG.
2. VIDEO SCOPE OWNER SUITE PIPING.



elaraeng.com | (708) 236-0300



KEY PLAN

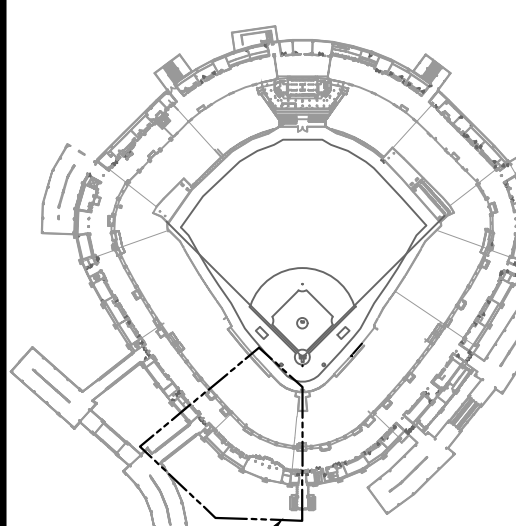

AREA OF WORK

ISSUE/REVISION

[illegible]

PROJECT:

GUARANTEED RATE FIELD -
WASTE/VENT PIPING FY2026

333 W 35TH STREET,
CHICAGO, ILLINOIS 60616

DRAWING TITLE:
PLUMBING PLAN - LEVEL 300
SECTION 7

DESIGNED BY: CE

CHECKED BY:	MS
-------------	----

CHECKED BY:	MG
DATE APPROVED:	2/2/2

PROJECT NO.	2008
SCALE:	1/8"


SHEET NO.

P1.307



KEYED PLUMBING SHEET NOTES

1. VERIFY LAVATORY FAUCET IS OLDER OBSOLETE SYMMONS FAUCET MODEL. WHERE OLDER OBSOLETE SYMMONS FAUCET MODEL IS PRESENT, REPLACE THE SYMMONS FAUCET WITH NEW REPLACEMENT SYMMONS FAUCET MODEL (SYMMONS MODEL S6690B). REUSE EXISTING NON-FAUCET COMPONENTS SUCH AS WATER SUPPLY STOP VALVES, ETC. PROVIDE ALL NEW WATER SUPPLY TUBING AND NEW ADA PIPE INSULATION FOR P-TRAP, DRAINAGE PIPING, AND WATER PIPING. PROVIDE NEW SYMMONS MODEL B210CK THERMOSTATIC MIXING VALVE. THE NUMBER OF FAUCETS TO VERIFY IS IDENTIFIED ON PLANS WITH CIRCLE TAG.

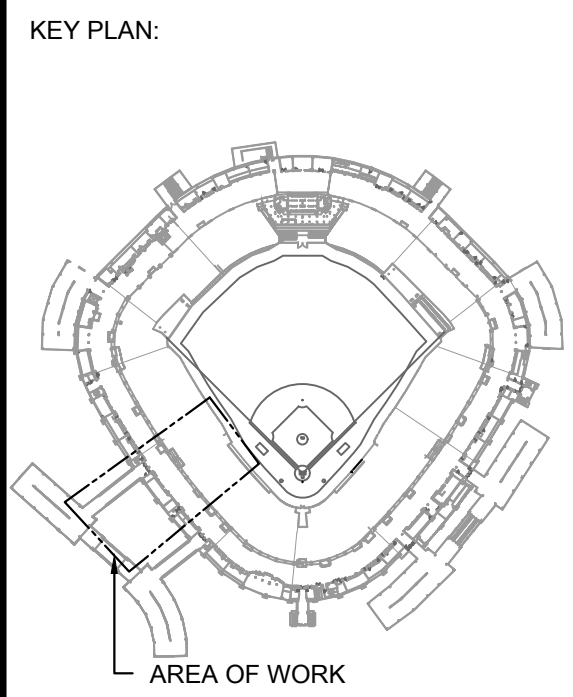

ISSUE/REVISION:		
REV.	DATE	DESCRIPTION
11/14/25		ISSUE FOR BID

PROJECT:
GUARANTEED RATE FIELD -
WASTE/VENT PIPING FY2026

333 W 35TH STREET,
CHICAGO, ILLINOIS 60616

DRAWING TITLE:
PLUMBING PLAN - LEVEL 300 -
SECTION 8

DESIGNED BY:	CF
CHECKED BY:	MS
PROJECT NO:	25081
SCALE:	1/8" = 1'-0"

SHEET NO.
P1.308



P1.309




KEYED PLUMBING SHEET NOTES

1. VERIFY LAVATORY FAUCET IS OLDER OBSOLETE SYMMONS FAUCET MODEL. WHERE OLDER OBSOLETE SYMMONS FAUCET MODEL IS PRESENT, REPLACE THE SYMMONS FAUCET WITH NEW REPLACEMENT SYMMONS FAUCET MODEL (SYMMONS MODEL 568606). REUSE EXISTING NON-FAUCET COMPONENTS SUCH AS WATER SUPPLY STOP VALVES, ETC. PROVIDE ALL NEW WATER SUPPLY TUBING AND NEW ADA PIPE INSULATION FOR P-TRAP, DRAINAGE PIPING, AND WATER PIPING. PROVIDE NEW SYMMONS MODEL 8210CK THERMOSTATIC MIXING VALVE. THE NUMBER OF FAUCETS TO VERIFY IS IDENTIFIED ON PLANS WITH CIRCLE TAG.
2. PROVIDE NEW 3/4" DHWR PIPING FROM END OF THE DHWS PIPING TO THE LAST SINK TO IMPROVE THE HOT WATER DELIVERY TO THE KITCHEN AND FOOD PREP AREA. INSULATE PIPING AND PROVIDE NEW HOT WATER RETURN BALANCING STATION.

1 PLUMBING PLAN - 400 LEVEL - SECTION 4 ENLARGED

KEY PLAN:

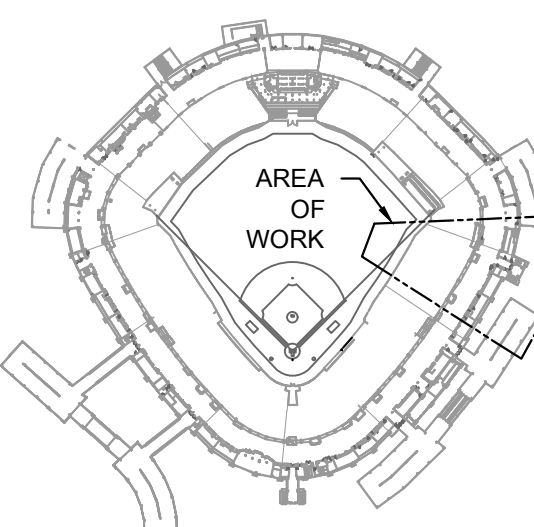

ISSUE/REVISION:

REV.	DATE	DESCRIPTION
11/14/25		ISSUE FOR BID

PROJECT:
GUARANTEED RATE FIELD -
WASTE/VENT PIPING FY2026

333 W 35TH STREET,
CHICAGO, ILLINOIS 60616

DRAWING TITLE:
PLUMBING PLAN - LEVEL 400 -
SECTION 4

DESIGNED BY: CF
CHECKED BY: MS
PROJECT NO: 25081
SCALE: 1/8" = 1'-0"


SHEET NO.



KEYED PLUMBING SHEET NOTES

1. VERIFY LAVATORY FAUCET IS OLDER OBSOLETE SYMMONS FAUCET MODEL. WHERE OLDER OBSOLETE SYMMONS FAUCET MODEL IS PRESENT, REPLACE THE SYMMONS FAUCET WITH NEW REPLACEMENT SYMMONS FAUCET MODEL (SYMMONS MODEL S666B). REUSE EXISTING NON-FAUCET COMPONENTS SUCH AS WATER SUPPLY STOP VALVES, ETC. PROVIDE ALL NEW WATER SUPPLY TUBING AND NEW ADA PIPE INSULATION FOR P-TRAP, DRAINAGE PIPING, AND WATER PIPING. PROVIDE NEW SYMMONS MODEL S210CK THERMOSTATIC MIXING VALVE. THE NUMBER OF FAUCETS TO VERIFY IS IDENTIFIED ON PLANS WITH CIRCLE TAG.

1 PLUMBING PLAN - 400 LEVEL - SECTION 5 ENLARGED

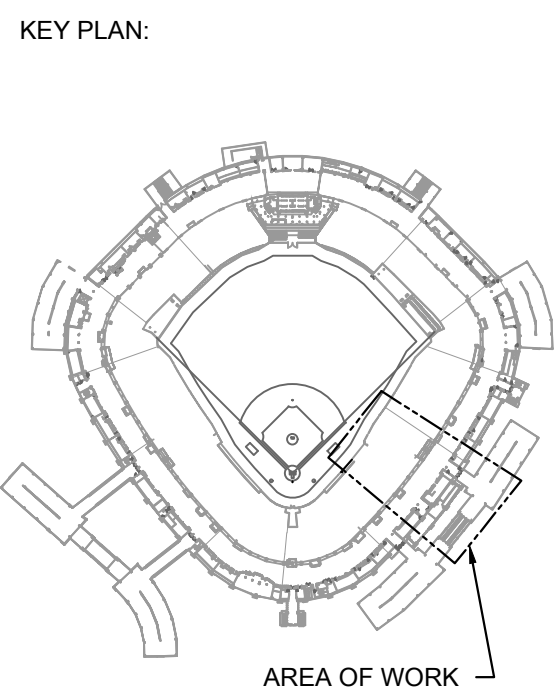

ISSUE/REVISION:		
REV.	DATE	DESCRIPTION
11/14/25		ISSUE FOR BID

PROJECT:
GUARANTEED RATE FIELD -
WASTE/VENT PIPING FY2026

333 W 35TH STREET,
CHICAGO, ILLINOIS 60616

 
DRAWING TITLE:
PLUMBING PLAN - LEVEL 400 -
SECTION 5

DESIGNED BY: CF
CHECKED BY: MS
PROJECT NO: 25081
SCALE: 1/8" = 1'-0"

SHEET NO.
P1.405



1 SCALE: 1/8" = 1'-0" 0 4' 8' 16'



1. VERIFY LAVATORY FAUCET IS OLDER OBSOLETE SYMONS FAUCET MODEL. WHERE OLDER OBSOLETE SYMONS FAUCET MODEL IS PRESENT, REPLACE THE SYMONS FAUCET WITH NEW REPLACEMENT SYMONS FAUCET MODEL (SYMONS MODEL S69060). REUSE EXISTING NON-FAUCET COMPONENTS SUCH AS WATER SUPPLY STOP VALVES, ETC. PROVIDE ALL NEW WATER SUPPLY TUBING AND NEW ADA PIPE INSULATION FOR P-TRAP, DRAINAGE PIPING, AND WATER PIPING. PROVIDE NEW SYMONS MODEL 8210CK THERMOSTATIC MIXING VALVE. THE NUMBER OF FAUCETS TO VERIFY IS IDENTIFIED ON PLANS WITH CIRCLE TAG.
2. VIDEO SCOPE OWNER SUITE PIPING.

A schematic diagram of a stadium seating arrangement. The diagram shows a diamond-shaped field in the center, surrounded by tiered seating. A dashed line outlines a specific section of the seating area at the bottom, which is labeled "AREA OF WORK".

[illegible]

333 W 35TH STREET,
CHICAGO, ILLINOIS 60616

DRAWING TITLE:
PLUMBING PLAN - LEVEL 400 -
SECTION 6

DESIGNED BY:	CF
CHECKED BY:	MS
PROJECT NO:	25081
SCALE:	1/8" = 1'-0"

P1.406



KEYED PLUMBING SHEET NOTES

1.

VERIFY LAVATORY FAUCET IS OLDER OBSOLETE SYMMONS FAUCET MODEL. WHERE OLDER OBSOLETE SYMMONS FAUCET MODEL IS PRESENT, REPLACE THE SYMMONS FAUCET WITH NEW REPLACEMENT SYMMONS FAUCET MODEL (SYMMONS MODEL 58606). REUSE EXISTING NON-FAUCET COMPONENTS SUCH AS WATER SUPPLY STOP VALVES, ETC. PROVIDE ALL NEW WATER SUPPLY TUBING AND NEW ADA PIPE INSULATION FOR P-TRAP, DRAINAGE PIPING, AND WATER PIPING. PROVIDE NEW SYMMONS MODEL 6210CK THERMOSTATIC MIXING VALVE. THE NUMBER OF FAUCETS TO VERIFY IS IDENTIFIED ON PLANS WITH CIRCLE TAG.

2.

VIDEO SCOPE OWNER SUITE PIPING.

1 PLUMBING PLAN - 400 LEVEL - SECTION 7 ENLARGED




elaraeng.com | (708) 236-0300



INLAND SPOKES
FACILITIES AUTHORITY



KEY PLAN:

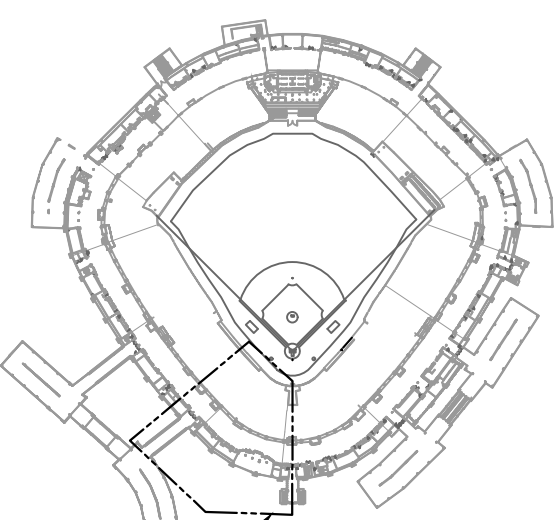

AREA OF WORK:

ISSUE/REVISION:		
REV.	DATE	DESCRIPTION
11/14/25		ISSUE FOR BID

PROJECT:
GUARANTEED RATE FIELD -
WASTE/VENT PIPING FY2026

333 W 35TH STREET,
CHICAGO, ILLINOIS 60616

DRAWING TITLE:
PLUMBING PLAN - LEVEL 400 -
SECTION 7

DESIGNED BY: CF
CHECKED BY: MS
PROJECT NO: 25081
SCALE: 1/8" = 1'-0"
SHEET NO.

P1.407




1 PLUMBING PLAN - 400 LEVEL - SECTION 8 ENLARGED

SCALE: 1/8" = 1'-0" 0 2 4 6 8 10

KEYED PLUMBING SHEET NOTES

1. VERIFY LAVATORY FAUCET IS OLDER OBSOLETE SYMMONS FAUCET MODEL. WHERE OLDER OBSOLETE SYMMONS FAUCET MODEL IS PRESENT, REPLACE THE SYMMONS FAUCET WITH NEW REPLACEMENT SYMMONS FAUCET MODEL (SYMMONS MODEL S69608). REUSE EXISTING NON-FAUCET COMPONENTS SUCH AS WATER SUPPLY STOP VALVES, ETC. PROVIDE ALL NEW WATER SUPPLY TUBING AND NEW ADA PIPE INSULATION FOR P-TRAP, DRAINAGE PIPING, AND WATER PIPING. PROVIDE NEW SYMMONS MODEL B210CK THERMOSTATIC MIXING VALVE. THE NUMBER OF FAUCETS TO VERIFY IS IDENTIFIED ON PLANS WITH CIRCLE TAG.

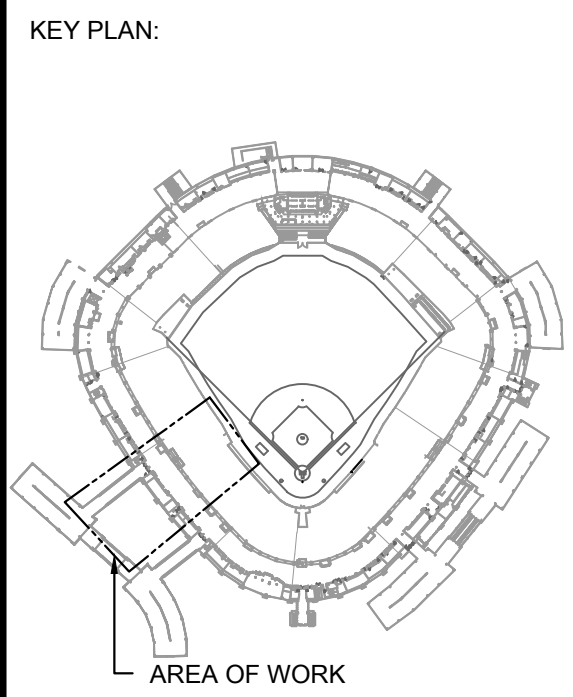

ISSUE/REVISION:		
REV.	DATE	DESCRIPTION
11/14/25		ISSUE FOR BID

PROJECT: GUARANTEED RATE FIELD - WASTE/VENT PIPING FY2026	
333 W 35TH STREET, CHICAGO, ILLINOIS 60616	
DRAWING TITLE: PLUMBING PLAN - LEVEL 400 - SECTION 8	
DESIGNED BY:	CF
CHECKED BY:	MS
PROJECT NO:	25081
SCALE:	1/8" = 1'-0"
SHEET NO.	



KEYED PLUMBING SHEET NOTES


1. VERIFY LAVATORY FAUCET IS OLDER OBSOLETE SYMMONS FAUCET MODEL. WHERE OLDER OBSOLETE SYMMONS FAUCET MODEL IS PRESENT, REPLACE THE SYMMONS FAUCET WITH NEW REPLACEMENT SYMMONS FAUCET MODEL (SYMMONS MODEL S6960B). REUSE EXISTING NON-FAUCET COMPONENTS SUCH AS WATER SUPPLY STOP VALVES, ETC. PROVIDE ALL NEW WATER SUPPLY TUBING AND NEW ADA PIPE INSULATION FOR P-TRAP, DRAINAGE PIPING, AND WATER PIPING. PROVIDE NEW SYMMONS MODEL 8210CK THERMOSTATIC MIXING VALVE. THE NUMBER OF FAUCETS TO VERIFY IS IDENTIFIED ON PLANS WITH CIRCLE TAG.

1 PLUMBING PLAN - 400 LEVEL - SECTION 9 ENLARGED

SCALE: 1/8" = 1'-0"

0 2 4 8 16

North Arrow

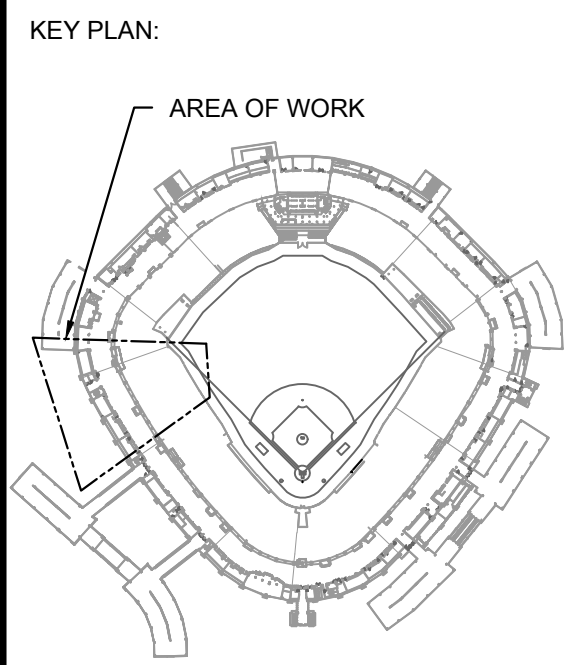

ISSUE/REVISION:		
REV.	DATE	DESCRIPTION
11/14/25		ISSUE FOR BID

PROJECT:
GUARANTEED RATE FIELD -
WASTE/VENT PIPING FY2026


333 W 35TH STREET,
CHICAGO, ILLINOIS 60616

DRAWING TITLE:
PLUMBING PLAN - LEVEL 400 -
SECTION 9

DESIGNED BY:	CF
CHECKED BY:	MS
PROJECT NO:	25081
SCALE:	1/8" = 1'-0"

SHEET NO.


P1.409

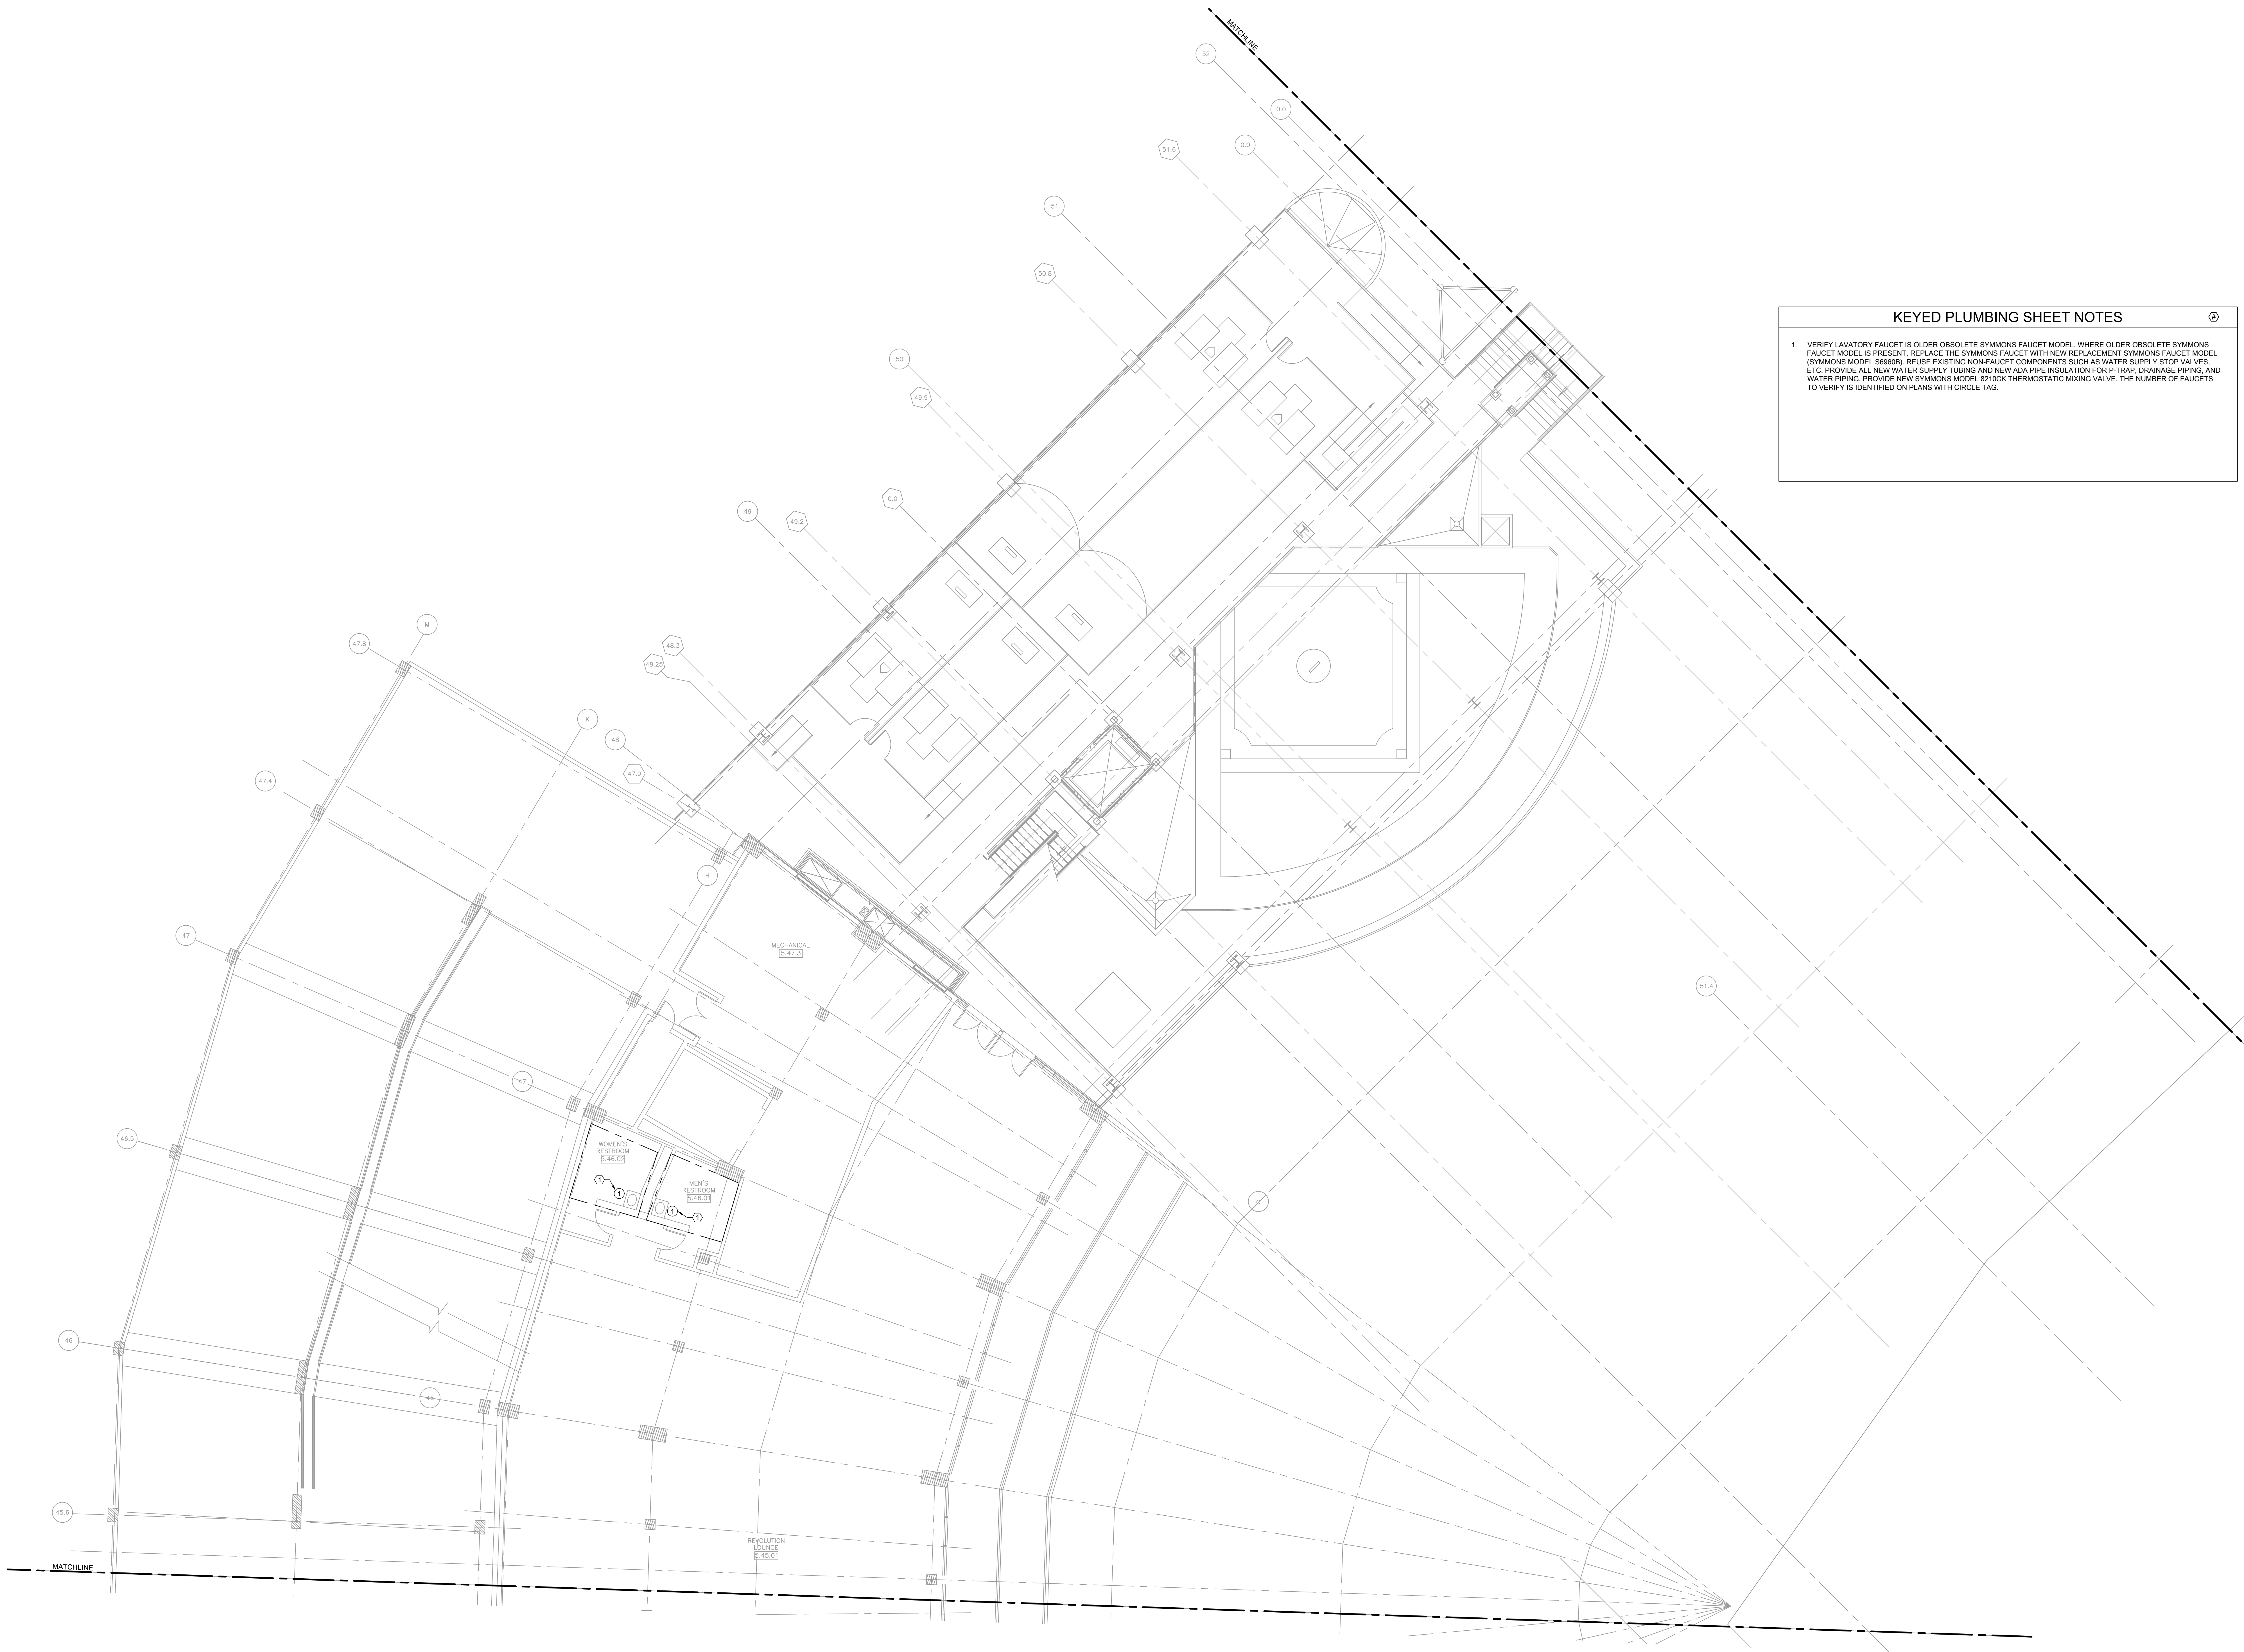

KEYED PLUMBING SHEET NOTES

1. VERIFY LAVATORY FAUCET IS OLDER OBSOLETE SYMMONS FAUCET MODEL. WHERE OLDER OBSOLETE SYMMONS FAUCET MODEL IS PRESENT, REPLACE THE SYMMONS FAUCET WITH NEW REPLACEMENT SYMMONS FAUCET MODEL (SYMMONS MODEL S8980B). REUSE EXISTING NON-FAUCET COMPONENTS SUCH AS WATER SUPPLY STOP VALVES, ETC. PROVIDE ALL NEW WATER SUPPLY TUBING AND NEW ADA PIPE INSULATION FOR P-TRAP, DRAINAGE PIPING, AND WATER PIPING. PROVIDE NEW SYMMONS MODEL S210CK THERMOSTATIC MIXING VALVE. THE NUMBER OF FAUCETS TO VERIFY IS IDENTIFIED ON PLANS WITH CIRCLE TAG.

1 PLUMBING PLAN - 400 LEVEL - SECTION 10 ENLARGED

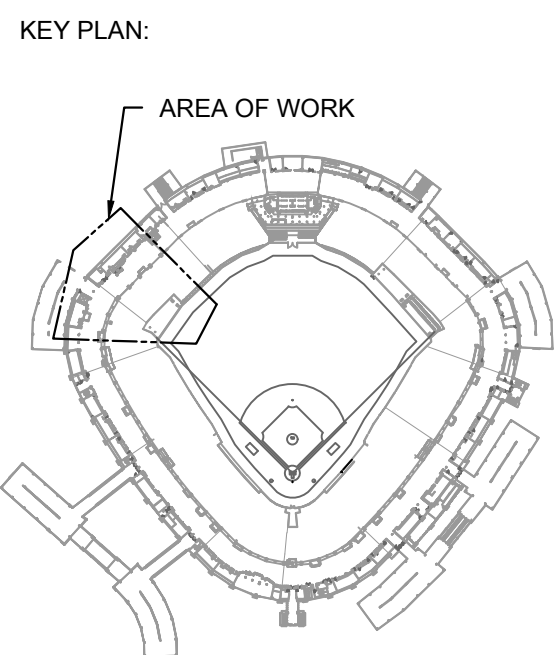

ISSUE/REVISION:

REV.	DATE	DESCRIPTION
11/14/25		ISSUE FOR BID



PROJECT:
GUARANTEED RATE FIELD -
WASTE/VENT PIPING FY2026

333 W 35TH STREET,
CHICAGO, ILLINOIS 60616

DRAWING TITLE:
PLUMBING PLAN - LEVEL 400 -
SECTION 10

DESIGNED BY: CF
CHECKED BY: MS
PROJECT NO: 25081
SCALE: 1/8" = 1'-0"

SHEET NO.
P1.410

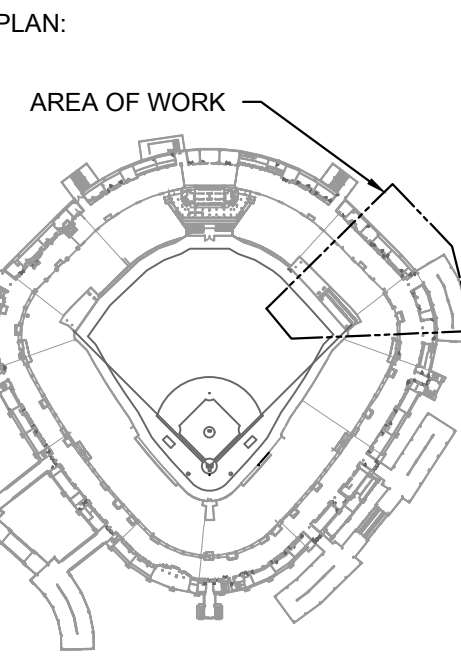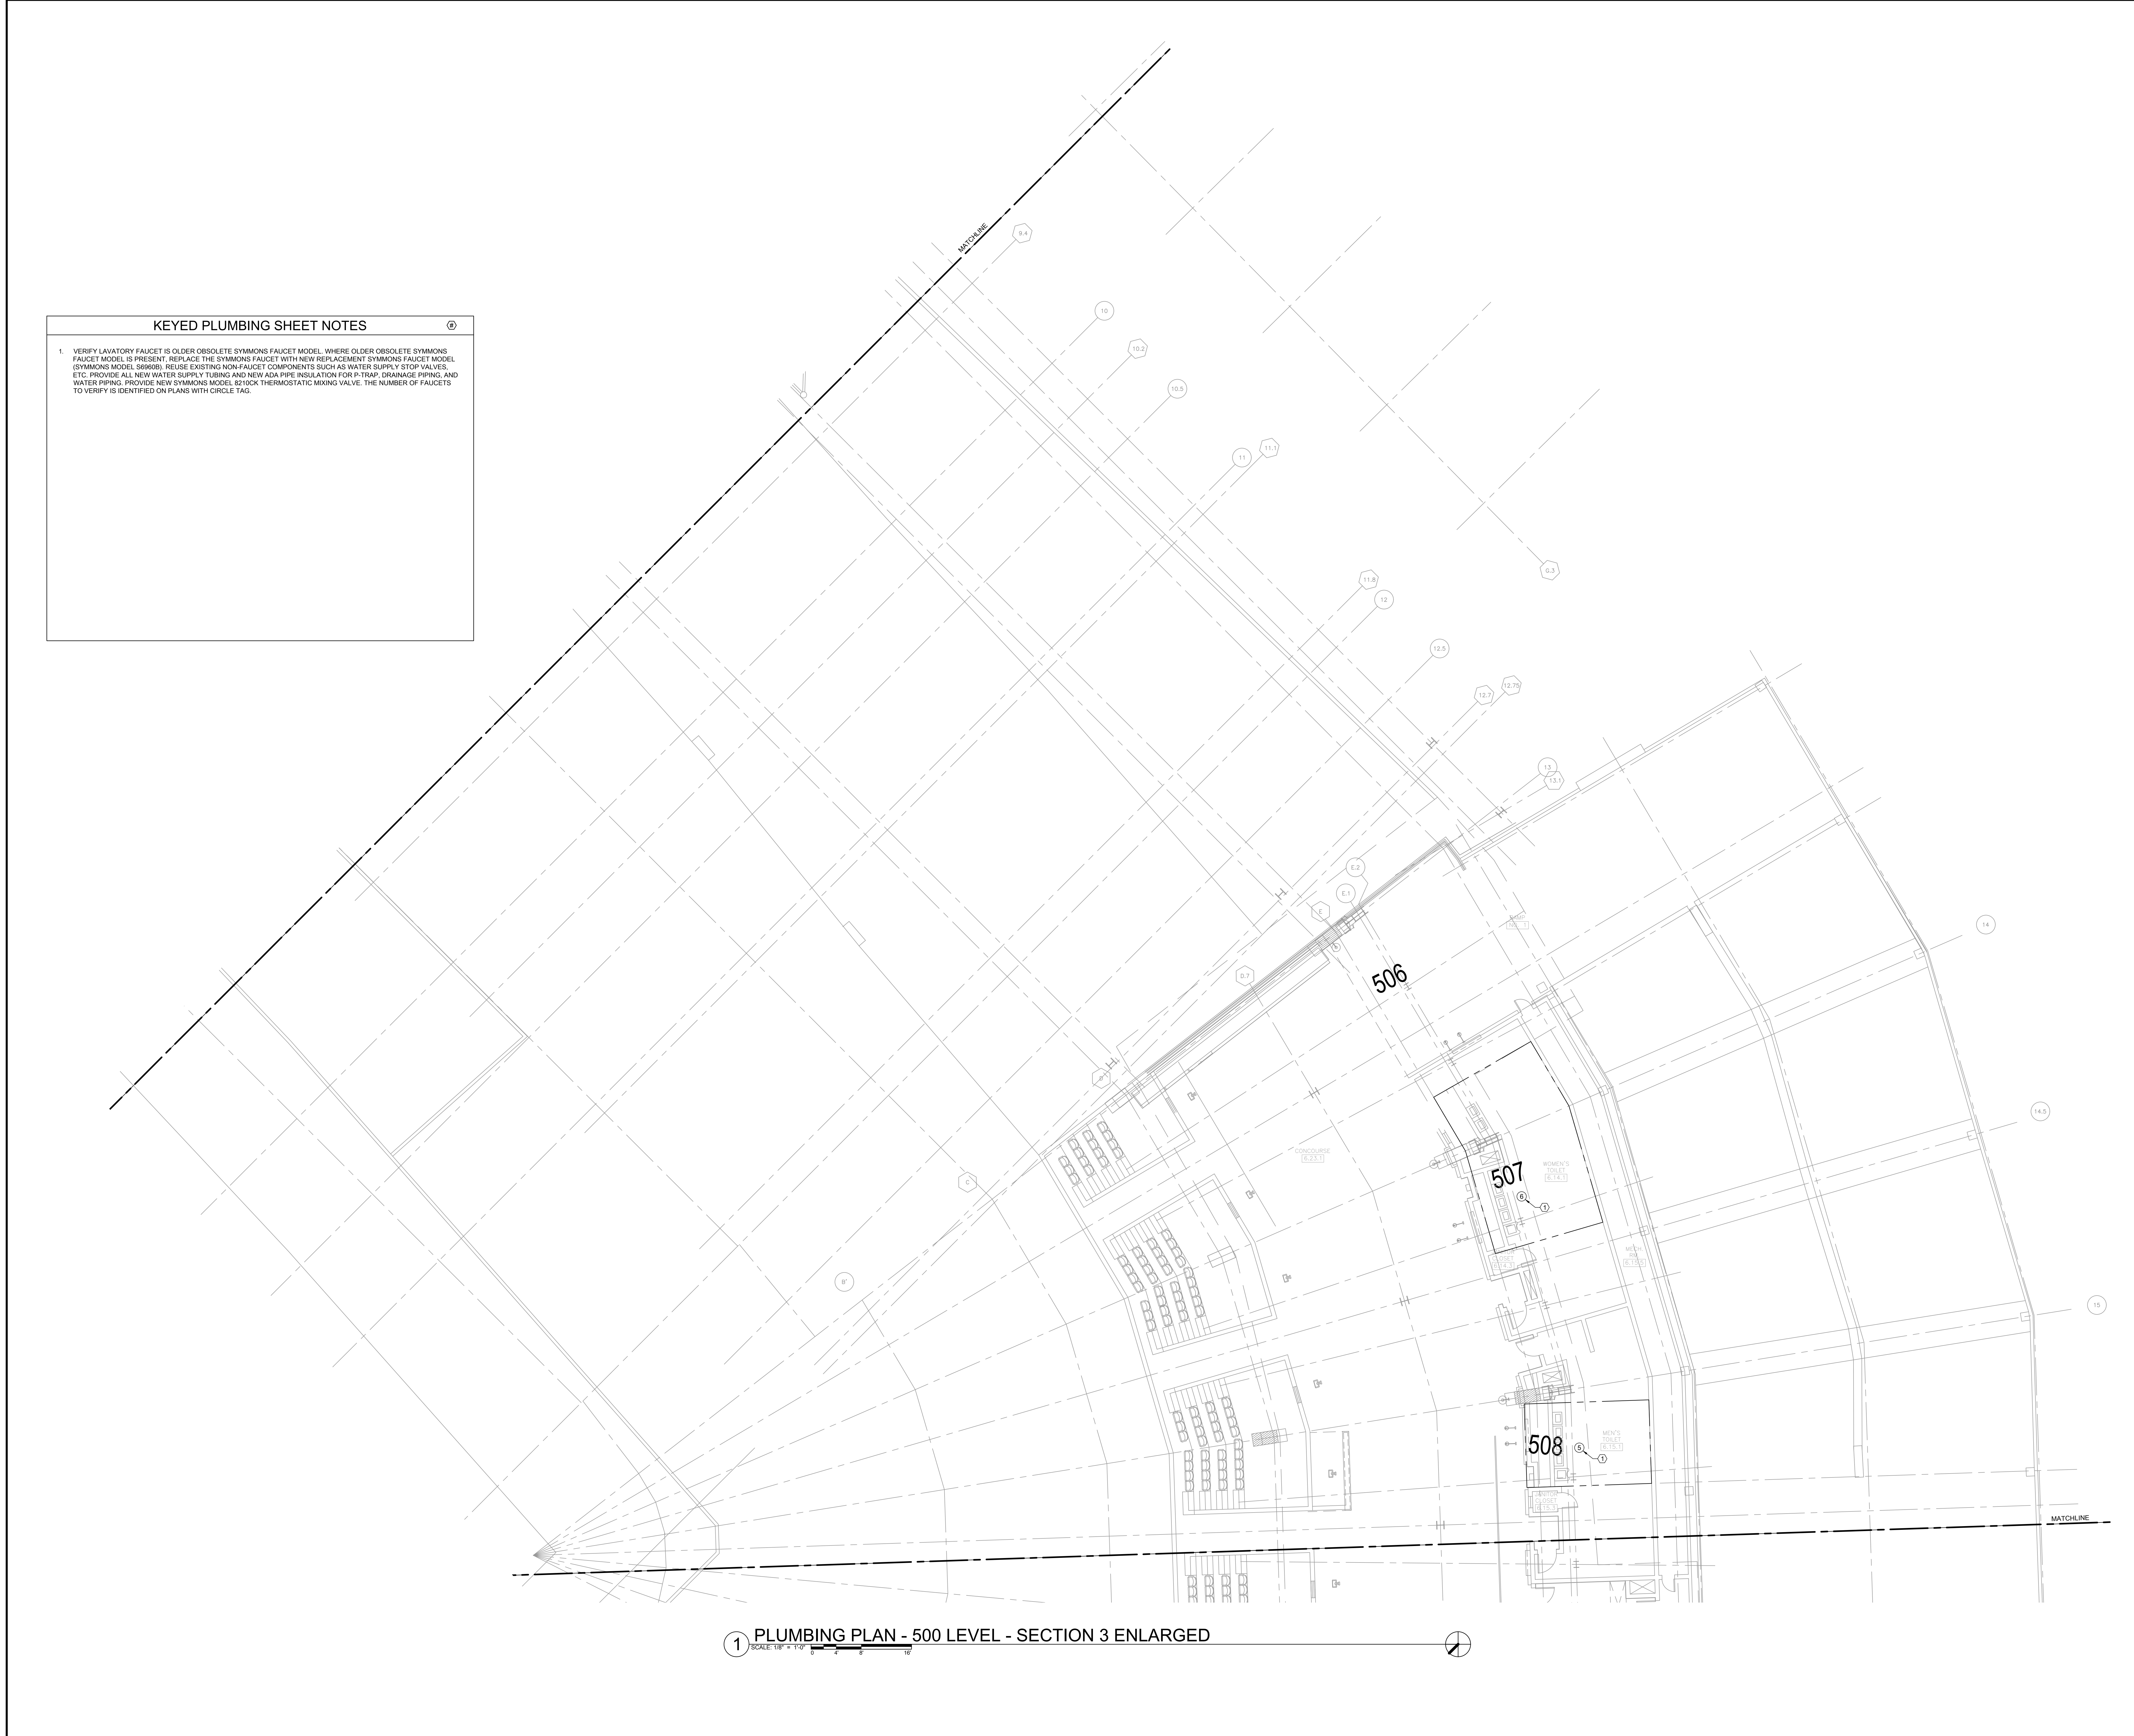[illegible]

735TH STREET,
CHICAGO, ILLINOIS 60616

DESIGNED BY:	CF
DRAWN BY:	MS
PROJECT NO:	25081
SCALE:	1/8" = 1'-0"




KEYED PLUMBING SHEET NOTES

1. VERIFY LAVATORY FAUCET IS OLDER OBSOLETE SYMMONS FAUCET MODEL, WHERE OLDER OBSOLETE SYMMONS FAUCET MODEL IS PRESENT, REPLACE THE SYMMONS FAUCET WITH NEW REPLACEMENT SYMMONS FAUCET MODEL (SYMMONS MODEL 566666). REUSE EXISTING NON-FAUCET COMPONENTS SUCH AS WATER SUPPLY STOP VALVES, ETC. PROVIDE ALL NEW WATER SUPPLY TUBING AND NEW ADA PIPE INSULATION FOR P-TRAP, DRAINAGE PIPING, AND WATER PIPING. PROVIDE NEW SYMMONS MODEL 8210CK THERMOSTATIC MIXING VALVE. THE NUMBER OF FAUCETS TO VERIFY IS IDENTIFIED ON PLANS WITH CIRCLE TAG.

1 PLUMBING PLAN - 500 LEVEL - SECTION 4 ENLARGED

KEY PLAN:

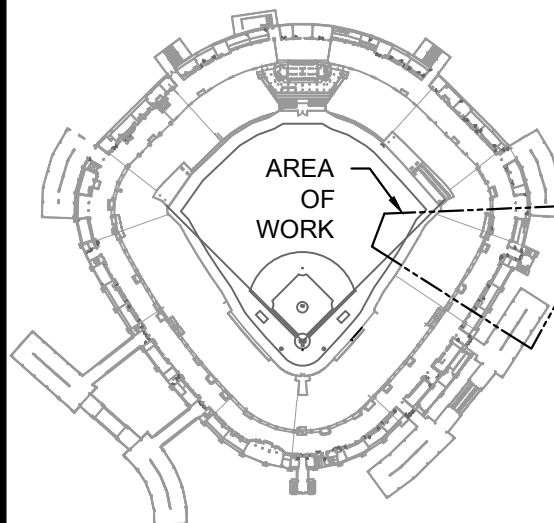

ISSUE/REVISION:

REV.	DATE	DESCRIPTION
11/14/25		ISSUE FOR BID

PROJECT:
GUARANTEED RATE FIELD -
WASTE/VENT PIPING FY2026

333 W 35TH STREET,
CHICAGO, ILLINOIS 60616

DRAWING TITLE:
PLUMBING PLAN - LEVEL 500 -
SECTION 4

DESIGNED BY: CF
CHECKED BY: MS
PROJECT NO: 25081
SCALE: 1/8" = 1'-0"

SHEET NO.



1. VERIFY LAVATORY FAUCET IS OLDER OBSOLETE SYMONS FAUCET MODEL. WHERE OLDER OBSOLETE SYMONS FAUCET MODEL IS PRESENT, REPLACE THE SYMONS FAUCET WITH NEW REPLACEMENT SYMONS FAUCET MODEL (SYMONS MODEL S6606B). REUSE EXISTING NON-FAUCET COMPONENTS SUCH AS WATER SUPPLY STOP VALVES, ETC. PROVIDE ALL NEW WATER SUPPLY TUBING AND NEW ADA PIPE INSULATION FOR P-TRAP, DRAINAGE PIPING, AND WATER PIPING. PROVIDE NEW SYMONS MODEL 8210CK THERMOSTATIC MIXING VALVE. THE NUMBER OF FAUCETS TO VERIFY IS IDENTIFIED ON PLANS WITH CIRCLE TAG.

A diagram of the stadium seating area, showing the field and the stands. A rectangular area in the lower right section of the stands is outlined with a dashed line and labeled "AREA OF WORK".


[illegible]

W 35TH STREET,
CHICAGO, ILLINOIS 60616

SHEET NO. _____

P1.505

1 PLUMBING PLAN - 500 LEVEL - SECTION 5 ENLARGED

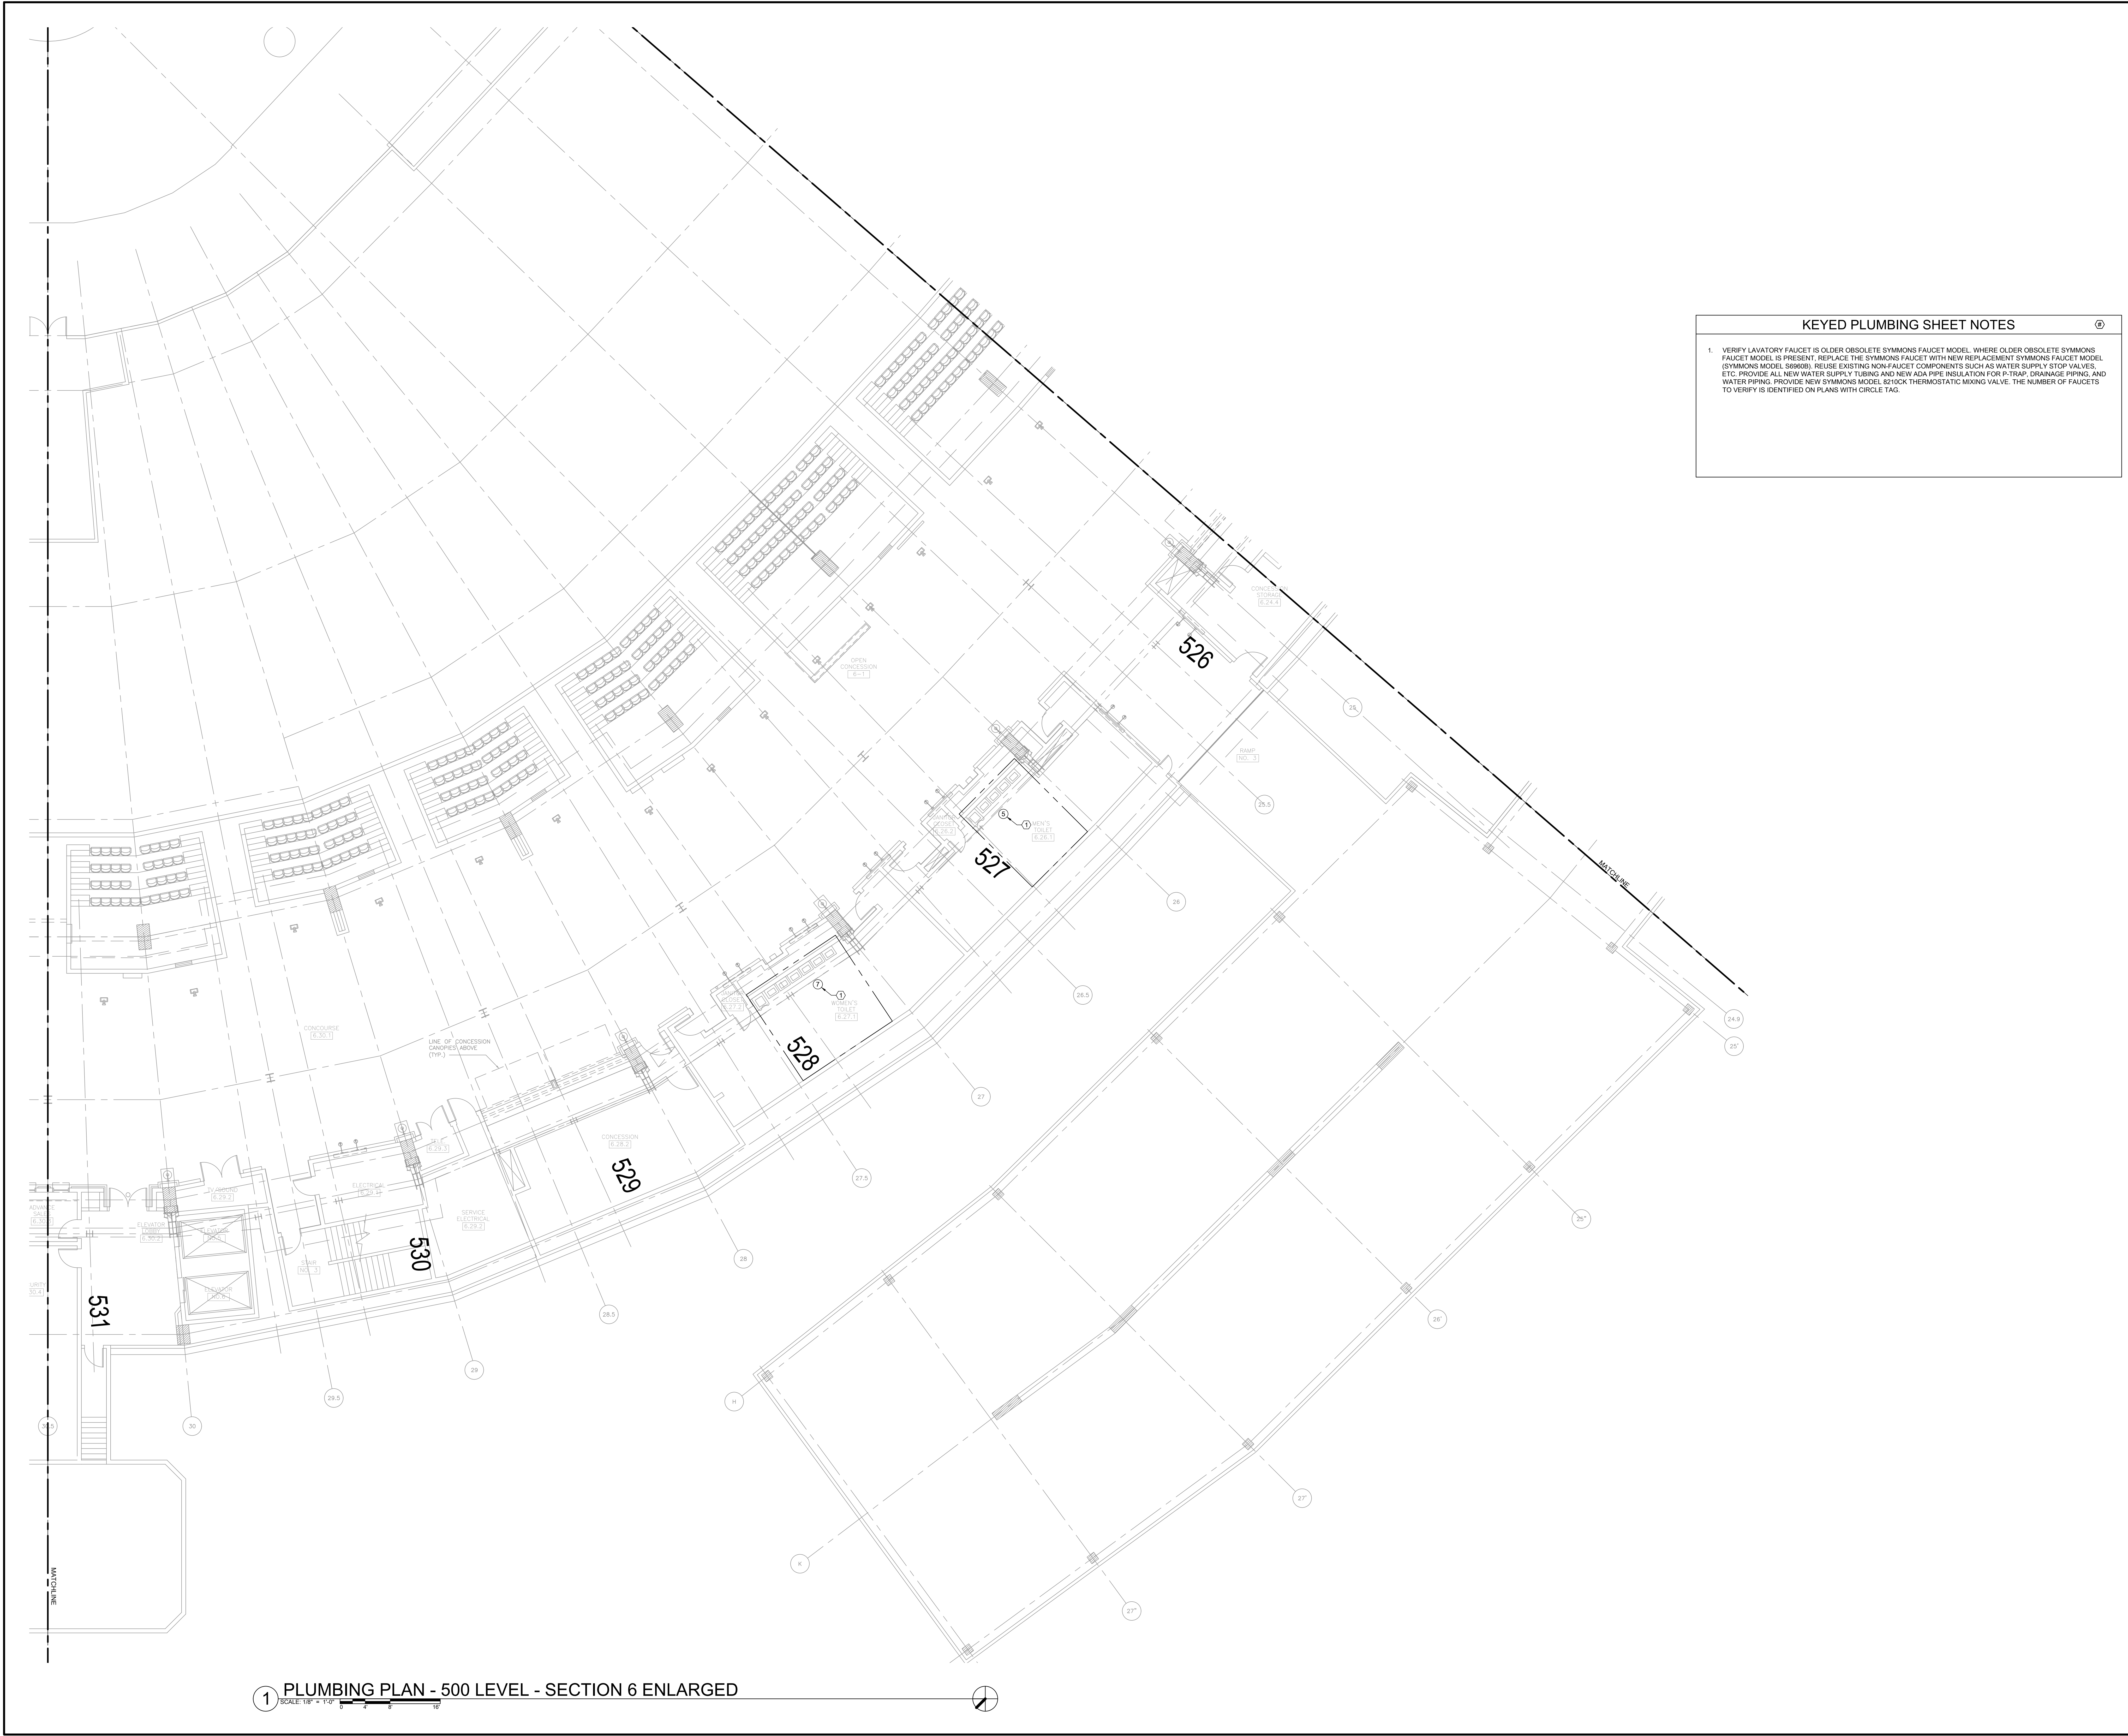

KEYED PLUMBING SHEET NOTES

1. VERIFY LAVATORY FAUCET IS OLDER OBSOLETE SYMMONS FAUCET MODEL. WHERE OLDER OBSOLETE SYMMONS FAUCET MODEL IS PRESENT, REPLACE THE SYMMONS FAUCET WITH NEW REPLACEMENT SYMMONS FAUCET MODEL (SYMMONS MODEL 8668B). REUSE EXISTING NON-FAUCET COMPONENTS SUCH AS WATER SUPPLY STOP VALVES, ETC. PROVIDE ALL NEW WATER SUPPLY TUBING AND NEW ADA PIPE INSULATION FOR P-TRAP, DRAINAGE PIPING, AND WATER PIPING. PROVIDE NEW SYMMONS MODEL 82100K THERMOSTATIC MIXING VALVE. THE NUMBER OF FAUCETS TO VERIFY IS IDENTIFIED ON PLANS WITH CIRCLE TAG.




elaraeng.com | (708) 236-0300



ILLINOIS SPORTS FACILITIES AUTHORITY

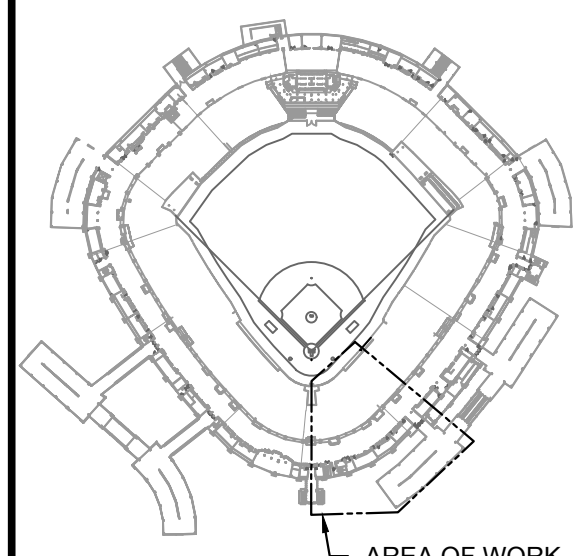

KEY PLAN:

ISSUE/REVISION:

REV.	DATE	DESCRIPTION
1	11/14/25	ISSUE FOR BID

PROJECT:

GUARANTEED RATE FIELD - WASTE/VENT PIPING FY2026

333 W 35TH STREET, CHICAGO, ILLINOIS 60616

DRAWING TITLE:

PLUMBING PLAN - LEVEL 500 - SECTION 6

DESIGNED BY: CF
CHECKED BY: MS
PROJECT NO: 25081
SCALE: 1/8" = 1'-0"

SHEET NO:


P1.506



1. VERIFY LAVATORY FAUCETS IS OLDER OBSOLETE SYMMONS FAUCET MODEL. WHERE OLDER OBSOLETE SYMMONS FAUCET MODEL IS PRESENT, REPLACE THE SYMMONS FAUCET WITH NEW REPLACEMENT SYMMONS FAUCET MODEL SYMMONS MODEL 569600. REUSE EXISTING NON-FAUCET COMPONENTS SUCH AS WATER SUPPLY STOP VALVES, ETC. PROVIDE ALL NEW WATER SUPPLY TUBING AND NEW ADA PIPE INSULATION FOR P-TRAP, DRAINAGE PIPING, AND WATER PIPING. PROVIDE NEW SYMMONS MODEL 8210CK THERMOSTATIC MIXING VALVE. THE NUMBER OF FAUCETS TO VERIFY IS IDENTIFIED ON PLANS WITH CIRCLE TAG.



KEY PLAN:

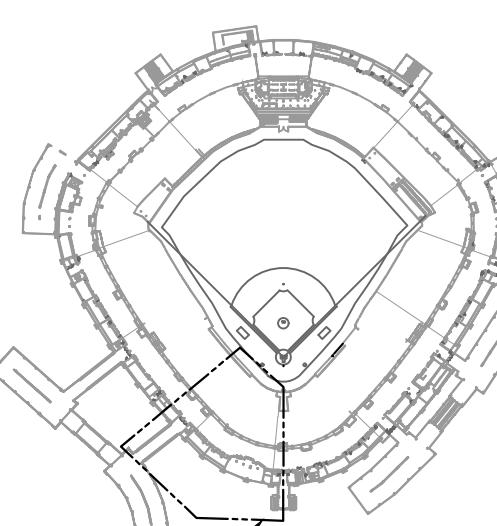

AREA OF WORK

[illegible]

PROJECT:
GUARANTEED RATE FIELD -
WASTE/VENT PIPING FY2026

333 W 35TH STREET,
CHICAGO, ILLINOIS 60616

DRAWING TITLE:

PLUMBING PLAN - LEVEL 500
SECTION 7

DESIGNED BY:	CF
CHECKED BY:	MS
PROJECT NO:	25081
SCALE:	1/8" = 1'-0"

SHEET NO.

P1.507



KEYED PLUMBING SHEET NOTES

1.

VERIFY LAVATORY FAUCET IS OLDER OBSOLETE SYMMONS FAUCET MODEL. WHERE OLDER OBSOLETE SYMMONS FAUCET MODEL IS PRESENT, REPLACE THE SYMMONS FAUCET WITH NEW REPLACEMENT SYMMONS FAUCET MODEL (SYMMONS MODEL S6908B). REUSE EXISTING NON-FAUCET COMPONENTS SUCH AS WATER SUPPLY STOP VALVES, ETC. PROVIDE ALL NEW WATER SUPPLY TUBING AND NEW ADA PIPE INSULATION FOR P-TRAP, DRAINAGE PIPING, AND WATER PIPING. PROVIDE NEW SYMMONS MODEL B210CK THERMOSTATIC MIXING VALVE. THE NUMBER OF FAUCETS TO VERIFY IS IDENTIFIED ON PLANS WITH CIRCLE TAG.

1 PLUMBING PLAN - 500 LEVEL - SECTION 8 ENLARGED


SCALE: 1/8" = 1'-0"



1 PLUMBING PLAN - 500 LEVEL - SECTION 9 ENLARGED
SCALE: 1/8" = 1'-0"

KEYED PLUMBING SHEET NOTES

1. VERIFY LAVATORY FAUCET IS OLDER OBSOLETE SYMMONS FAUCET MODEL. WHERE OLDER OBSOLETE SYMMONS FAUCET MODEL IS PRESENT, REPLACE THE SYMMONS FAUCET WITH NEW REPLACEMENT SYMMONS FAUCET MODEL (SYMMONS MODEL S6980B). REUSE EXISTING NON-FAUCET COMPONENTS SUCH AS WATER SUPPLY STOP VALVES, ETC. PROVIDE ALL NEW WATER SUPPLY TUBING AND NEW ADA PIPE INSULATION FOR P-TRAP, DRAINAGE PIPING, AND WATER PIPING. PROVIDE NEW SYMMONS MODEL 8210CK THERMOSTATIC MIXING VALVE. THE NUMBER OF FAUCETS TO VERIFY IS IDENTIFIED ON PLANS WITH CIRCLE TAG.

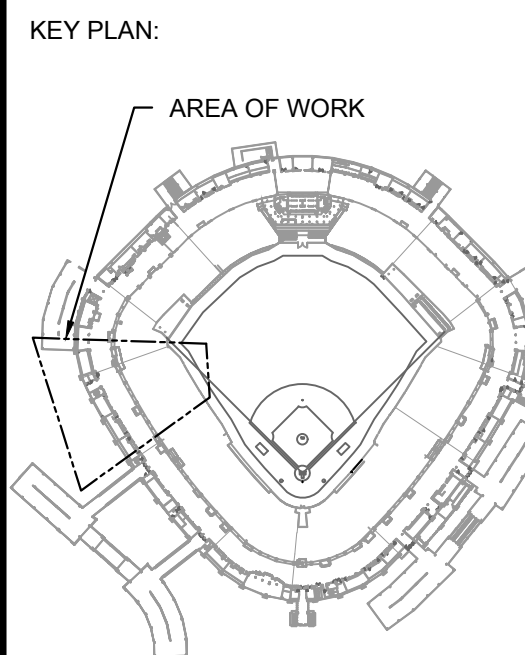

ISSUE/REVISION:		
REV.	DATE	DESCRIPTION
1	11/14/25	ISSUE FOR BID



PROJECT:
GUARANTEED RATE FIELD -
WASTE/VENT PIPING FY2026

333 W 35TH STREET,
CHICAGO, ILLINOIS 60616

DRAWING TITLE:
PLUMBING PLAN - LEVEL 500 -
SECTION 9

DESIGNED BY: CF
CHECKED BY: MS
PROJECT NO: 25081
SCALE: 1/8" = 1'-0"

SHEET NO.
P1.509

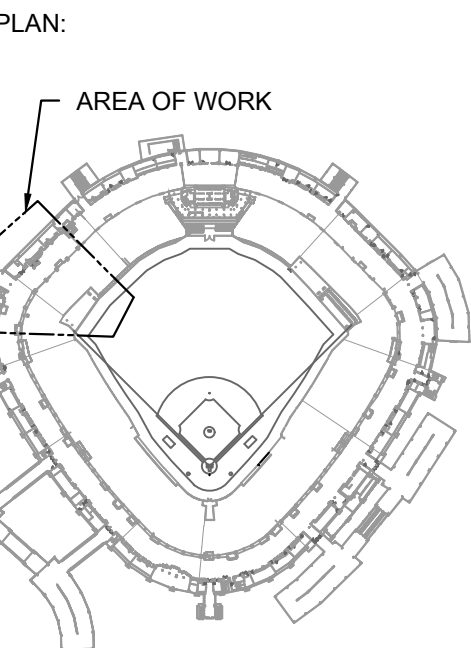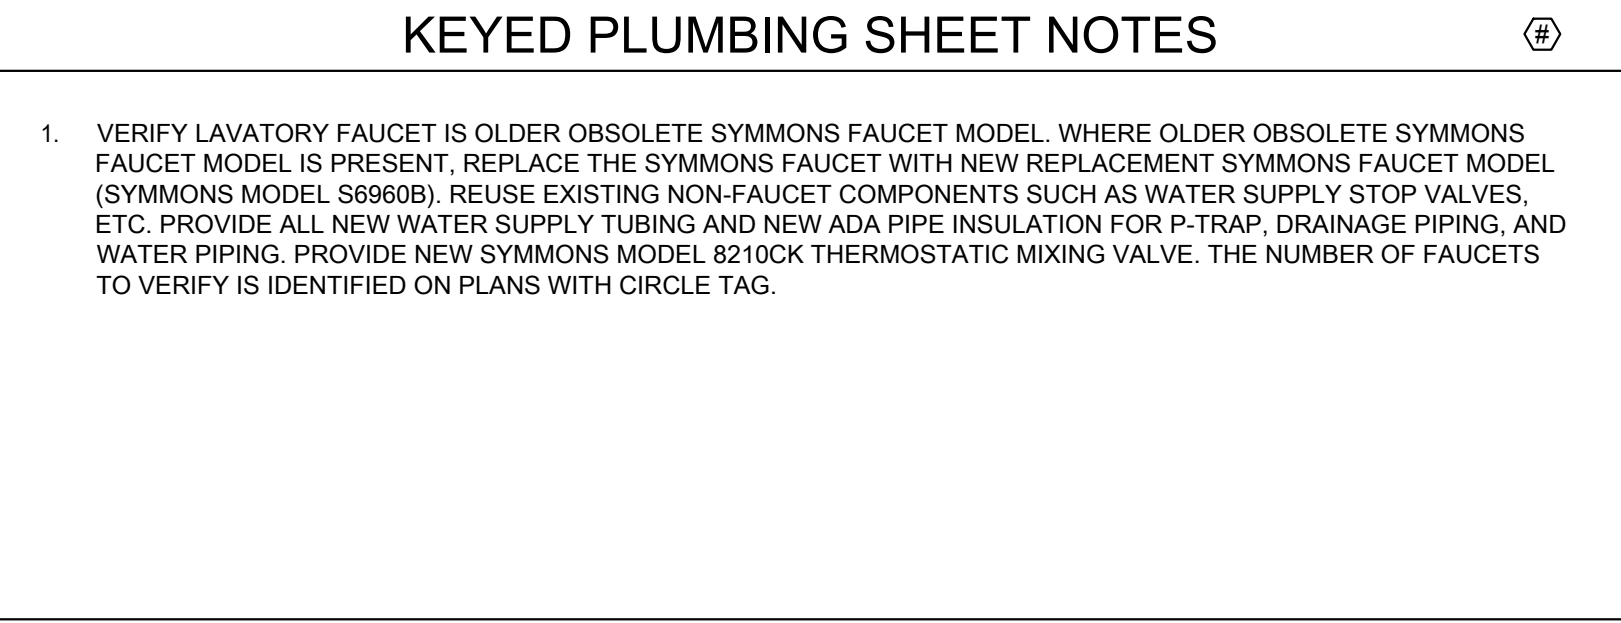[illegible]


PROJECT:
GUARANTEED RATE FIELD -
WASTE/WENT PIPING FY2026
1555 W. 35TH STREET,
CHICAGO, ILLINOIS 60616

PROJECT TITLE:
DRAINAGE PLAN - LEVEL 500 -
SECTION 10

DESIGNED BY:	CF
DRAWN BY:	MS
PROJECT NO:	25081
SCALE:	1/8" = 1'-0"
DATE:	


P1.510

1 PLUMBING PLAN - 500 LEVEL - SECTION 10 ENLARGED
SCALE: 1/8" = 1'-0"

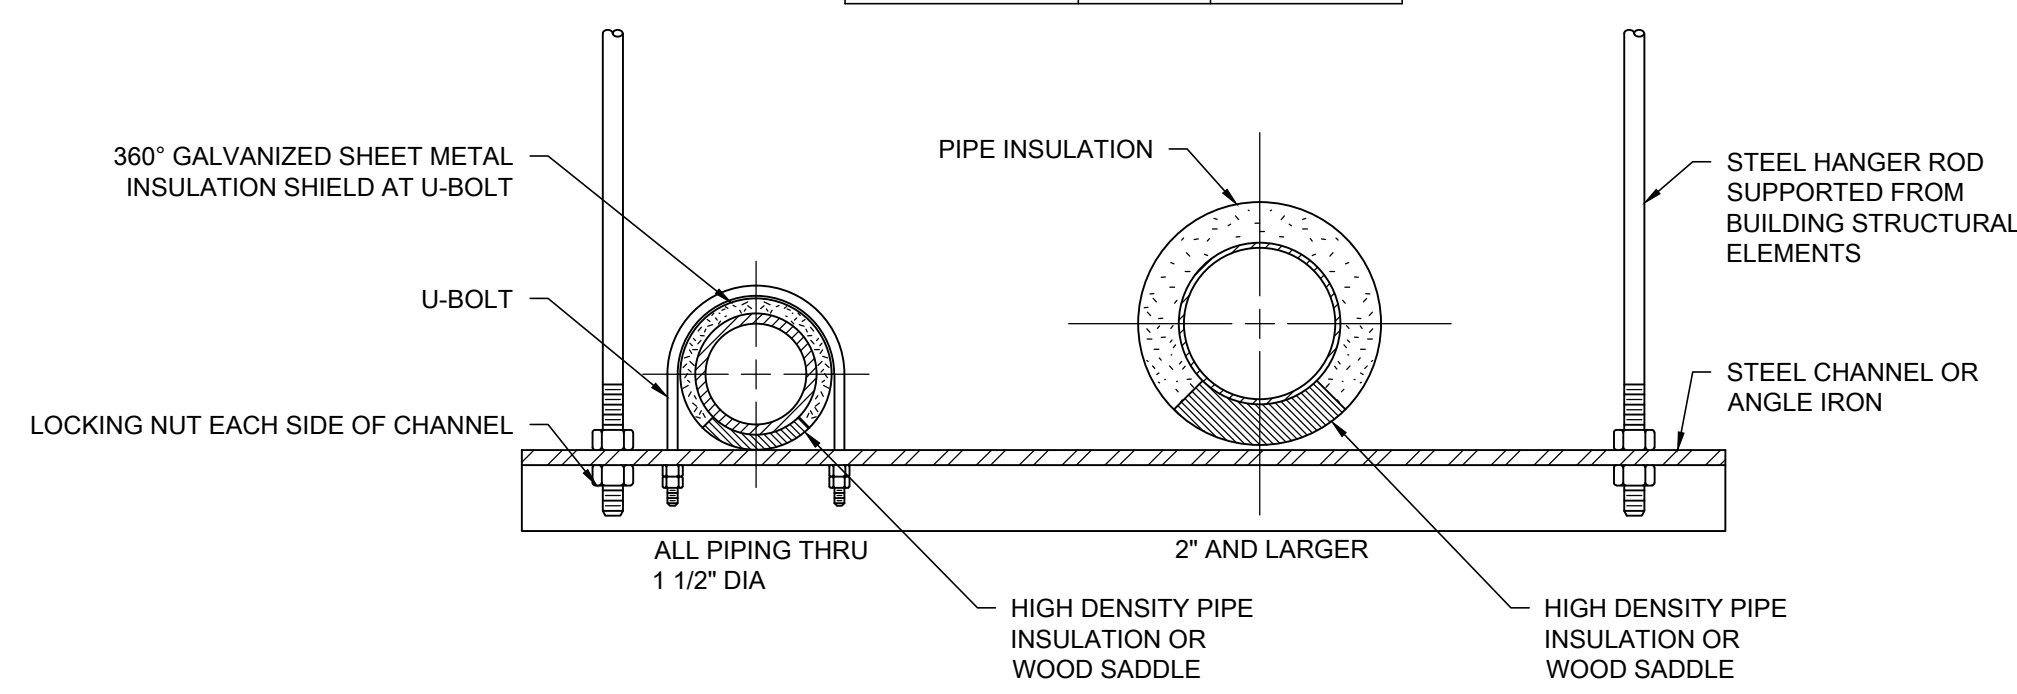

PIPE HANGERS AND SUPPORTS (HORIZONTAL STEEL AND COPPER PIPING)		
NOMINAL PIPE SIZE	DISTANCE BETWEEN SUPPORTS	HANGER ROD DIAMETERS
1/2"	6'	3/8"
3/4" TO 1-1/2"	6'	1/2"
2" TO 2-1/2"	10'	1/2"
3" AND 4"	12'	5/8"
6" TO 12"	14'	7/8"


SCALE: NO SCALE

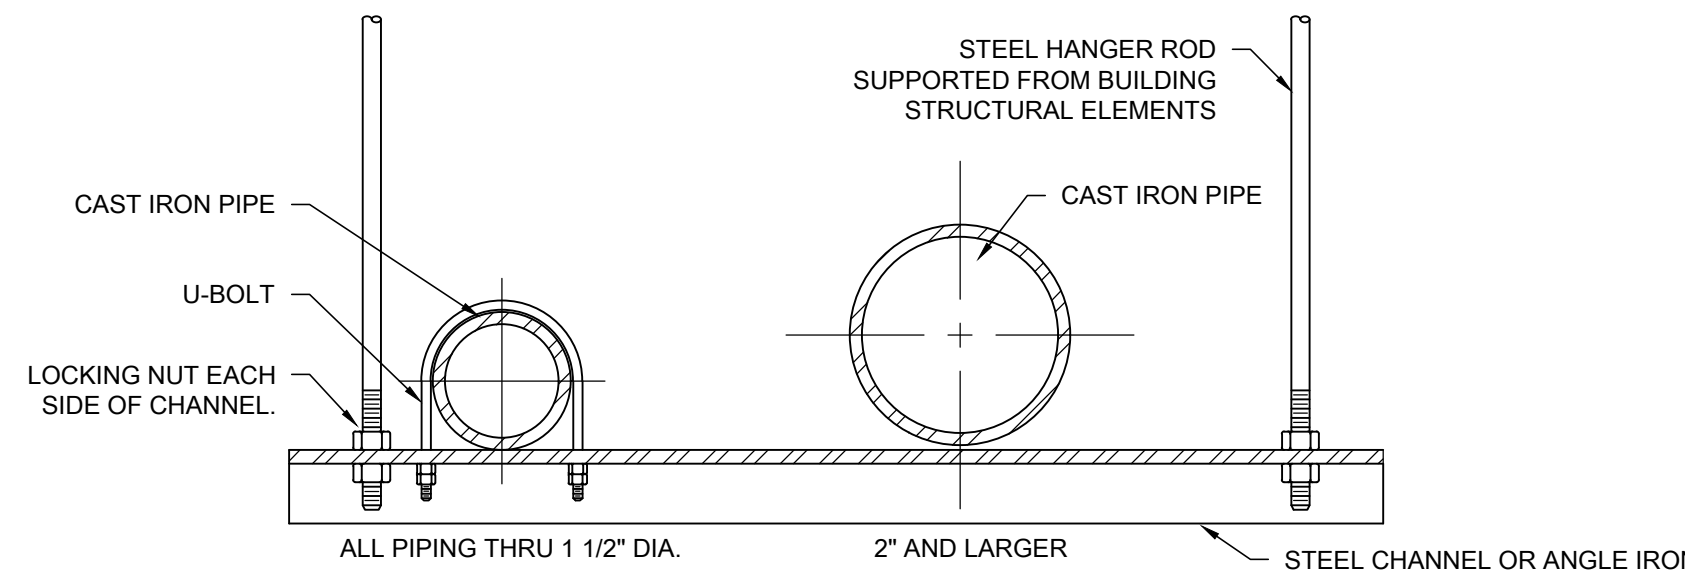


NOTES:

PLACE HANGER WITHIN 1 FOOT OF EACH HORIZONTAL ELBOW. SUPPORT HORIZONTAL SOLID WASTE AND STORM PIPE NEAR EACH HUB, WITH 5 FEET MAXIMUM SPACING BETWEEN HANGERS.


SCALE: NO SCALE

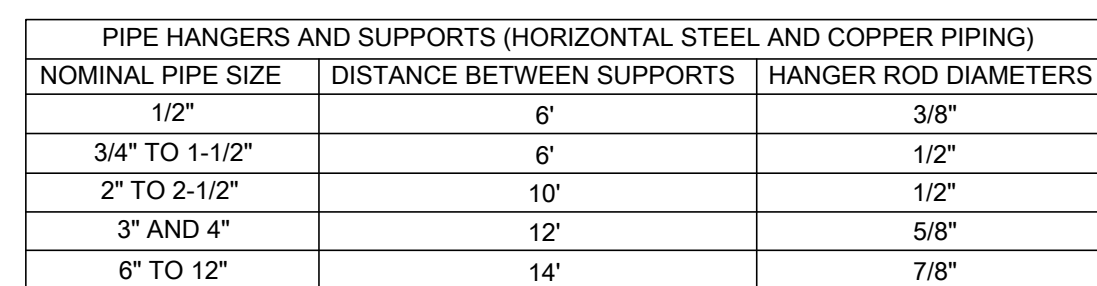

SCALE: NO SCALE

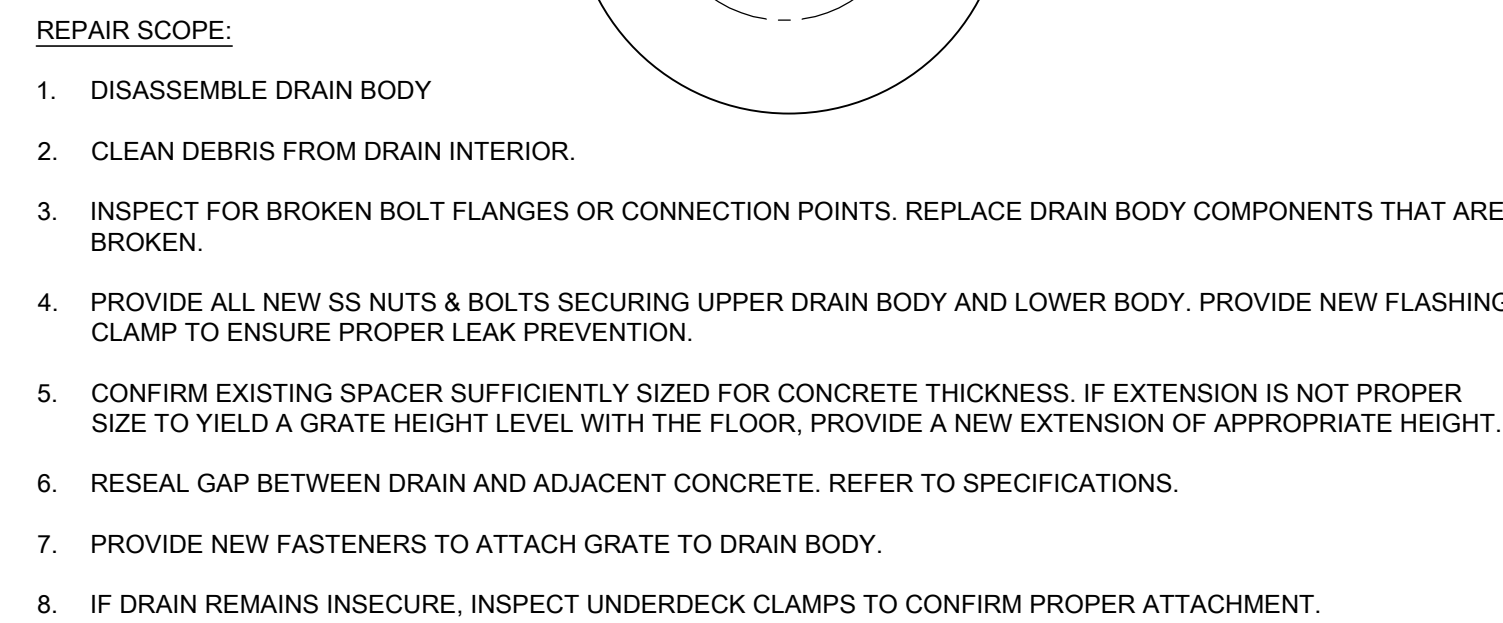


SCALE: NO SCALE

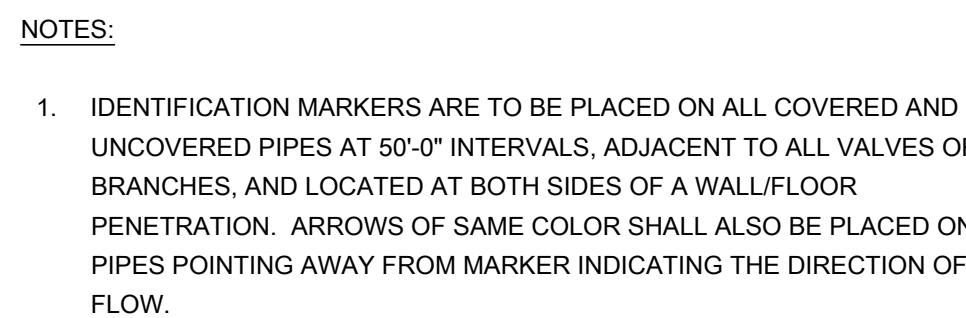


PLAN TAG	SERVICE	IDENTIFICATION MARKER
SAN V	SANITARY VENT	WHITE LETTERING ON GREEN BACKGROUND
STORM	STORM	WHITE LETTERING ON GREEN BACKGROUND
NP	NON-POTABLE COLD WATER	BLACK LETTERING ON YELLOW BACKGROUND
???	RAINWATER HARVESTED WATER	WHITE LETTERING ON PURPLE BACKGROUND
CW	DOMESTIC COLD WATER	WHITE LETTERING ON GREEN BACKGROUND
HW	DOMESTIC HOT WATER	BLACK LETTERING ON YELLOW BACKGROUND
HWR	DOMESTIC HOT WATER RETURN	BLACK LETTERING ON YELLOW BACKGROUND


E: NO SCALE

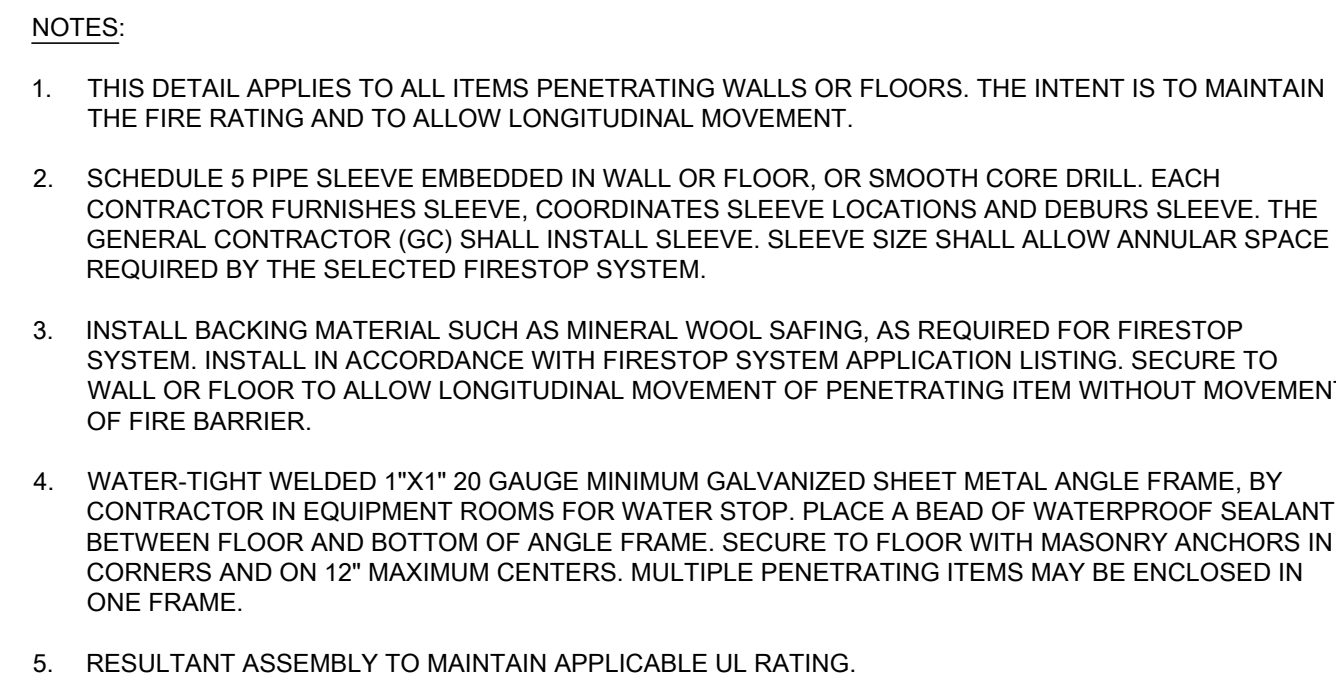

SCALE: NO SCALE

 

SCALE: NO SCALE

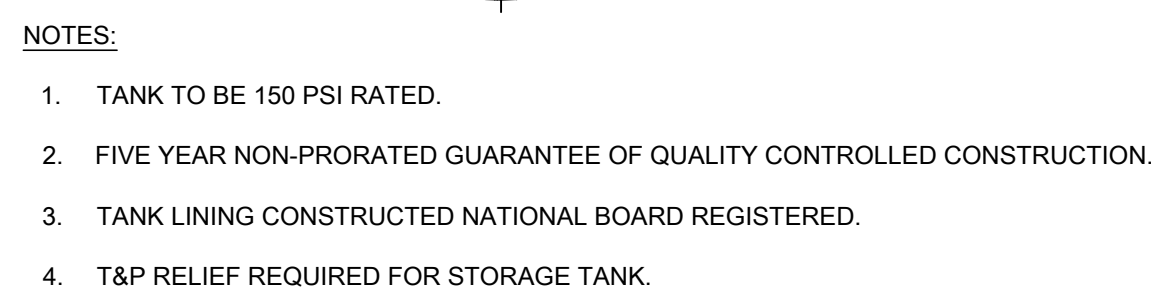

JACKIE

STORAGE TANK SCHEDULE (ST)											
EQUIP. TAG		MANUFACTURER	MODEL	TYPE	LOCATION	ORIENTATION	CAPACITY (GALLONS)	WORKING PRESSURE (PSI)	DIMENSIONS (DIAMETER/HEIGHT)	OPERATIONAL WEIGHT (LBS.)	NOTES
ABB	NO.										
HST	1A-01	CEMLINE	V300LST	FACTORY INSULATED AND JACKETED	MECHANICAL 1.14.4	VERTICAL	3,200	150	96" X 120"	26,000	1-12
HST	1A-02	CEMLINE	V300LST	FACTORY INSULATED AND JACKETED	MECHANICAL 1.14.4	VERTICAL	3,200	150	96" X 120"	26,000	1-12
NOTES:											
1. USING EXISTING 4" CONCRETE PAD TO MOUNT STORAGE TANK ON. EXPAND PAD AS NECESSARY.											
2. PROVIDE LEVELING BOLTS AND COUPLING FOR PIPE LEGS. ADD ADDITIONAL SUPPORT STRUCTURE TO ALLOW FUNCTION OF DRAIN DOWN FOR STORAGE TANK.											
3. UNIT TO INCLUDE WITH INTEGRAL INSULATION TO COMPLY WITH LATEST ASHRAE 90.1 (3-INCH FIBERGLASS INSULATION).											
4. PROVIDE CODE COMPLIANT SAFETY DEVICES. VALVE LOCATION AND DISCHARGE PIPING OF ANY SAFETY DEVICE SHALL IN PROXIMITY TO EXISTING FLOOR DRAIN OR OTHER APPROVED RECEPTOR.											
5. UNIT STANDARD INCLUDES STORAGE TANK-ASME CODE CONSTRUCTED-NATIONAL BOARD REGISTERED- WOL STAMP.											
6. UNIT STANDARD INCLUDES MINIMUM 1/2" THICK STONESTEEL (CEMENT) TANK LINING AND INCLUDE WIRE MESH COMPLETELY WELDED OVER THE INTERIOR PRIOR TO THE APPLICATION OF THE LINING.											
7. UNIT STANDARD INCLUDES 304 STAINLESS STEEL THREADED CONNECTIONS. INCREASE CONNECTION SIZES TO FIELD PIPE SIZES.											
8. UNIT STANDARD INCLUDES ALL OPENINGS IN JACKET EXTENDED THROUGH THE JACKET WITH RED BRASS NIPPLES WITH EUSTACHEONS USED AT ALL JACKET PENETRATIONS.											
9. UNIT STANDARD INCLUDES STEEL STORAGE TANK CONSTRUCTED IN ACCORDANCE WITH SECTION IV OF THE ASME CODE. PROVIDE 150 PSI WORKING PRESSURE.											
10. UNIT STANDARD INCLUDES 11" X 15" MANHOLE (AS REQUIRED BY ASME CODE ON TANKS ABOVE 600 GALLON STORAGE CAPACITY).											
11. UNIT STANDARD INCLUDES 20 GAUGE STEEL JACKET WITH HAMMER TONE ENAMEL PAINTED EXTERIOR.											
12. PROVIDE WITH STANDARD 5-YEAR LIMITED WARRANTY.											



KEY PLAN:

ISSUE/REVISION:

REV.	DATE	DESCRIPTION
1	11/14/25	ISSUE FOR BID

PROJECT:
GUARANTEED RATE FIELD -
WASTE/VENT PIPING FY2026

333 W 35TH STREET,
CHICAGO, ILLINOIS 60616

DRAWING TITLE:
PLUMBING SCHEDULES

DESIGNED BY:	CF
CHECKED BY:	MS
PROJECT NO:	25081
SCALE:	NO SCALE

SHEET NO.

P3.001

[illegible]