


ISFA
333 W 35TH STREET
CHICAGO, IL 60616

333 W 35TH STREET
CHICAGO, IL 60616

NOVEMBER 14, 2025
ISSUE FOR BID





SHEET LIST TABLE		
SHEET NUMBER	SHEET TITLE	
GENERAL		
GQ.001	PROJECT COVER SHEET	
PLUMBING		
PL.001	PLUMBING TITLE SHEET	
PL.002	PLUMBING PLAN - UNDERGROUND - SECTION 1	
PL.003	PLUMBING PLAN - UNDERGROUND - SECTION 2	
PL.004	PLUMBING PLAN - UNDERGROUND - SECTION 3	
PL.005	PLUMBING PLAN - UNDERGROUND - SECTION 4	
PL.006	PLUMBING PLAN - UNDERGROUND - SECTION 5	
PL.007	PLUMBING PLAN - UNDERGROUND - SECTION 6	
PL.008	PLUMBING PLAN - UNDERGROUND - SECTION 7	
PL.009	PLUMBING PLAN - UNDERGROUND - SECTION 8	
PL.010	PLUMBING PLAN - UNDERGROUND - SECTION 9	
PL.011	PLUMBING PLAN - UNDERGROUND - SECTION 10	
PL.501	PLUMBING PLAN - SERVICE LEVEL - SECTION 1	
PL.502	PLUMBING PLAN - SERVICE LEVEL - SECTION 2	
PL.503	PLUMBING PLAN - SERVICE LEVEL - SECTION 3	
PL.504	PLUMBING PLAN - SERVICE LEVEL - SECTION 4	
PL.505	PLUMBING PLAN - SERVICE LEVEL - SECTION 5	
PL.506	PLUMBING PLAN - SERVICE LEVEL - SECTION 6	
PL.507	PLUMBING PLAN - SERVICE LEVEL - SECTION 7	
PL.508	PLUMBING PLAN - SERVICE LEVEL - SECTION 8	
PL.509	PLUMBING PLAN - SERVICE LEVEL - SECTION 9	
PL.510	PLUMBING PLAN - SERVICE LEVEL - SECTION 10	
PL.511	PLUMBING PLAN - SERVICE LEVEL - SECTION 11	
PL.102	PLUMBING PLAN - LEVEL 100 - SECTION 2	
PL.103	PLUMBING PLAN - LEVEL 100 - SECTION 3	
PL.104	PLUMBING PLAN - LEVEL 100 - SECTION 4	
PL.105	PLUMBING PLAN - LEVEL 100 - SECTION 5	
PL.106	PLUMBING PLAN - LEVEL 100 - SECTION 6	
PL.107	PLUMBING PLAN - LEVEL 100 - SECTION 7	
PL.108	PLUMBING PLAN - LEVEL 100 - SECTION 8	
PL.109	PLUMBING PLAN - LEVEL 100 - SECTION 9	
PL.110	PLUMBING PLAN - LEVEL 100 - SECTION 10	
PL.111	PLUMBING PLAN - LEVEL 200 - SECTION 11	
PL.203	PLUMBING PLAN - LEVEL 200 - SECTION 3	
PL.204	PLUMBING PLAN - LEVEL 200 - SECTION 4	
PL.205	PLUMBING PLAN - LEVEL 200 - SECTION 5	
PL.206	PLUMBING PLAN - LEVEL 200 - SECTION 6	
PL.207	PLUMBING PLAN - LEVEL 200 - SECTION 7	
PL.208	PLUMBING PLAN - LEVEL 200 - SECTION 8	
PL.209	PLUMBING PLAN - LEVEL 200 - SECTION 9	
PL.210	PLUMBING PLAN - LEVEL 200 - SECTION 10	
PL.300	PLUMBING PLAN - LEVEL 300 - SECTION 4	
PL.305	PLUMBING PLAN - LEVEL 300 - SECTION 5	
PL.306	PLUMBING PLAN - LEVEL 300 - SECTION 6	
PL.307	PLUMBING PLAN - LEVEL 300 - SECTION 7	
PL.308	PLUMBING PLAN - LEVEL 300 - SECTION 8	
PL.309	PLUMBING PLAN - LEVEL 300 - SECTION 9	
PL.404	PLUMBING PLAN - LEVEL 400 - SECTION 4	
PL.405	PLUMBING PLAN - LEVEL 400 - SECTION 5	
PL.406	PLUMBING PLAN - LEVEL 400 - SECTION 6	
PL.407	PLUMBING PLAN - LEVEL 400 - SECTION 7	
PL.408	PLUMBING PLAN - LEVEL 400 - SECTION 8	
PL.409	PLUMBING PLAN - LEVEL 400 - SECTION 9	
PL.410	PLUMBING PLAN - LEVEL 400 - SECTION 10	
PL.503	PLUMBING PLAN - LEVEL 500 - SECTION 3	
PL.504	PLUMBING PLAN - LEVEL 500 - SECTION 4	
PL.505	PLUMBING PLAN - LEVEL 500 - SECTION 5	
PL.506	PLUMBING PLAN - LEVEL 500 - SECTION 6	
PL.507	PLUMBING PLAN - LEVEL 500 - SECTION 7	
PL.508	PLUMBING PLAN - LEVEL 500 - SECTION 8	
PL.509	PLUMBING PLAN - LEVEL 500 - SECTION 9	
PL.510	PLUMBING PLAN - LEVEL 500 - SECTION 10	
PQ.001	PLUMBING DETAILS	
PQ.001	PLUMBING SCHEDULES	
PA.001	PLUMBING SPECIFICATIONS	

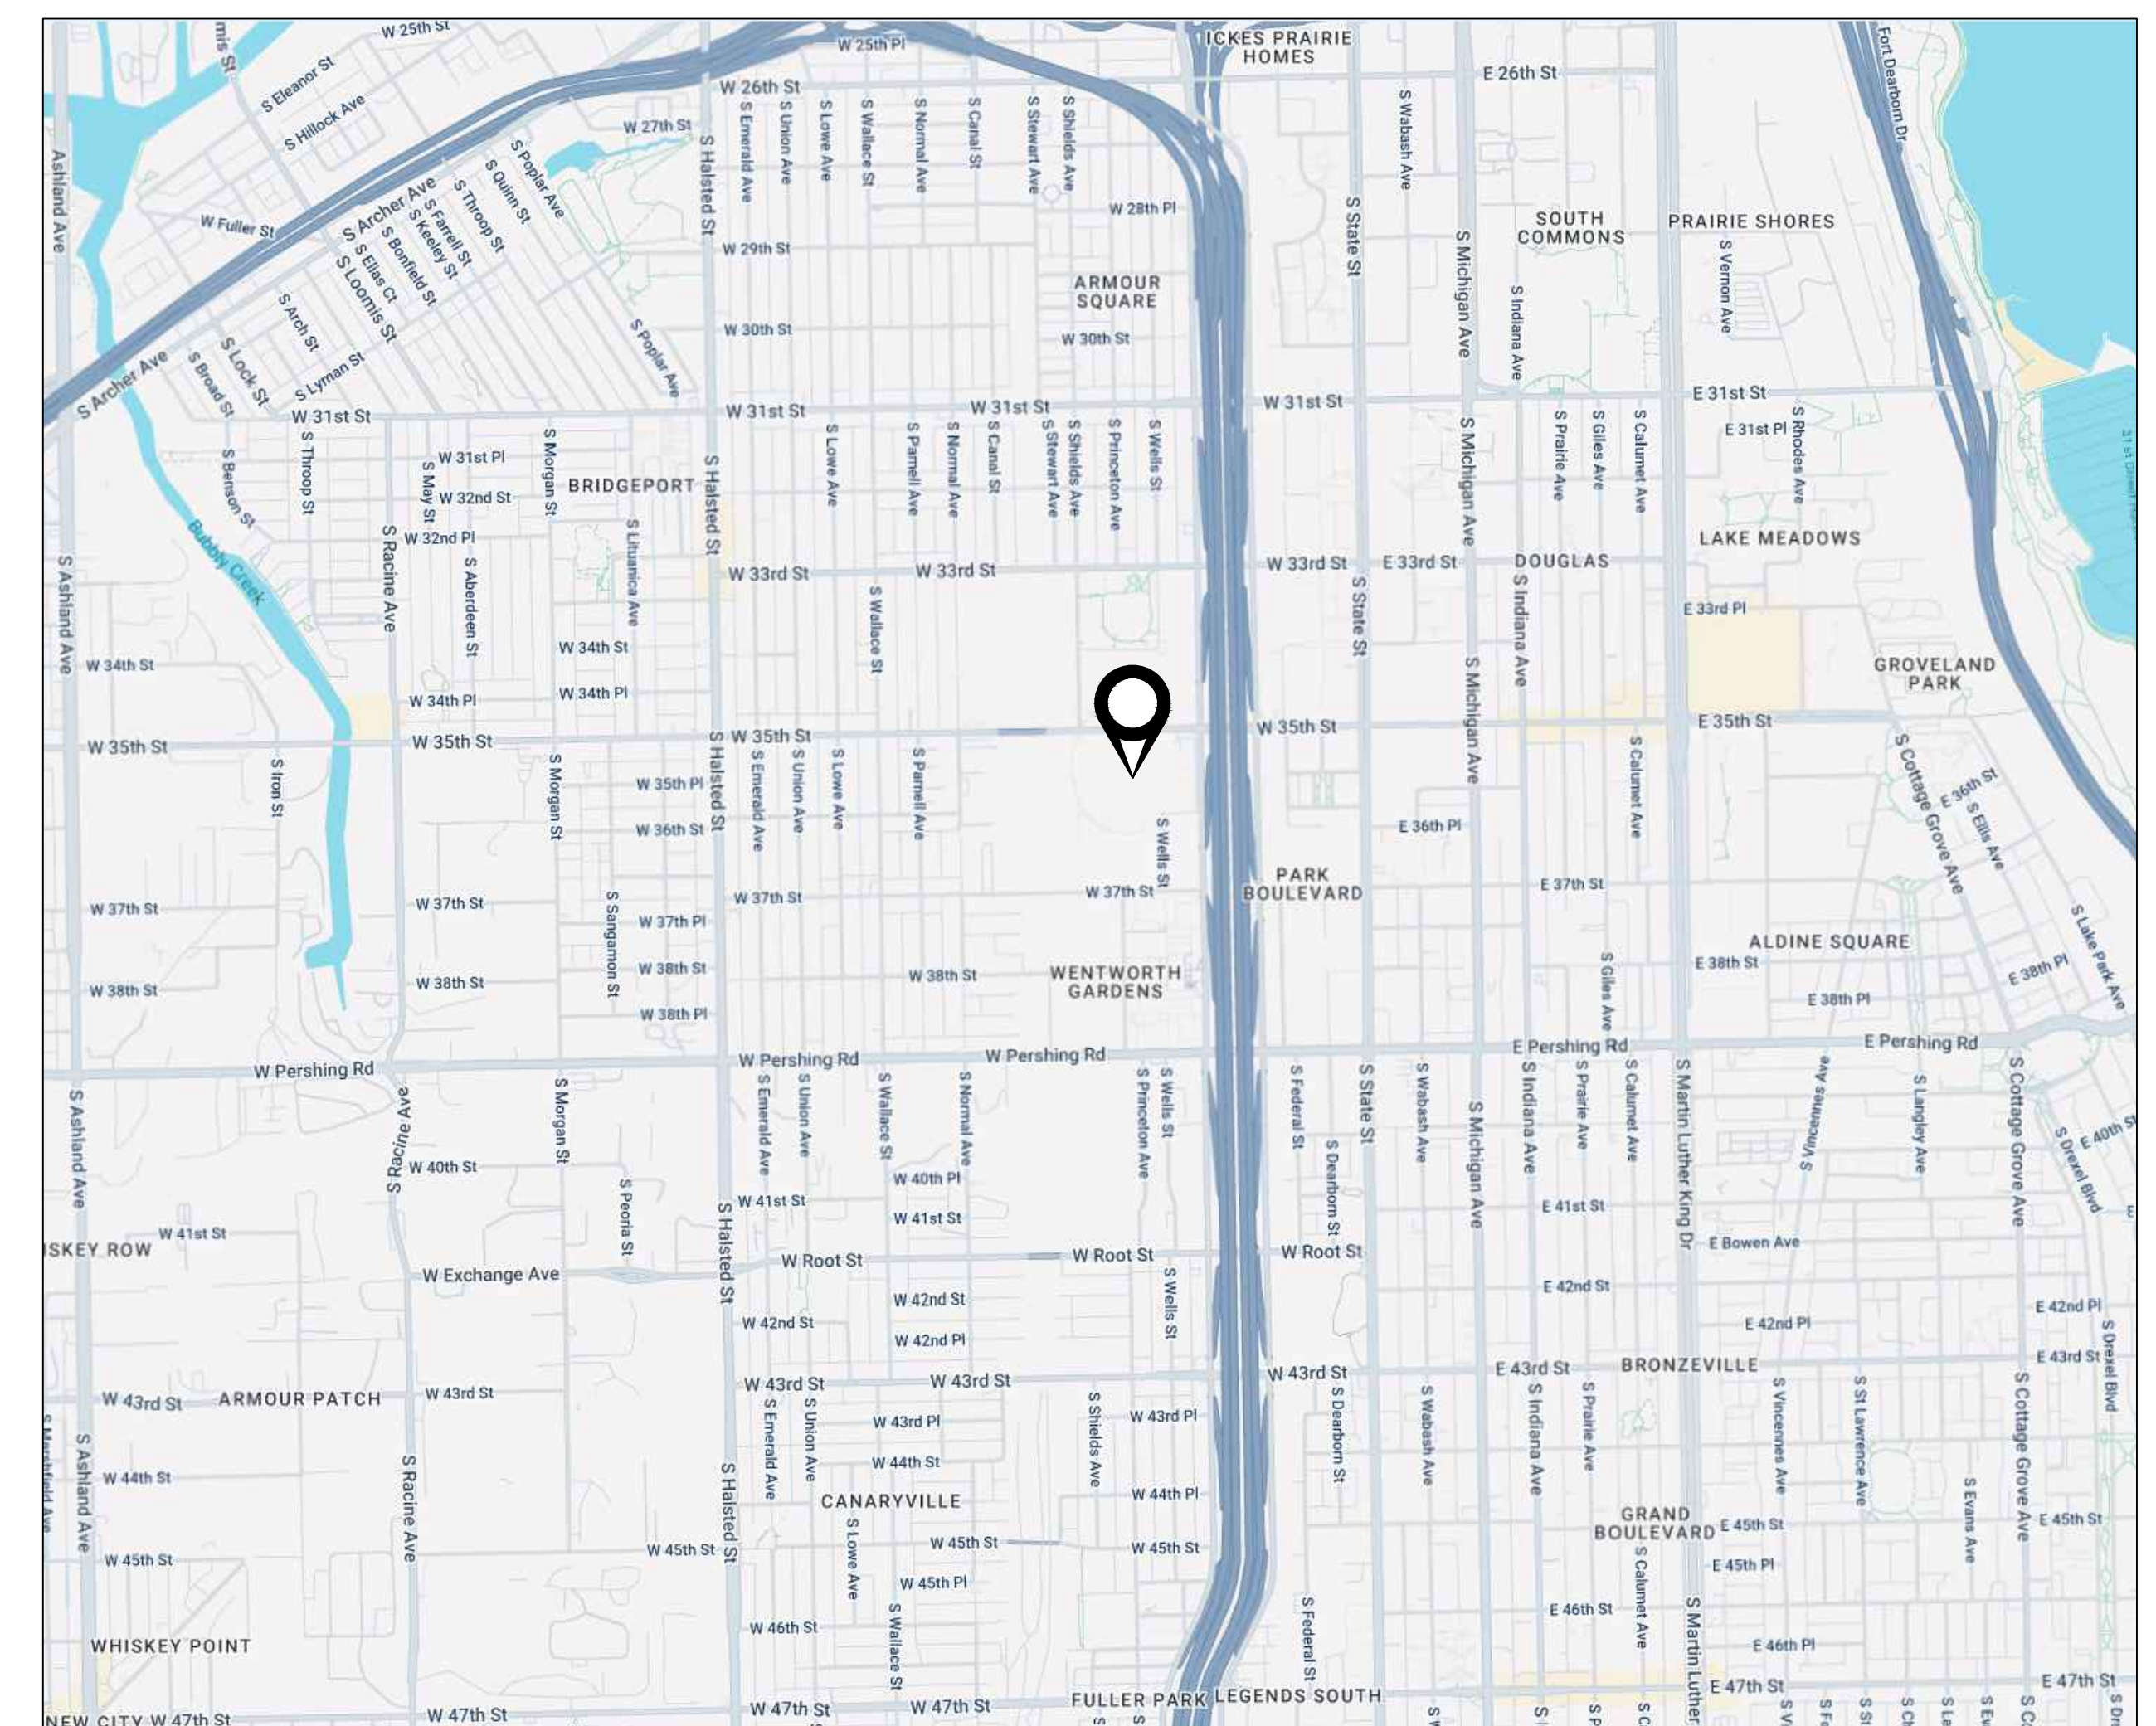

1 LOCATION MAP

  [illegible]

 DEPARTMENT OF BUILDINGS CITY OF CHICAGO ADMINISTRATIVE RELIEF	
Form: <u>AS-244-1 (3-11)</u>	Application No: <u>08-08846</u>
Property Address: <u>312 N. W. 24th St., Chicago, Ill.</u>	File No: <u>10-000000</u>
Project name: <u>312 Chicago St.</u>	
SUBJECT OF REQUEST: <u>Plumbing, Heating, Mechanical</u>	
ADMINISTRATIVE RELIEF is granted to the above address regarding the code section <u>10-29-200.1</u> <u>pertaining to the use of polypropylene film on the exterior walls in lieu of cast-in-place</u> <u>for the concrete, business district building from the book documents and their dates in the</u> <u>revised Building code.</u>	
Specifically, the relief from the code problems is causing constant deterioration of the cast concrete surface. Polypropylene plastic is more resistant to acidic rains but polypropylene is extremely not as successful against the sun.	
The Administrative Relief is granted only to the address under this permit for the specific scope of work. If the scope or use is changed or the scope of work under this permit changes this Relief is VOID.	
Once signed by the Commissioner of the Department of Buildings, this form must be permanently submitted to the permit or fee of the cooperative documents.	
Richard Merchant Commissioner	  Date Received
Customer Name: <u>Southside</u>	
Meeting/Contact Date: <u>10/20/2010/10/20/10</u>	
Telephone: <u>312-454-2028</u>	Fax: <u>312-373-0722</u>
OFFICE USE ONLY	
Reviewed by: <u>KEVIN GEIGER</u>	
Inspected by: <u>1/14/11</u>	
Recommended by: <u>R. S. FENNER</u>	
<u>5/4/11</u>	

100 NORTH BACON AVENUE, CHICAGO, ILLINOIS 60607

MEPFP
ENGINEERING

ELARA ENGINEERING

30 N WOLF RD
SECOND FLOOR
HILLSIDE, IL 60162

(708) 236-0300

PROJECT SCOPE OF WORK

1. REPLACE GREASE TRAP AT RATE FIELD KITCHEN SPACE AS IDENTIFIED.
2. REPLACE STORM PUMP SYSTEMS IN AREAS IDENTIFIED.
3. COMPLETE OWNER SITE SCOPING IN AREAS IDENTIFIED.
4. COMPLETE UNDERGROUND SCOPING TO BE PERFORMED IN AREAS IDENTIFIED.
5. REPLACE PUBLIC LAUNDRY FAUCETS, ACCESSORIES, COMPONENTS, SPECIALTIES, ETC.
6. REPAIR AND REPLACE 9 SECTIONS OF PIPING. USE ARWARY PIPING WHERE DESCRIBED.
7. REPLACE THE 2 LARGE MAIN WATER HEATER STORAGE TANKS, ONE AT A TIME. 
8. VERIFY AND UPDATE RAMP DRAINS IN AREAS IDENTIFIED.

ELECTRICAL SCOPE OF WORK

1. DISCONNECT POWER AND RECONNECT POWER FOR IN-KIND REPLACEMENT FOR EJECTOR AND SUMP PUMPS FOR THE REQUIRED REPLACEMENT SCOPE.

PROJECT REQUIREMENTS

1. ANY EXISTING EQUIPMENT TO DEMOLISHED SHALL BE COORDINATED WITH CHICAGO WHITE SOX OR THE CHICAGO WHITE SOX MAINTENANCE STAFF MAY SALVAGE EQUIPMENT, PARTS, COMPONENTS, ETC. INCLUDING BUT NOT LIMITED TO LAVATORY FAUCETS REPLACEMENT SCOPE PARTS.
2. ANY PIPING MATERIAL AND ASSOCIATED COMPONENTS TO DEMOLISHED SHALL BE COORDINATED WITH CHICAGO WHITE SOX PRIOR TO DISPOSAL.
3. CONTRACTOR REMAINS FULLY RESPONSIBLE FOR ALL DEMOLISHED EQUIPMENT, PIPING MATERIALS, PARTS, COMPONENTS, ETC. THAT CHICAGO WHITE SOX DOES NOT SALVAGE.
4. VARIABLE FREQUENCY DRIVES SHALL BE MANUFACTURED BY "ABB" ONLY.
5. COORDINATE ACCESS TO SPACES NECESSARY TO PERFORM WORK WITH ISFA. PORTIONS OF THE BUILDING WILL BE SECURED REGULARLY AND ISFA REQUIRES NOTIFICATION TO PROVIDE ACCESS.
6. CONTRACTOR SHALL ENDEAVOR TO SUBMIT SUBMITTALS TIMELY FOR REVIEW AND COORDINATION PURPOSES.

BUILDING DETAILS

TC FAUCETS PER LEVEL:

SERVICE LEVEL: 35
100 LEVEL: 4
200 LEVEL: 22
300 LEVEL: 31
400 LEVEL: 38

CONTRACTOR IS RESPONSIBLE FOR FINAL COUNTS.

Y PLAN:

DATE/REVISION:

[illegible]

PROJECT:
GUARANTEED RATE FIELD -
WASTE/VENT PIPING FY2026

W 35TH STREET,
CHICAGO, ILLINOIS 60616

PROJECT COVER SHEET

SIGNED BY: CF

HECKED BY: MS

PROJECT NO: 2508

SCALE:	NO SCALE
FEET NO.	

EET NO.































G0.001

ABBREVIATIONS

ACW	AUTOMATIC CLOTHES WASHER	KEC	KITCHEN EQUIPMENT CONTRACTOR
AD	AREA DRAIN	KED	KITCHEN EQUIPMENT DESIGNER
AFF	ABOVE FINISHED FLOOR	KW	KITCHEN WASTE OR KILOWATT
AMP	AMPERE	L/LAV	LAVATORY
ANB	ACID NEUTRALIZING BASIN	LS	LAB SINK
ANSI	AMERICAN NATIONAL STANDARDS INSTITUTE	LT	LAUNDRY TUB
ARW	ACID RESISTANT WASTE	MB	MOP BASIN
ASPE	AMERICAN SOCIETY OF PROFESSIONAL ENGINEERS	MC	MECHANICAL CONTRACTOR
ASSE	AMERICAN SOCIETY OF SAFETY ENGINEERS	MS	MANUFACTURERS STANDARDIZATION SOCIETY
ASTM	AMERICAN SOCIETY FOR TESTING AND MATERIALS	NC	NEW CONNECTION OR NORMALLY CLOSED
AV	ACID/CHEMICAL VENT	NPS	NOMINAL PIPE SIZE
AVTR	ACID/CHEMICAL VENT THRU ROOF	NPW	NON POTABLE WATER
AW	ACID/CHEMICAL WASTE	NO	NORMALLY OPEN
BASC	BUILDING AUTOMATION SYSTEMS CONTRACTOR	NSF	NATIONAL SCIENCE FOUNDATION
BFP	BACKFLOW PREVENTER	NTS	NOT TO SCALE
BOP	BOTTOM OF PIPE	OD	OVERFLOW DRAIN
BT	BATH TUB	OSD	OPEN SITE DRAIN
CA	CAST IRON	OSBY	OUTSIDE STEM AND YOKE
CISPI	CAST IRON SOIL PIPE INSTITUTE	P	PIPE ANCHOR
CLG	CEILING	PC	PLUMBING CONTRACTOR
CO	CLEANOUT	PD	PUMP DISCHARGE
CONN	CONNECTION	PDI	PLUMBING & DRAINAGE INSTITUTE
DCW	DOMESTIC COLD WATER	PE	PROFESSIONAL ENGINEER
DHW	DOMESTIC HOT WATER	PH	PHASE
DHWR	DOMESTIC HOT WATER RETURN	PIV	POST INDICATOR VALVE
DTW	DOMESTIC TEMPERED WATER	PPM	PARTS PER MILLION
DBCV	DOUBLE CHECK VALVE	PRV	PRESSURE REDUCING VALVE
DCV	DUAL CHECK VALVE	PS	PLUMBING STACK
DCDA	DOUBLE CHECK DETECTOR ASSEMBLY	PSI	POUNDS PER SQUARE INCH
DDCV	DOUBLE-DETECTOR CHECK VALVE	RCP	RECIRCULATION PUMP
DF	DRINKING FOUNTAIN	RD	ROOF DRAIN
DFU	DRAINAGE FIXTURE UNIT	RH	ROOF HYDRANT
DI	DRAIN TILE	ROB	ROD OUT BASIN
DW	DISHWASHER	RPM	REVOLUTIONS PER MINUTE
DWH	DOMESTIC WATER HEATER	RPZ	REDUCED PRESSURE ZONE BACKFLOW PREVENTER
DWS	DOMESTIC WATER SOFTENER	S/ SAN	SANITARY WASTE
EC	ELECTRICAL CONTRACTOR	SC	SITE UTILITY CONTRACTOR
EEW	EMERGENCY EYE AND FACE WASH	SE	SEWAGE EJECTOR
EPDM	ETHYLENE PROPYLENE DIENE MONOMER	SH	SHOWER
ET	EXPANSION TANK	SI	SOLIDS INTERCEPTOR
ESH	EMERGENCY SHOWER	SK	SINK
ESP	ELEVATOR SUMP PUMP	SP	SUMP PUMP
ETR	EXISTING TO REMAIN	SQ	SQUARE FEET
EWC	ELECTRIC WATER COOLER	SS	SERVICE SINK
EWI	ELECTRIC WATER HEATER	S.S.	STAINLESS STEEL
FCD	FLOOR CLEANOUT	ST	STORM
FOD	FATS, OILS AND GREASE	SST	SECONDARY STORM (OVERFLOW)
FPS	FEET PER SECOND	TB	THRUST BLOCK
FS	FLOOR SINK	TD	TRENCH DRAIN
FT	FEET	TMV	THERMOSTATIC MIXING VALVE
G	NATURAL GAS	TRV	TEMPERATURE AND PRESSURE REDUCING VALVE
GC	GENERAL CONTRACTOR	UR	URINAL
GCO	GROUND CLEANOUT	V	VENT
GI	GREASE INTERCEPTOR	VB	VACUUM BREAKER
GPD	GALLONS PER DAY	VTR	VENT THRU ROOF
GPH	GALLONS PER HOUR	W	WASTE
GPM	GALLONS PER MINUTE	WC	WATER CLOSET
GT	GREASE TRAP	WCO	WALL CLEANOUT
GW	GARAGE WASTE	WF	WASH FOUNTAIN
HB	HOSE BIBB	WH	WALL HYDRANT
HD	HEAD	WHA	WATER HAMMER ARRESTOR
HP	HORSEPOWER	WSB	WALL SUPPLY BOX
HX	HEAT EXCHANGER	WSFU	WATER SUPPLY FIXTURE UNITS
I	INVERT ELEVATION	YCD	YARD CLEANOUT
IWB	ICE MACHINE/REFRIGERATOR WALL BOX	YH	YARD HYDRANT
KS	KITCHEN STACK		

NOTE: NOT ALL ABBREVIATIONS LISTED ABOVE MAY BE USED OR APPEAR IN THESE DRAWINGS

                              NOTE: NOT ALL ABBREVIATIONS LISTED ABOVE MAY BE USED OR APPEAR IN THESE DRAWINGS.

PLUMBING SYMBOLS			
GENERAL			
	FLOOR DRAIN		PIPE TEE, DOWN
	FLOOR SINK		PIPE TEE, 45° HORIZONTAL
	FLOOR CLEANOUT		PIPE TEE, 90° HORIZONTAL
	ROOF DRAIN		PIPE TEE, UP
	EMERGENCY SHUTOFF		PIPE UNION
	POINT OF CONNECTION OF NEW TO EXISTING WORK		THREADED HOSE CONNECTION
	POINT OF DEMOLITION TO EXISTING WORK		AIR CHAMBER
	ABBREVIATION		BALL VALVE
	EQUIPMENT TAG		BUTTERFLY VALVE
	NUMBER		CHECK VALVE
	RISER TAG		GAS COCK
	MATCH LINE		GATE VALVE
	VIEW # SHEET #		GLOBE VALVE
	VIEW # SHEET #		MANUAL BALANCING VALVE
	KITCHEN EQUIPMENT TAG		NEEDLE VALVE
PLUMBING			
	NEW PIPING		OS&Y GATE VALVE
	EXISTING PIPING TO REMAIN		PRESSURE REDUCING/REGULATING VALVE
	EXISTING PIPING TO BE DEMOLISHED		PRESSURE/SAFETY RELIEF VALVE
	NEW PIPE CONNECTION		STRAINER
	DIRECTION OF FLOW		STRAINER WITH BLOWDOWN VALVE
	DIRECTION OF PIPE PITCH, DOWN		THERMOSTATIC MIXING VALVE
	PIPE BREAK LINE (OR CONTINUATION)		BACKFLOW PREVENTER
	DOMESTIC COLD WATER PIPING		FLEXIBLE PIPE CONNECTOR (OR CONNECTION)
	DOMESTIC HOT WATER SUPPLY PIPING		HOSE BIBB
	DOMESTIC HOT WATER RETURN PIPING		METER
	DRAIN TILE PIPING		P-TRAP
	VENT PIPING		PIPE ALIGNMENT GUIDE
	CLEANOUT		PIPE ANCHOR
	ECCENTRIC PIPE REDUCER		PIPE SLEEVE
	ORIFICE PIPE UNION		PIPE WELL
	PIPE CAP		PRESSURE GAUGE
	PIPE ELBOW, 30° HORIZONTAL		PRV STATION
	PIPE ELBOW, 45° HORIZONTAL		PUMP
	PIPE ELBOW, 90° HORIZONTAL		SHOWER
	PIPE ELBOW, TURNED DOWN		TEST PLUG
	PIPE ELBOW, TURNED UP		THERMOMETER
	PIPE REDUCER/INCREASER		
NOTE: NOT ALL SYMBOLS LISTED ABOVE MAY BE USED OR APPEAR IN THESE DRAWINGS.			



KEY PLAN:

ISSUE/REVISION:

REV.	DATE	DESCRIPTION
111426		ISSUE FOR BID
110926		ISSUE FOR ADDENDUM NO. 1

PROJECT:
GUARANTEED RATE FIELD -
WASTE/VENT PIPING FY2026


333 W 35TH STREET,
CHICAGO, ILLINOIS 60616

DRAWING TITLE:
PLUMBING TITLE SHEET

DESIGNED BY: CF
CHECKED BY: MS
PROJECT NO: 25081
SCALE: NO SCALE

SHEET NO.

P0.001

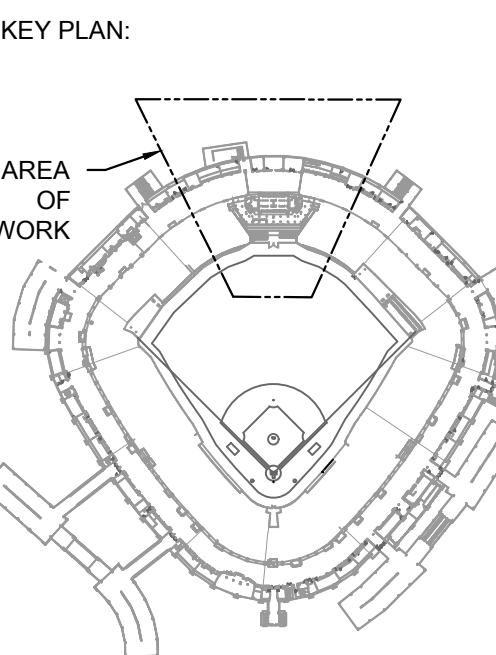

ISSUE/REVISION:		
REV.	DATE	DESCRIPTION
111425		ISSUE FOR BID
110925		ISSUE FOR ADDENDUM NO. 1

PROJECT:
GUARANTEED RATE FIELD -
WASTE/VENT PIPING FY2026

333 W 35TH STREET,
CHICAGO, ILLINOIS 60616

DRAWING TITLE:
PLUMBING PLAN -
UNDERGROUND - SECTION 1

DESIGNED BY: CF
CHECKED BY: MS
PROJECT NO: 25081
SCALE: 1/8" = 1'-0"


SHEET NO.
P1.U01

KEYED PLUMBING SHEET NOTES

1. RESCOPE TO CONFIRM ROUTING IDENTIFIED BY PRIOR SCOPING INFORMATION. RESCOPE THE ENTIRE STRAIGHT RUN OF PIPE.

1 PLUMBING PLAN - UNDERGROUND LEVEL - SECTION 1 ENLARGED

SCALE: 1/8" = 1'-0"

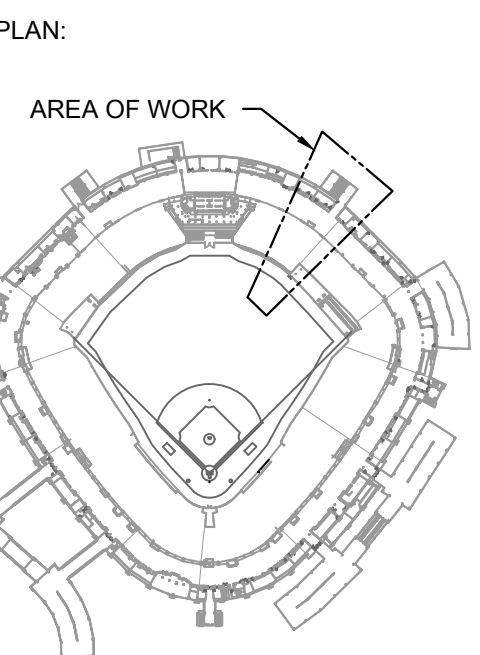[illegible]

PROJECT: GUARANTEED RATE FIELD -
WASTE/WENT PIPING FY2026
35TH STREET,
CHICAGO, ILLINOIS 60616


PROJECT TITLE: SWIMMING PLAN -
UNDERGROUND - SECTION 2

DESIGNED BY:	CF
CHECKED BY:	MS
PROJECT NO:	25081
SCALE:	1/8" = 1'-0"

T NO. 1


P1.U02

1 PLUMBING PLAN - UNDERGROUND LEVEL - SECTION 2 ENLARGED FOR REFERENCE ONLY

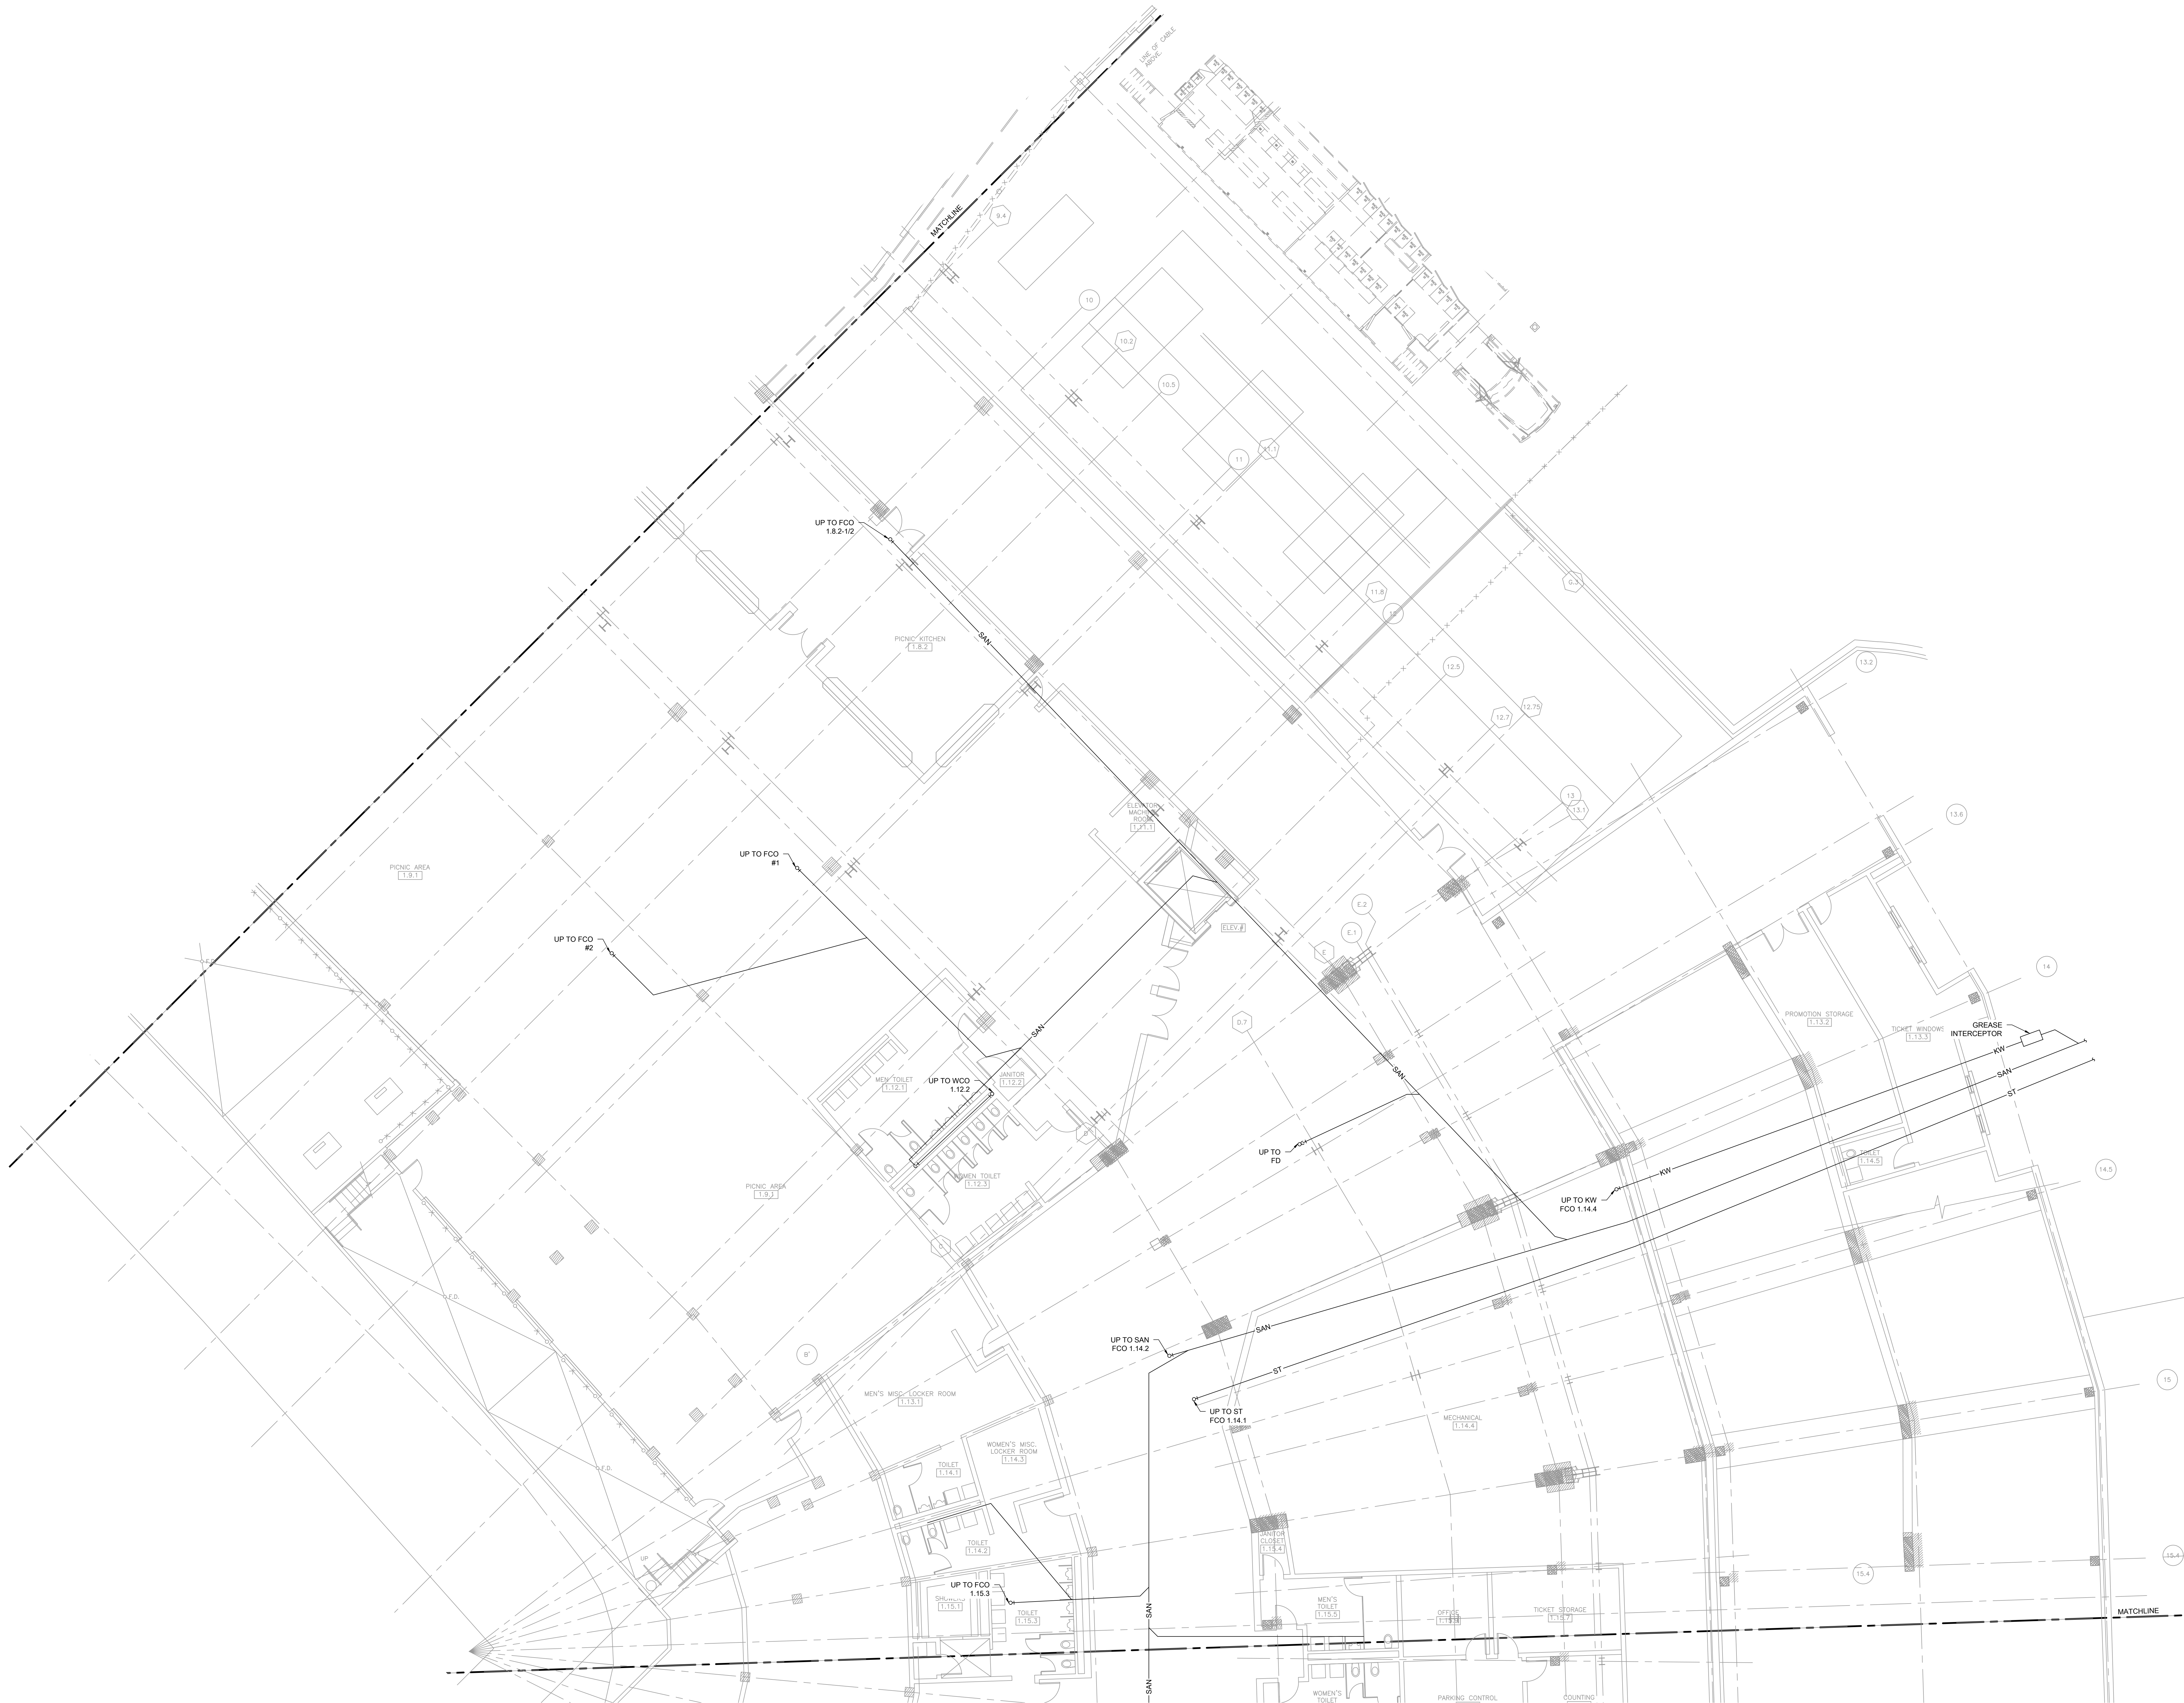


1 PLUMBING PLAN - UNDERGROUND LEVEL - SECTION 3 ENLARGED
SCALE: 1/8" = 1'-0"

FOR REFERENCE ONLY

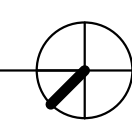

KEY PLAN:

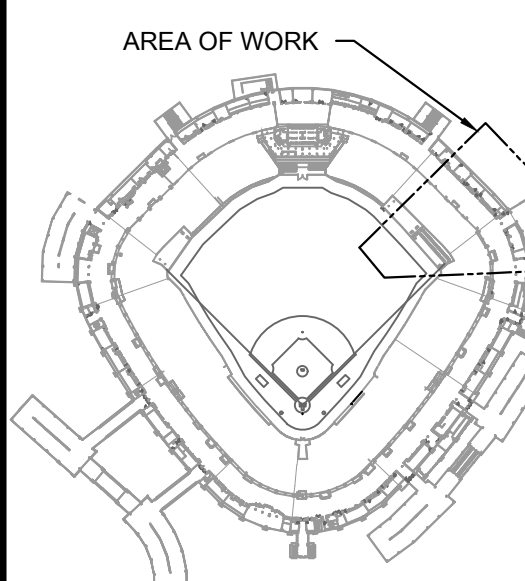

ISSUE/REVISION:

REV.	DATE	DESCRIPTION
111425		ISSUE FOR BID
110925		ISSUE FOR ADDENDUM NO. 1


PROJECT:
GUARANTEED RATE FIELD -
WASTE/VENT PIPING FY2026

333 W 35TH STREET,
CHICAGO, ILLINOIS 60616

DRAWING TITLE:
PLUMBING PLAN -
UNDERGROUND - SECTION 3

DESIGNED BY: CF
CHECKED BY: MS
PROJECT NO.: 25081
SCALE: 1/8" = 1'-0"

SHEET NO.
P1.U03

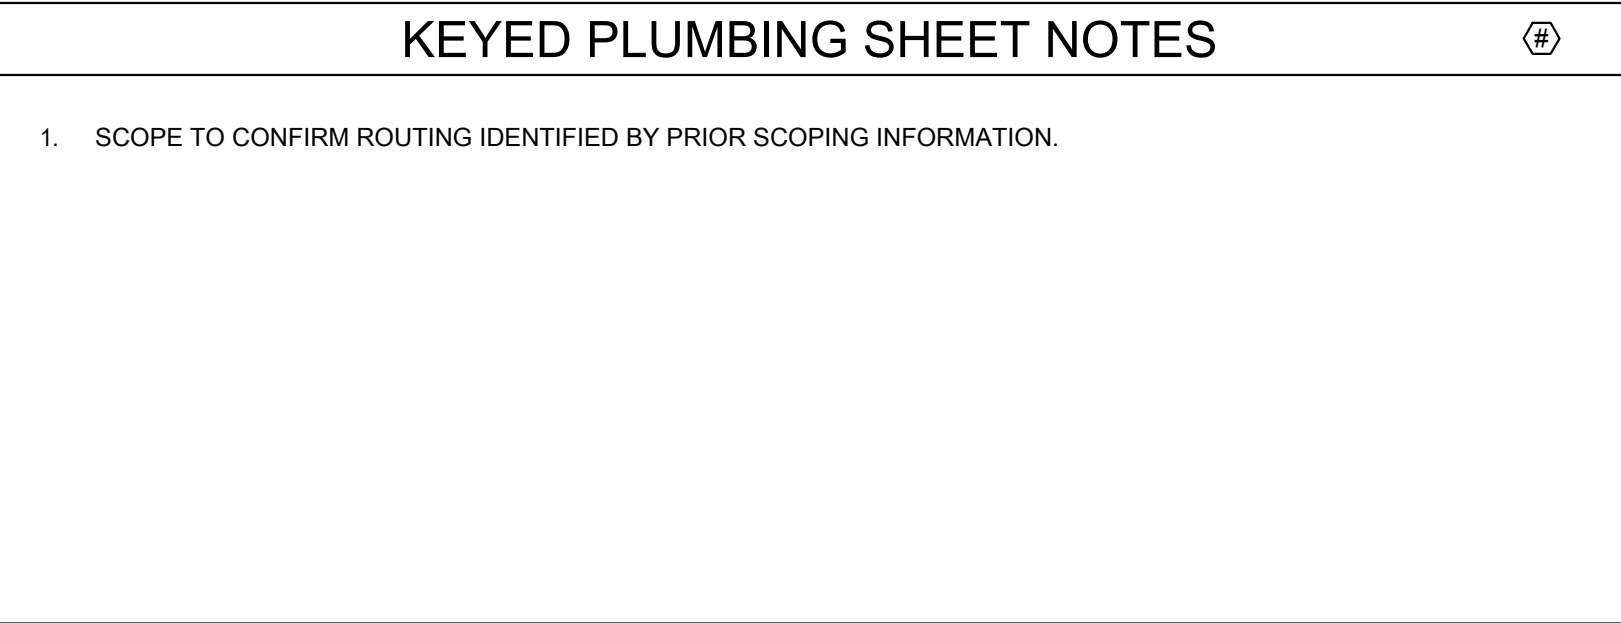

A diagram of a baseball field from a top-down perspective. The field is outlined with a dashed line. The pitcher's mound is at the center, and the bases are marked. An arrow points from the text 'AREA OF WORK' to a specific region on the right side of the field, between the first and second base lines, indicating the study area.


SHEET NO. 1

P1.U05



NO. 1

P1.U06}

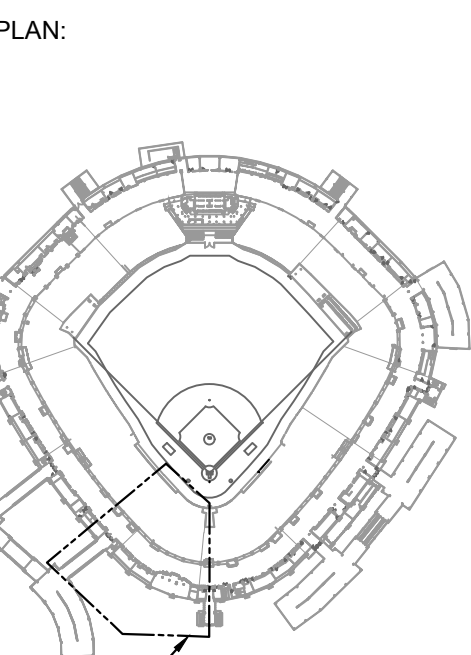

DATE	DESCRIPTION
11/14/25	ISSUE FOR BID
11/20/25	ISSUE FOR ADDENDUM NO. 1


CLIMBING PLAN -
UNDERGROUND - SECTION 7

DESIGNED BY:	CF
CHECKED BY:	MS
PROJECT NO:	25081
SCALE:	1/8" = 1'-0"

T NO. 1


P1.U07 }

 FOR REFERENCE ONLY





KEY PLAN:

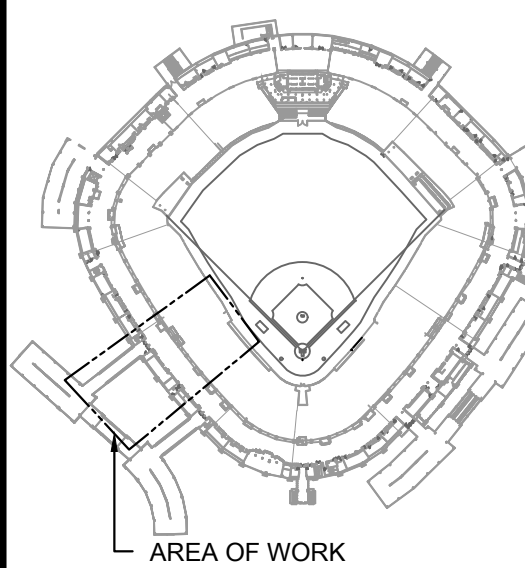

AREA OF WORK

ISSUE/REVISION:

REV.	DATE	DESCRIPTION
111425		ISSUE FOR BID
110925		ISSUE FOR ADDENDUM NO. 1

PROJECT:
GUARANTEED RATE FIELD -
WASTE/VENT PIPING FY2026

333 W 35TH STREET,
CHICAGO, ILLINOIS 60616

DRAWING TITLE:
PLUMBING PLAN -
UNDERGROUND - SECTION 8

DESIGNED BY: CF
CHECKED BY: MS
PROJECT NO: 25081
SCALE: 1/8" = 1'-0"

SHEET NO.

P1.U08



1 PLUMBING PLAN - UNDERGROUND LEVEL - SECTION 8 ENLARGED

SCALE: 1/8" = 1'-0"



KEYED PLUMBING SHEET NOTES

1. RESCOPE TO CONFIRM ROUTING IDENTIFIED BY PRIOR SCOPING INFORMATION.
2. IN PAST VIDEOS, THIS PORTION OF PIPING WAS OBSCURED BY DEBRIS IN THE PIPING.
3. RESCOPE PIPING TO CONFIRM CURRENT PIPE CONDITION.

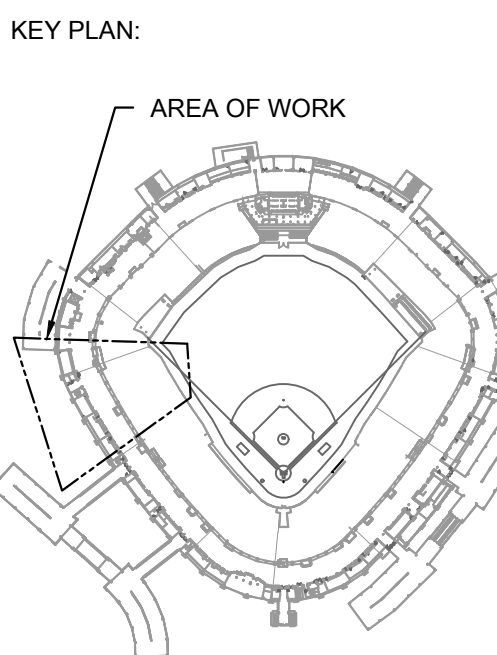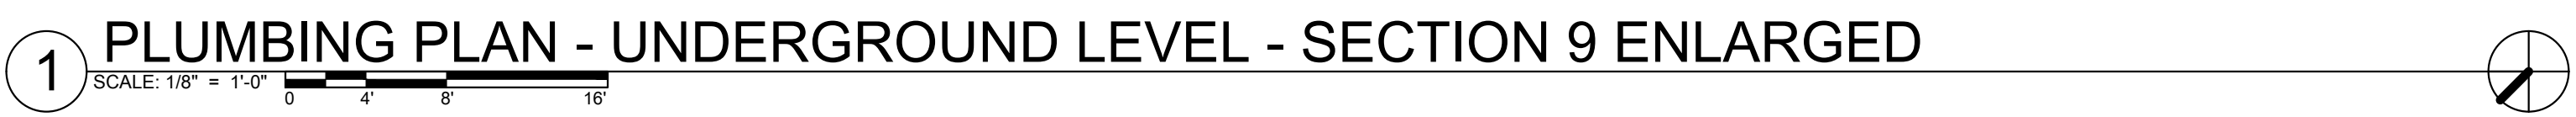[illegible]

PROJECT:
GUARANTEED RATE FIELD -
WASTE/VENT PIPING FY2026

333 W 35TH STREET,
CHICAGO, ILLINOIS 60616

DRAWING TITLE:


PLUMBING PLAN -
UNDERGROUND - SECTION 9

DESIGNED BY:	CF
CHECKED BY:	MS
PROJECT NO:	25081
SCALE:	1/8" = 1'-0"

SHEET NO. _____

P1.U09

KEY PLAN:

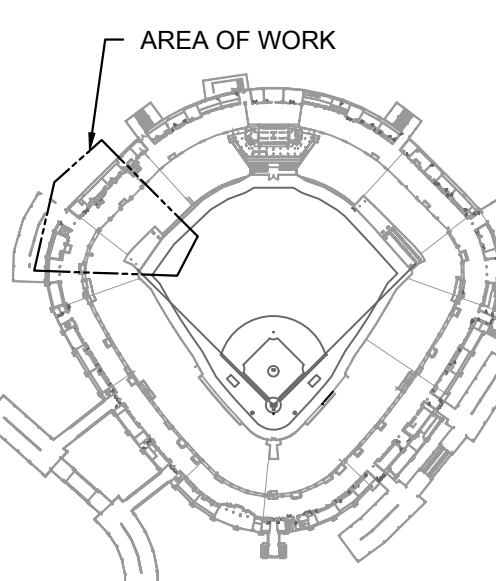

ISSUE/REVISION:

REV.	DATE	DESCRIPTION
1111425		ISSUE FOR BID
1109025		ISSUE FOR ADDENDUM NO. 1

PROJECT:
GUARANTEED RATE FIELD -
WASTE/VENT PIPING FY2026


333 W 35TH STREET,
CHICAGO, ILLINOIS 60616

DRAWING TITLE:
PLUMBING PLAN -
UNDERGROUND - SECTION 10

DESIGNED BY: CF
CHECKED BY: MS
PROJECT NO: 25081
SCALE: 1/8" = 1'-0"


SHEET NO.


P1.U10

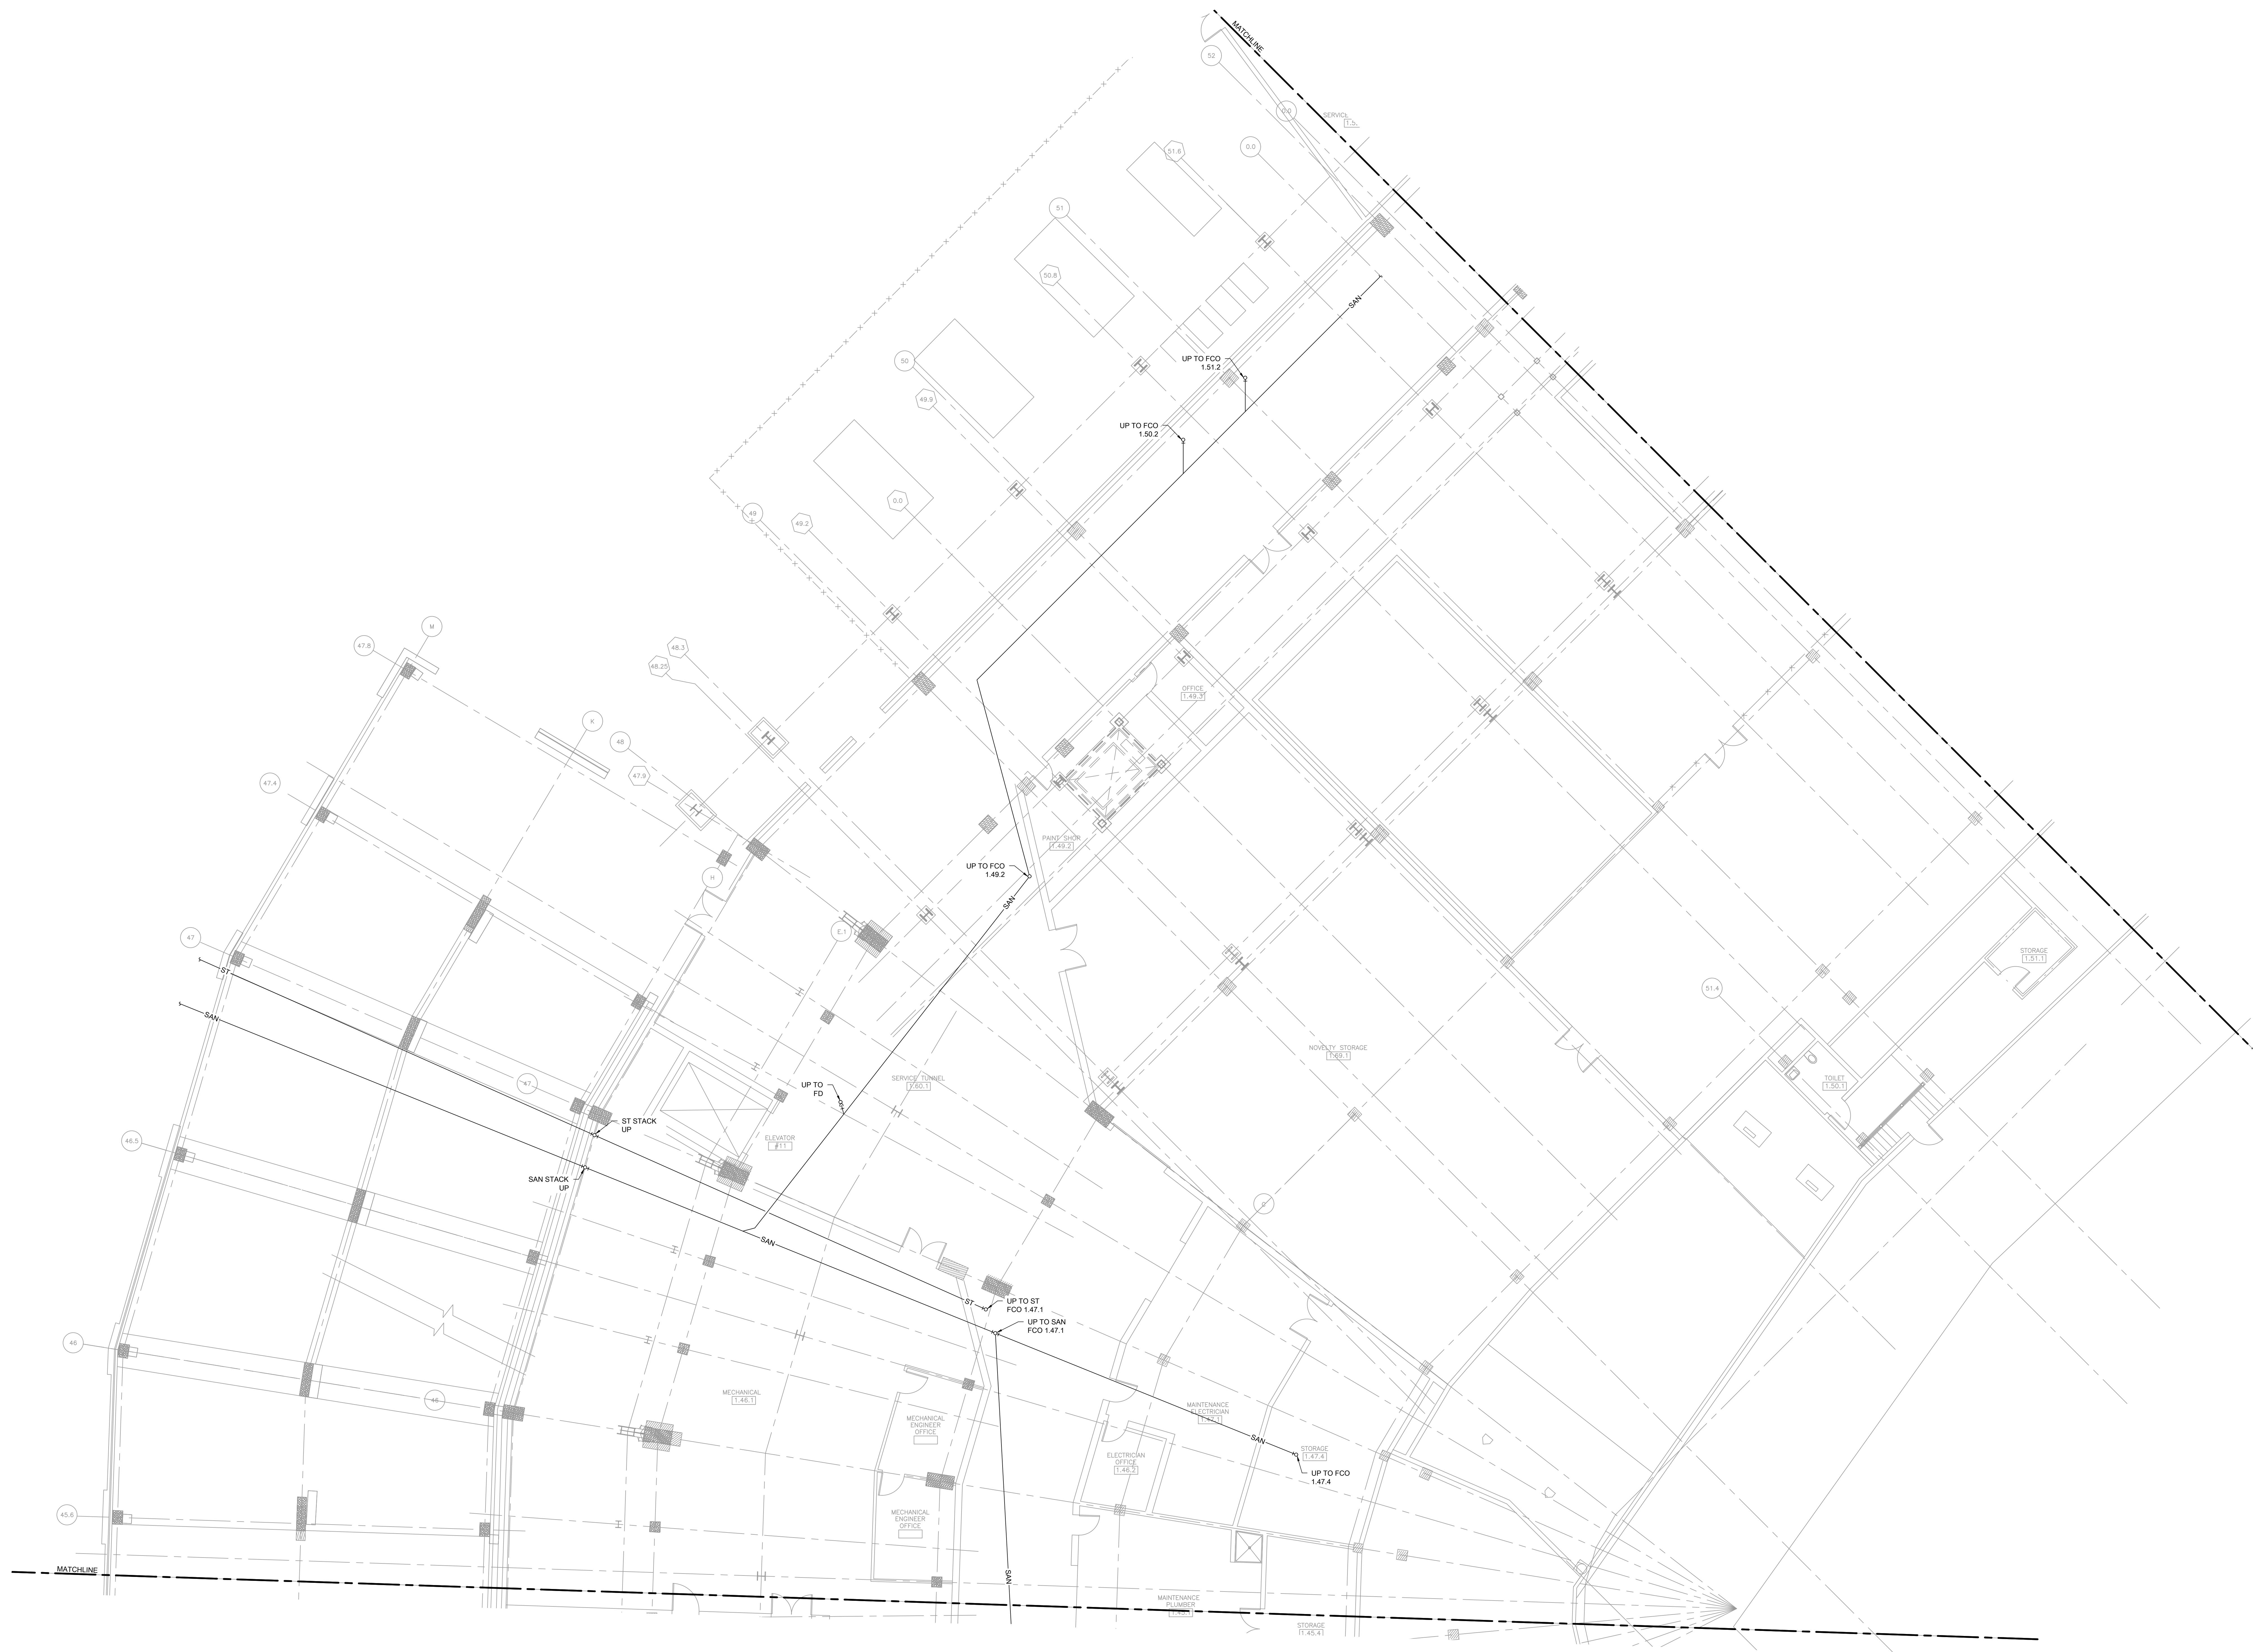

1 PLUMBING PLAN - UNDERGROUND LEVEL - SECTION 10 ENLARGED
SCALE: 1/8" = 1'-0"

 FOR REFERENCE ONLY



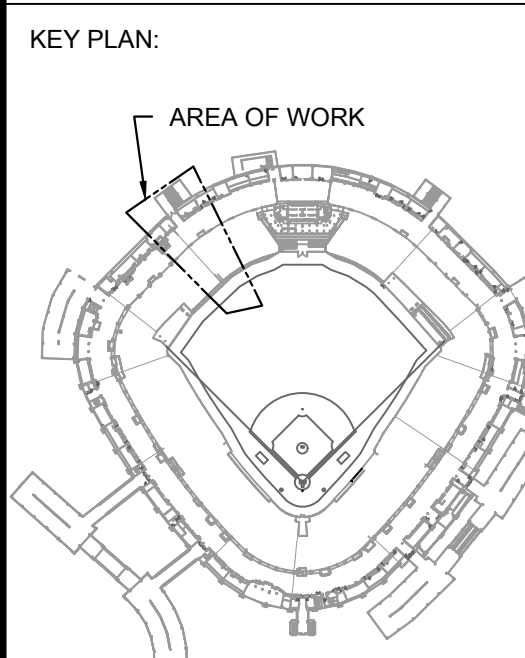

ISSUE/REVISION:		
REV.	DATE	DESCRIPTION
1	11/14/25	ISSUE FOR BID
2	11/09/25	ISSUE FOR ADDENDUM NO. 1


PROJECT:
GUARANTEED RATE FIELD -
WASTE/VENT PIPING FY2026

333 W 35TH STREET,
CHICAGO, ILLINOIS 60616

DRAWING TITLE:
PLUMBING PLAN -
UNDERGROUND - SECTION 11

DESIGNED BY: CF
CHECKED BY: MS
PROJECT NO: 25081
SCALE: 1/8" = 1'-0"


SHEET NO.
P1.U11

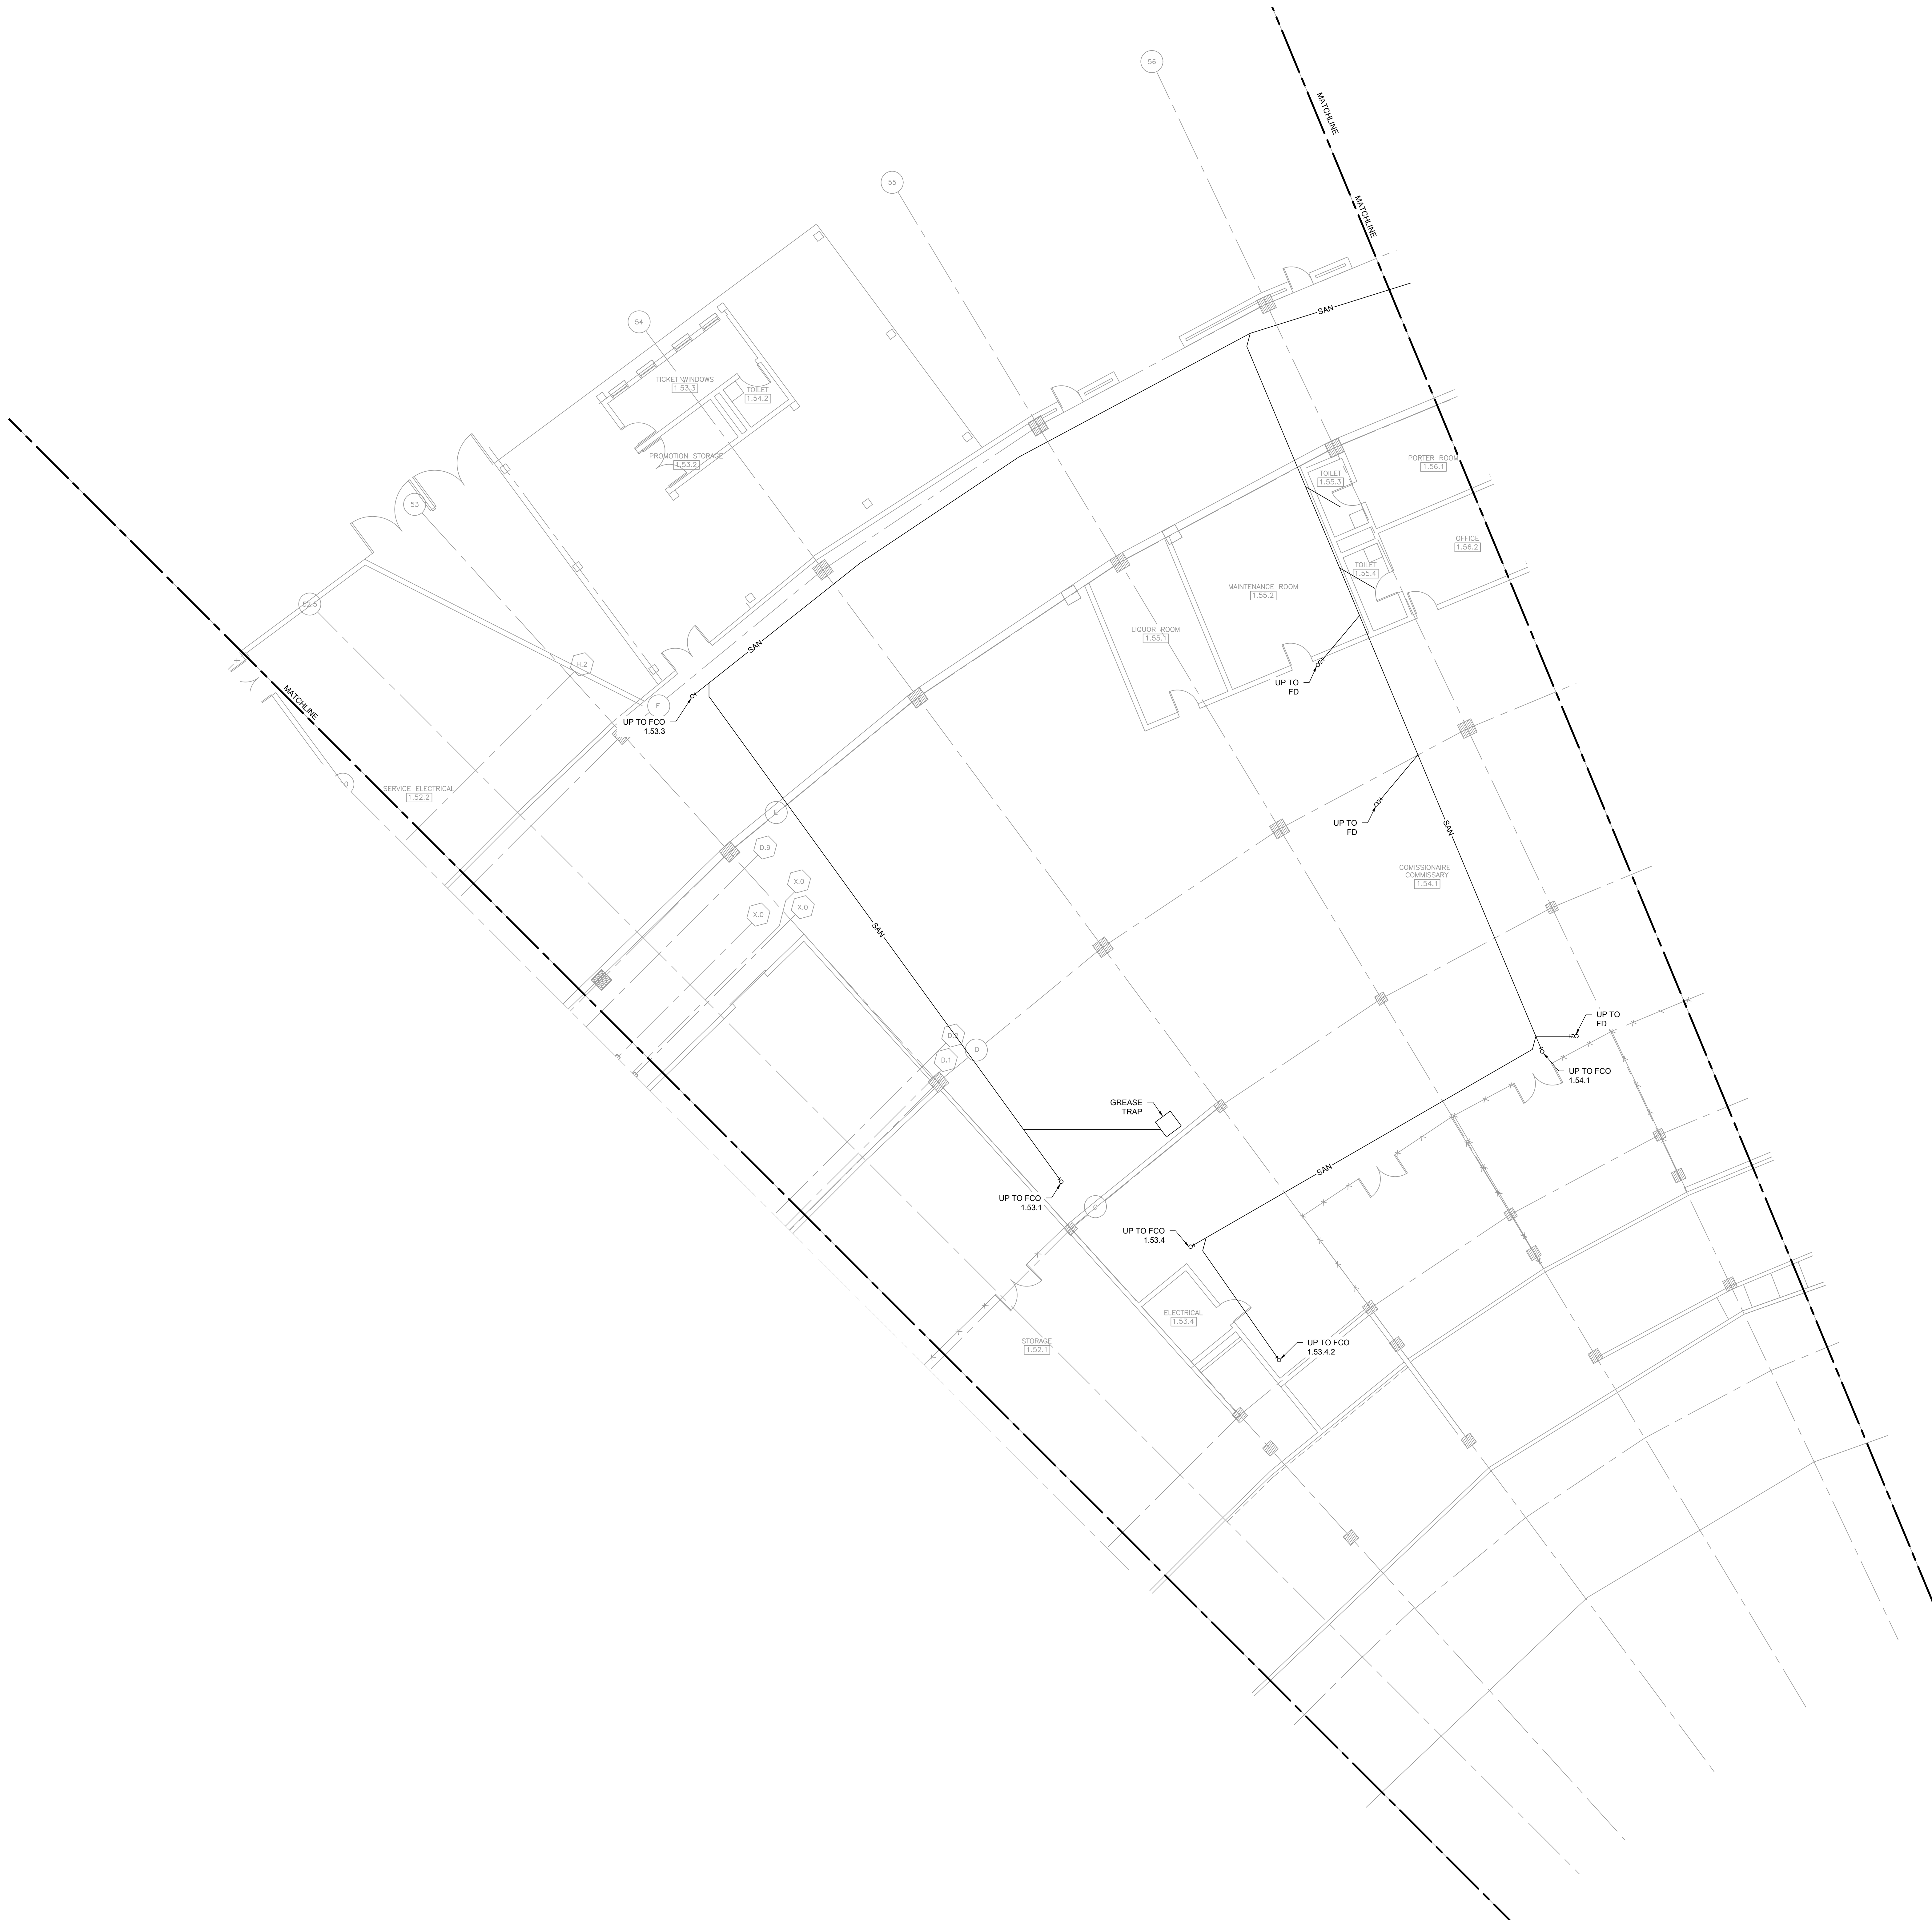

1 PLUMBING PLAN - UNDERGROUND LEVEL - SECTION 11 ENLARGED

FOR REFERENCE ONLY

KEY PLAN:

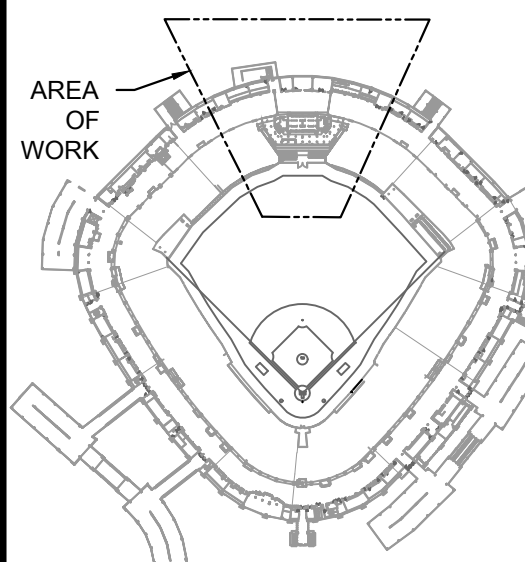

ISSUE/REVISION:

REV.	DATE	DESCRIPTION
11/14/25		ISSUE FOR BID
11/09/25		ISSUE FOR ADDENDUM NO. 1


PROJECT:
GUARANTEED RATE FIELD -
WASTE/VENT PIPING FY2026

333 W 35TH STREET,
CHICAGO, ILLINOIS 60616


DRAWING TITLE:
PLUMBING PLAN - SERVICE
LEVEL - SECTION 1

DESIGNED BY: CF
CHECKED BY: MS
PROJECT NO: 25081
SCALE: 1/8" = 1'-0"
SHEET NO.

P1.S01

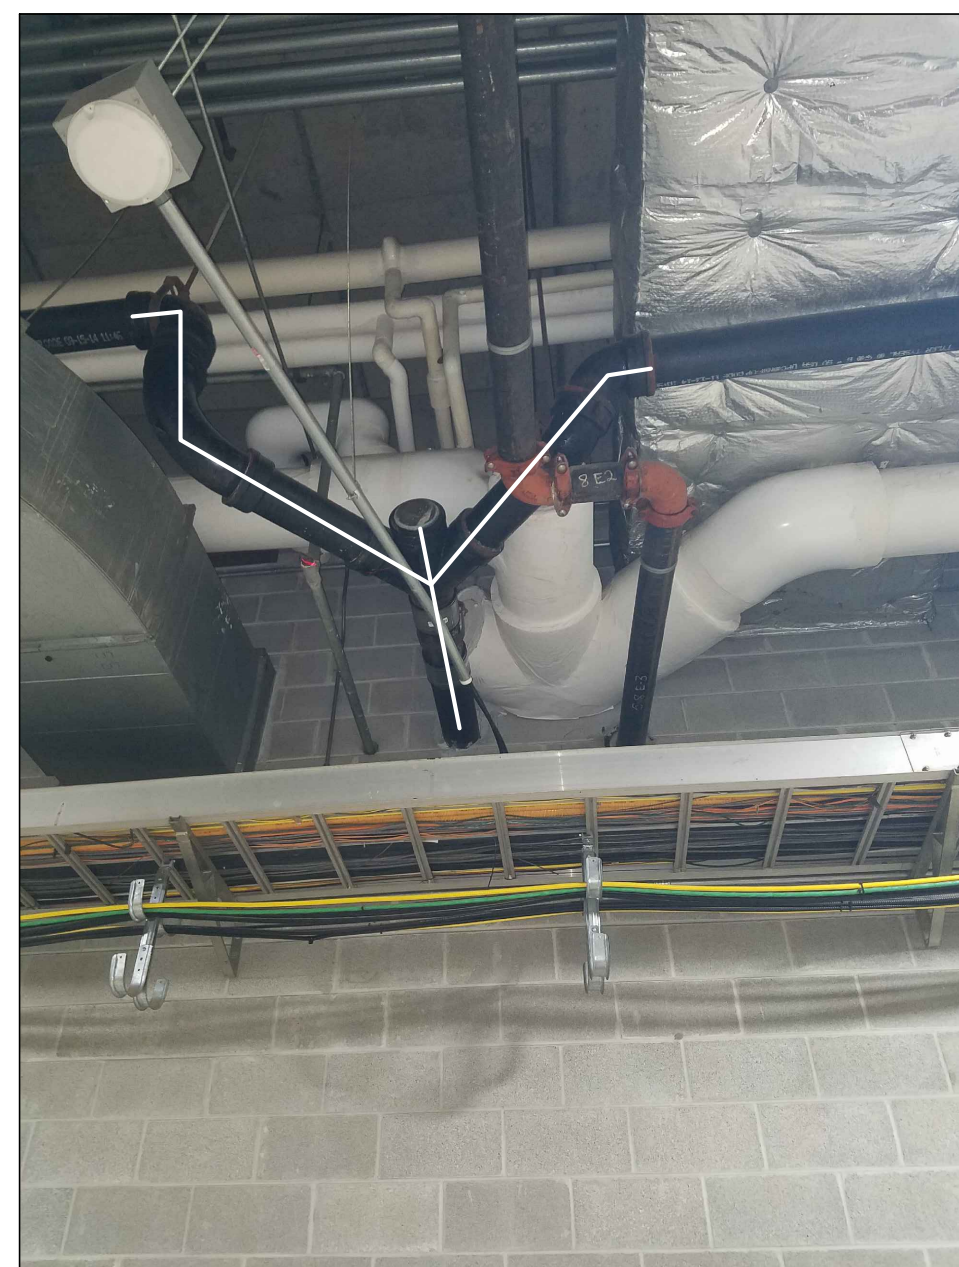

2 TUNNEL SERVICE 1.60.1 - SANITARY PIPING
SCALE: NO SCALE

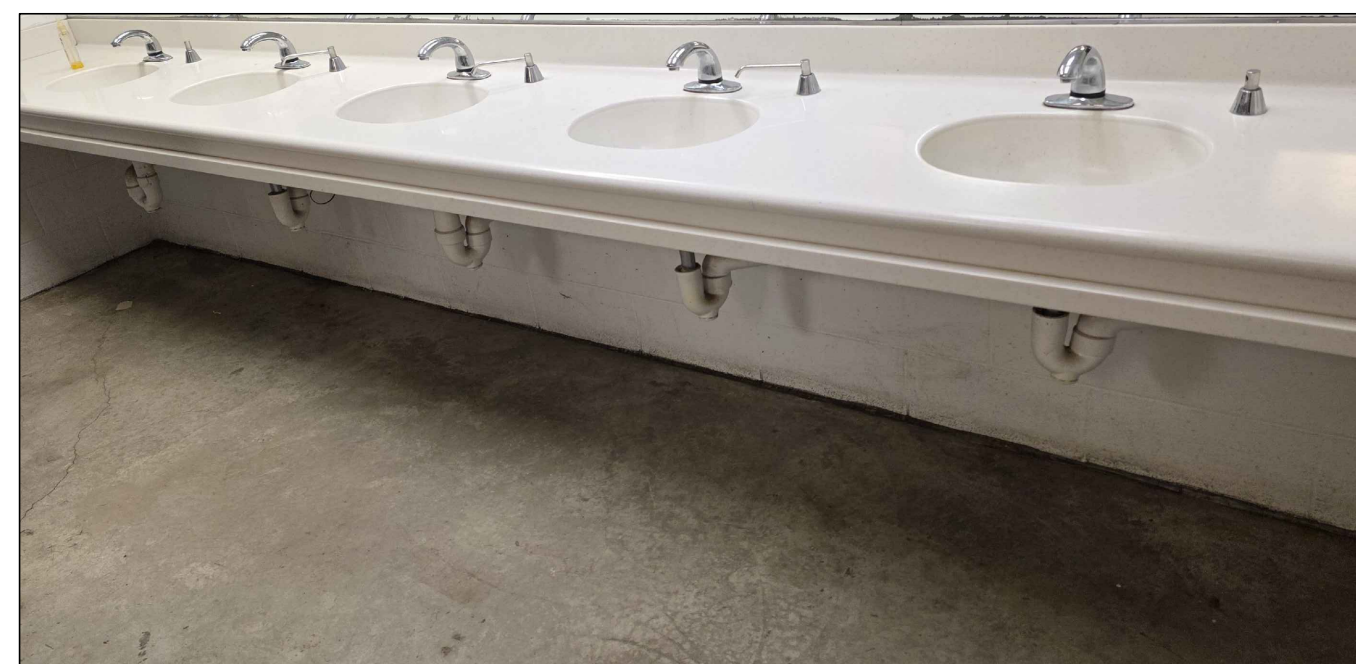


3 TC FAUCETS
SCALE: NO SCALE

KEYED PLUMBING SHEET NOTES

- VERIFY LAVATORY FAUCET IS OLDER OBSOLETE TO FAUCET MODEL. WHERE OLDER OBSOLETE TO FAUCET MODEL IS PRESENT, REPLACE THE TO FAUCET WITH NEW REPLACEMENT SYMMONS FAUCET MODEL (SYMMONS MODEL S690B). REUSE EXISTING NON-FAUCET COMPONENTS SUCH AS WATER SUPPLY STOP VALVES, ETC. PROVIDE ALL NEW WATER SUPPLY TUBING AND NEW ADA PIPE INSULATION FOR P-TRAP, DRAINAGE PIPING, AND WATER PIPING. PROVIDE NEW SYMMONS MODEL 6210CK THERMOSTATIC MIXING VALVE. THE NUMBER OF FAUCETS TO VERIFY IS IDENTIFIED ON PLANS WITH CIRCLE TAG.
- PORTIONS OF EXISTING PIPING ARE ORIGINAL AND FAUCETS DEMOLISHED IN THE PAST. DEMOLISH AND REPLACE PIPING, FITTINGS, ETC. IDENTIFIED WITH WHITE LINES IN PHOTOS ON THIS SHEET.


1 PLUMBING PLAN - SERVICE LEVEL - SECTION 1 ENLARGED
SCALE: 1/8" = 1'-0"

4 MECHANICAL ROOM 1.1.5 - SANITARY PIPING
SCALE: NO SCALE

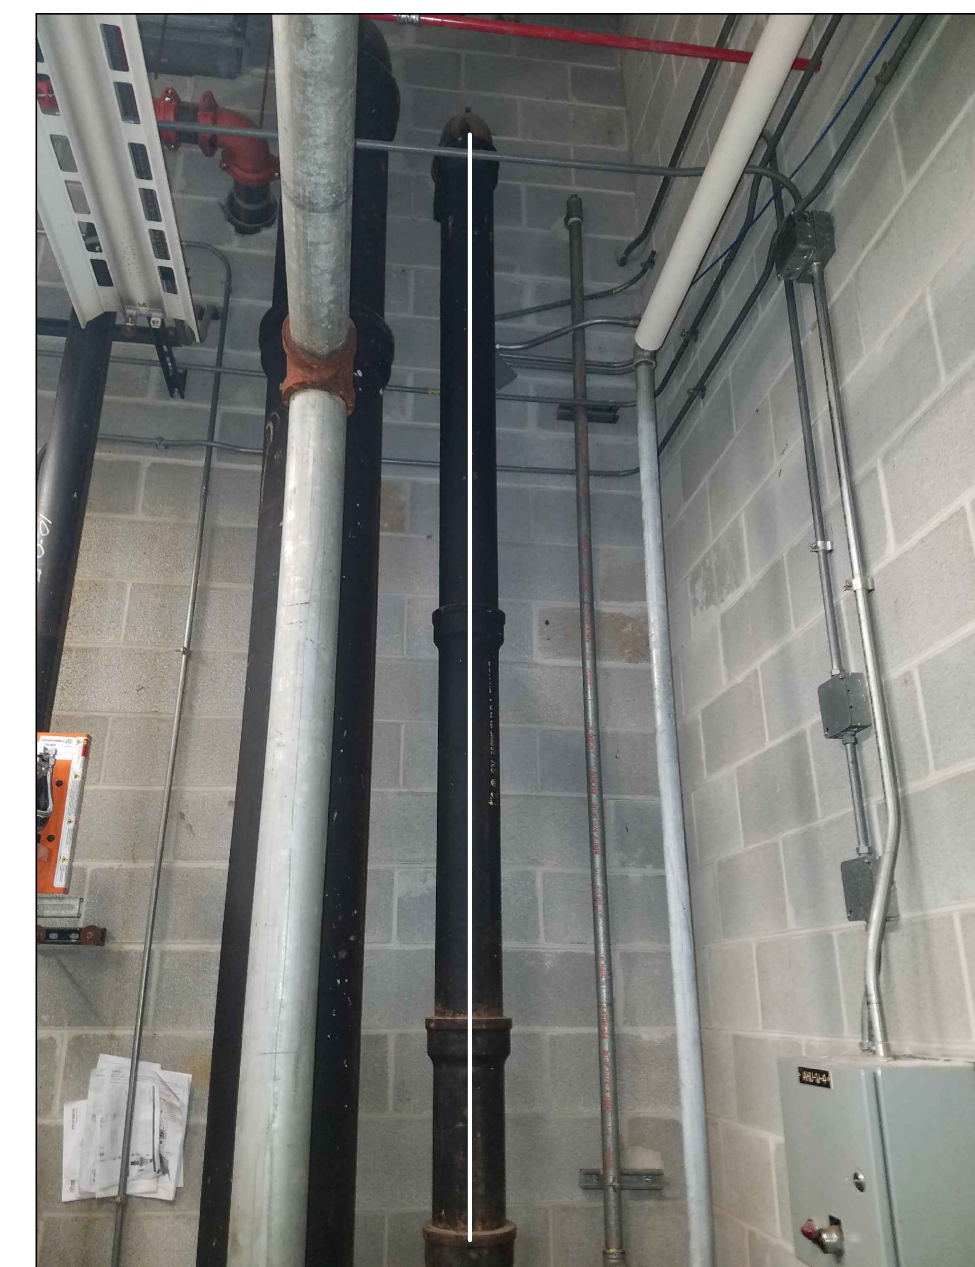

5 MECHANICAL ROOM 1.1.5 - SANITARY PIPING
SCALE: NO SCALE



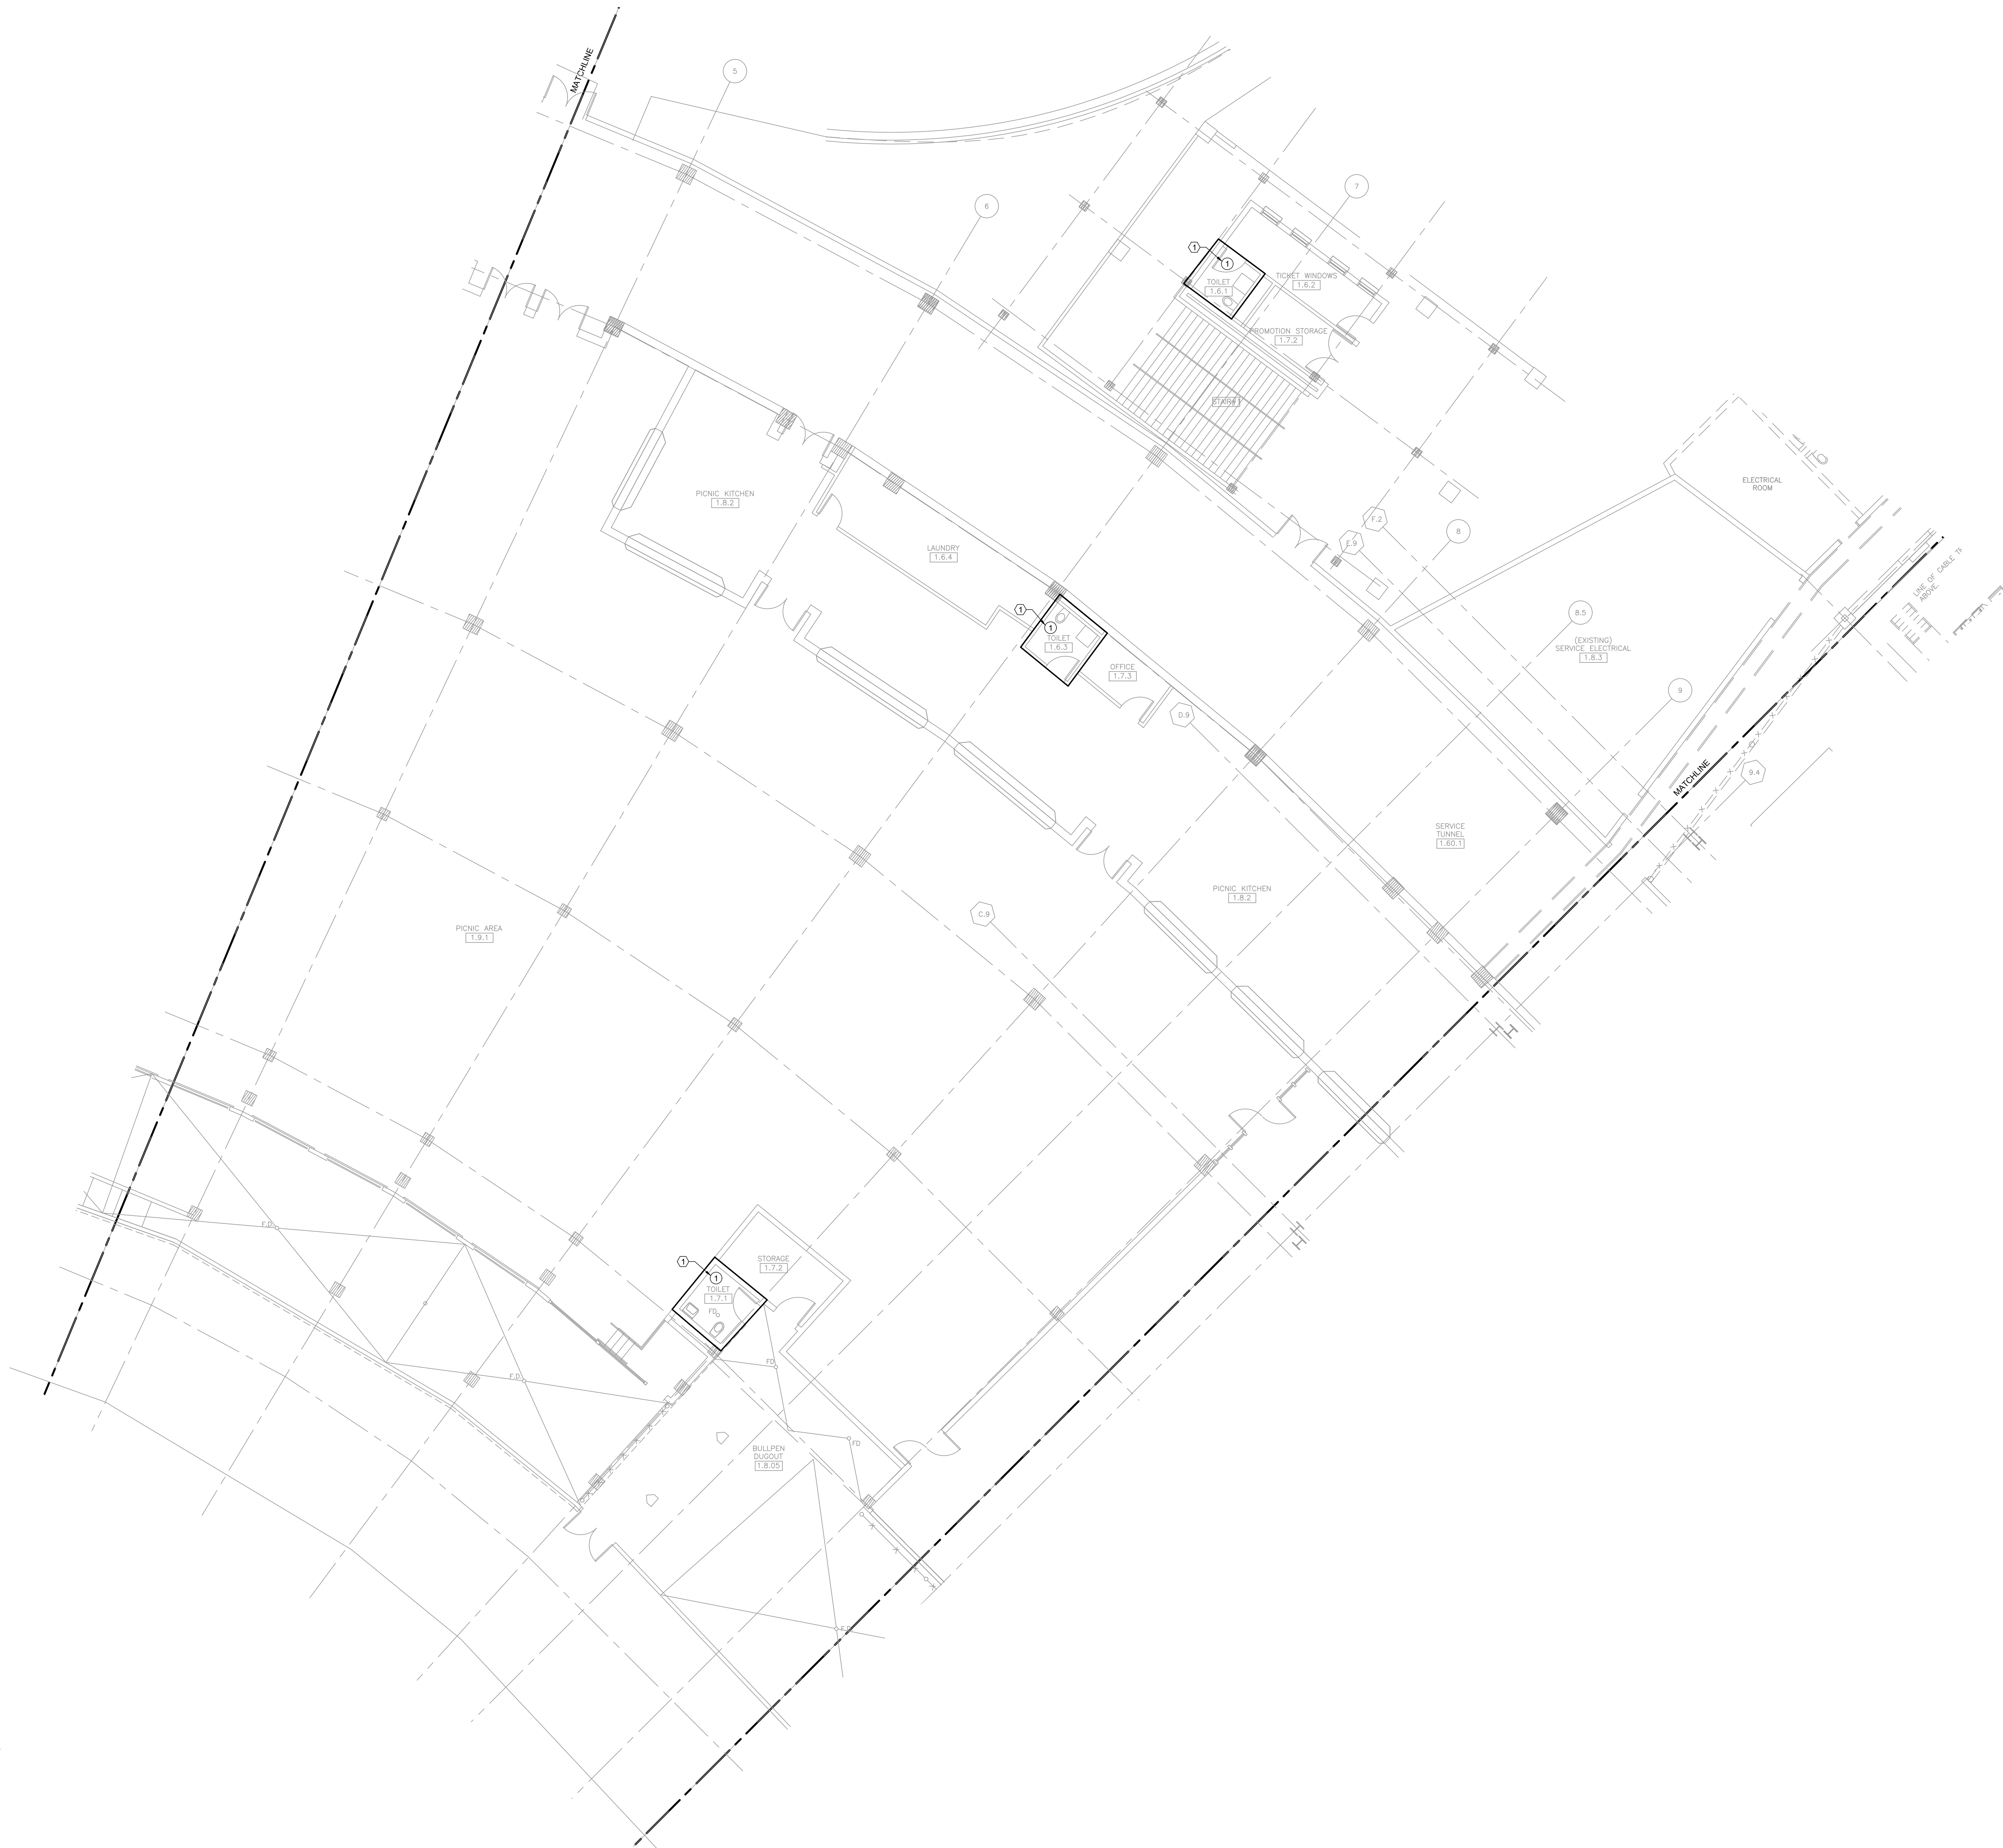

KEYED PLUMBING SHEET NOTES


1. VERIFY LAVATORY FAUCET IS OLDER OBSOLETE TC FAUCET MODEL. WHERE OLDER OBSOLETE TC FAUCET MODEL IS PRESENT, REPLACE THE TC FAUCET WITH NEW REPLACEMENT SYMMONS FAUCET MODEL (SYMMONS MODEL 66800). REUSE EXISTING NON-FAUCET COMPONENTS SUCH AS WATER SUPPLY STOP VALVES, ETC. PROVIDE ALL NEW WATER SUPPLY TUBING AND NEW ADA PIPE INSULATION FOR R-TRAP, DRAINAGE PIPING, AND WATER PIPING. PROVIDE NEW SYMMONS MODEL 6210CK THERMOSTATIC MIXING VALVE. THE NUMBER OF FAUCETS TO VERIFY IS IDENTIFIED ON PLANS WITH CIRCLE TAG.

1 PLUMBING PLAN - SERVICE LEVEL - SECTION 2 ENLARGED

SCALE: 1/8" = 1'-0"



KEY PLAN:

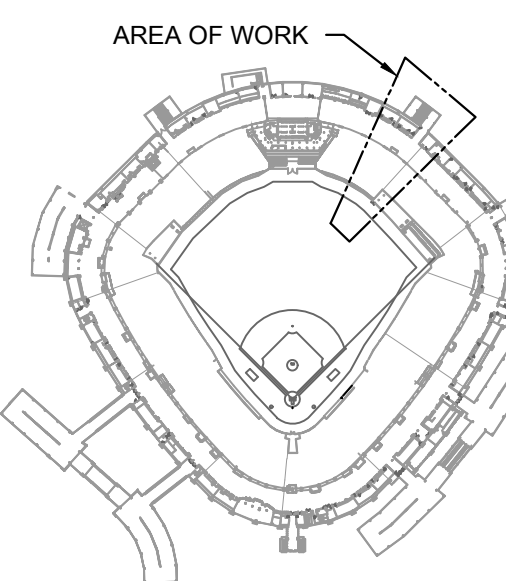

ISSUE/REVISION:

REV.	DATE	DESCRIPTION
111425		ISSUE FOR BID
110925		ISSUE FOR ADDENDUM NO. 1

PROJECT:
GUARANTEED RATE FIELD -
WASTE/VENT PIPING FY2026


333 W 35TH STREET,
CHICAGO, ILLINOIS 60616

DRAWING TITLE:
PLUMBING PLAN - SERVICE
LEVEL - SECTION 2

DESIGNED BY: CF
CHECKED BY: MS
PROJECT NO: 25081
SCALE: 1/8" = 1'-0"

SHEET NO.


P1.S02

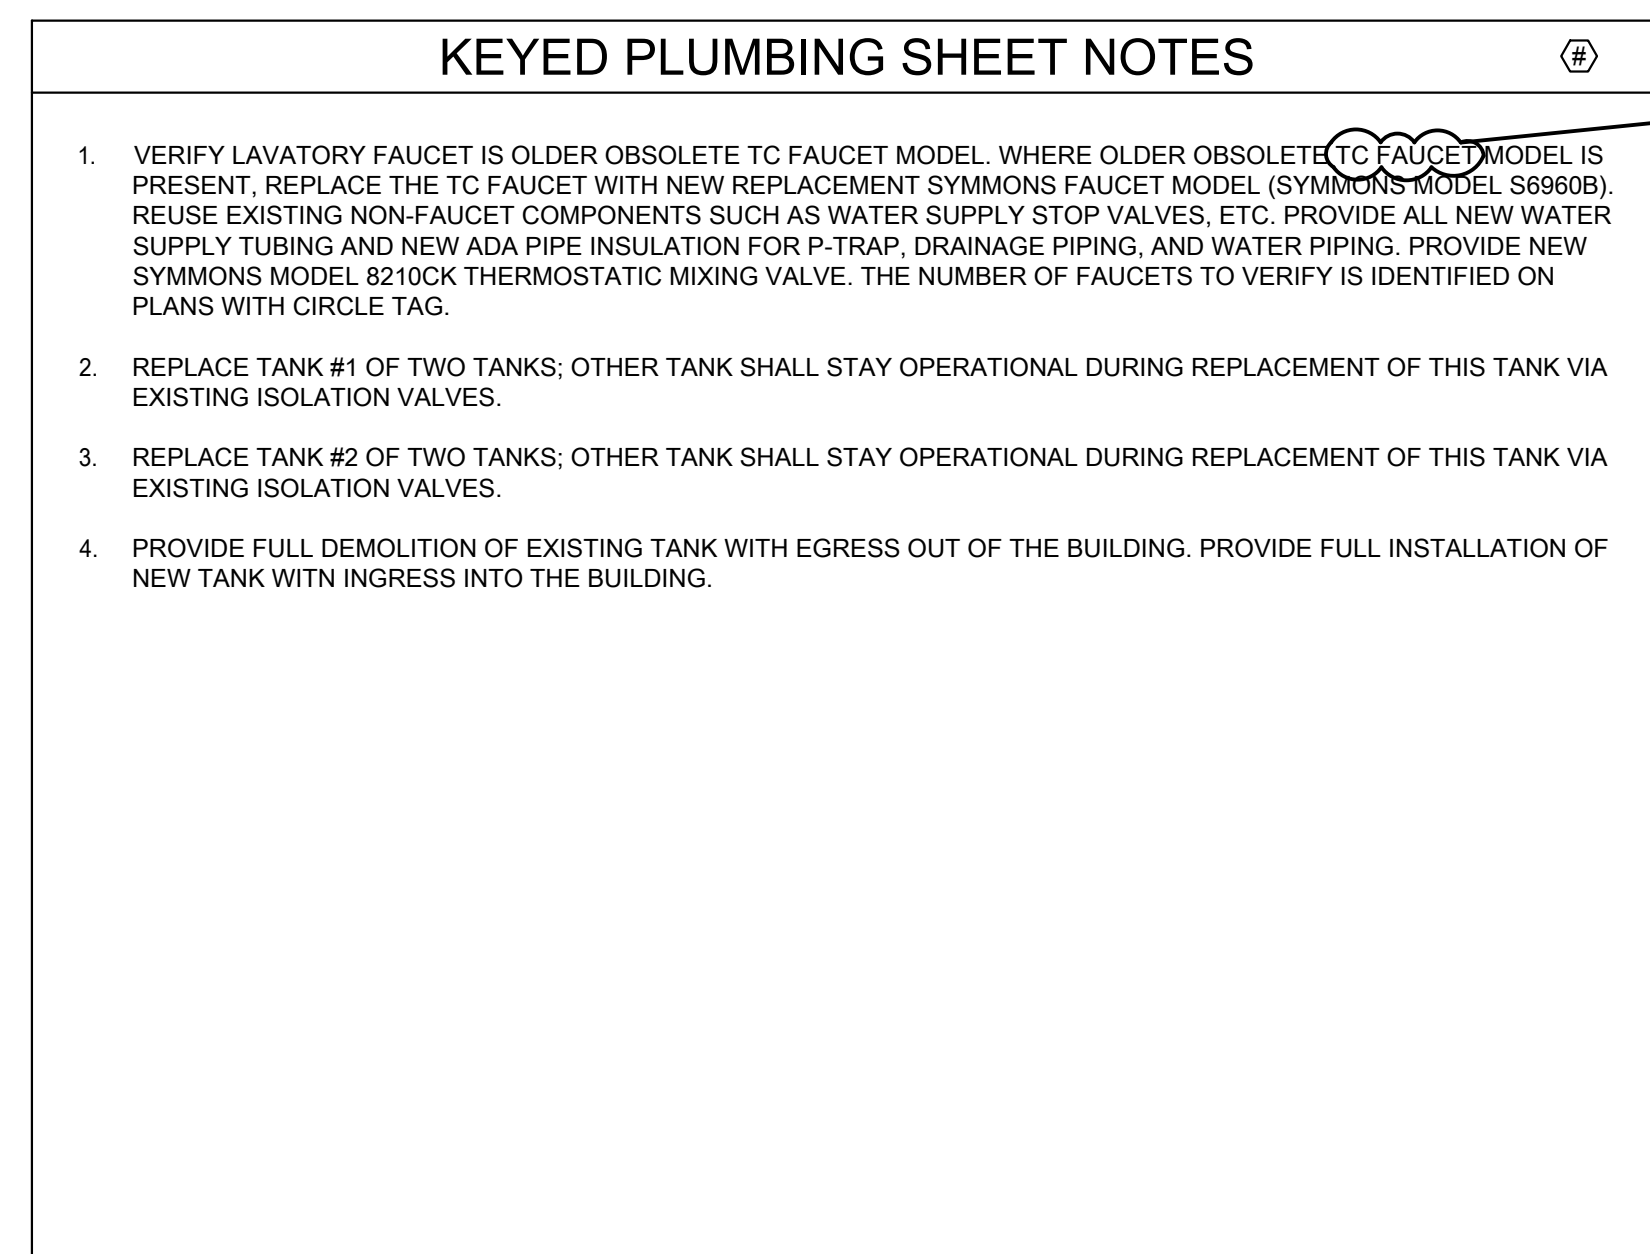

1 PLUMBING PLAN - SERVICE LEVEL - SECTION 3 ENLARGED
SCALE: 1/8" = 1'-0"
0 4' 8' 16'



PLAN:

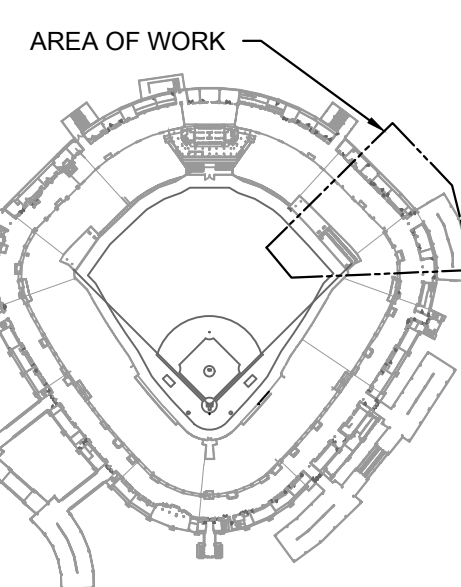

E/REVISION:

DATE	DESCRIPTION
11/14/25	ISSUE FOR BID
11/26/25	ISSUE FOR ADDENDUM NO. 1

GUARANTEED RATE FIELD -
STE/VENT PIPING FY2026

35TH STREET,
CHICAGO, ILLINOIS 60616

CLIMBING PLAN - SERVICE
TOWER - SECTION 3

DESIGNED BY: CF

WITNESSED BY: MS

ECT NO:	25081
---------	-------

E: $1/8" = 1'-0"$

T NO.

P1.S03




KEYED PLUMBING SHEET NOTES

1. VERIFY LAVATORY FAUCET IS OLDER OBSOLETE TC FAUCET MODEL, WHERE OLDER OBSOLETE TC FAUCET MODEL IS PRESENT, REPLACE THE TC FAUCET WITH NEW REPLACEMENT SYMMONS FAUCET MODEL (SYMMONS MODEL S6900B). REUSE EXISTING NON-FAUCET COMPONENTS SUCH AS WATER SUPPLY STOP VALVES, ETC. PROVIDE ALL NEW WATER SUPPLY TUBING AND NEW ADA PIPE INSULATION FOR P-TRAP, DRAINAGE PIPING, AND WATER PIPING. PROVIDE NEW SYMMONS MODEL 8210CK THERMOSTATIC MIXING VALVE. THE NUMBER OF FAUCETS TO VERIFY IS IDENTIFIED ON PLANS WITH CIRCLE TAG.

1 PLUMBING PLAN - SERVICE LEVEL - SECTION 4 ENLARGED

KEY PLAN:

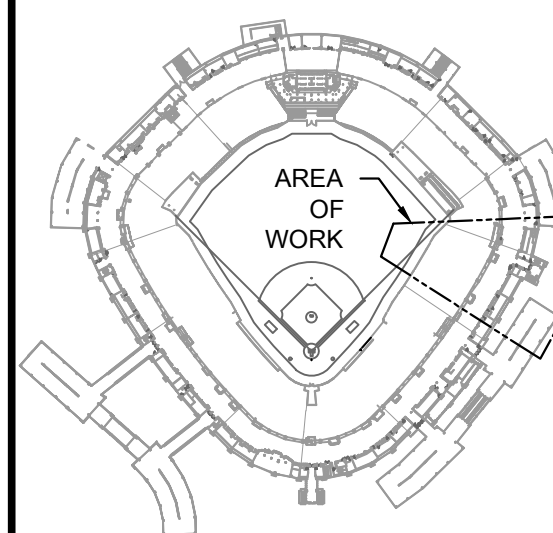

ISSUE/REVISION:

REV.	DATE	DESCRIPTION
111425		ISSUE FOR BID
110925		ISSUE FOR ADDENDUM NO. 1

PROJECT:

GUARANTEED RATE FIELD -
WASTE/VENT PIPING FY2026

333 W 35TH STREET,
CHICAGO, ILLINOIS 60616

DRAWING TITLE:

PLUMBING PLAN - SERVICE
LEVEL - SECTION 4

DESIGNED BY: CF

CHECKED BY: MS

PROJECT NO: 25081

SCALE: 1/8" = 1'-0"


SHEET NO.

[illegible]


P1.S05



- KEYED PLUMBING SHEET NOTES**
1. VERIFY LAVATORY FAUCET IS OLDER OBSOLETE TC FAUCET MODEL. WHERE OLDER OBSOLETE TC FAUCET MODEL IS PRESENT, REPLACE THE TC FAUCET WITH NEW REPLACEMENT SYMMONS FAUCET MODEL (SYMMONS MODEL S6960B). REUSE EXISTING NON-FAUCET COMPONENTS SUCH AS WATER SUPPLY STOP VALVES, ETC. PROVIDE ALL NEW WATER SUPPLY TUBING AND NEW ADA PIPE INSULATION FOR P-TRAP, DRAINAGE PIPING, AND WATER PIPING. PROVIDE NEW SYMMONS MODEL 82100K THERMOSTATIC MIXING VALVE. THE NUMBER OF FAUCETS TO VERIFY IS IDENTIFIED ON PLANS WITH CIRCLE TAG.
 2. PROVIDE NEW ARW WATTS FRPP BLUELINE RIONFUSE CF (ELECTROFUSION) PIPING AND FITTINGS TO REPLACE EXISTING PORTIONS OF BEER STAND DRAINAGE PIPING. PROVIDE ADDITIONAL HANGERS AND SUPPORTS AS NECESSARY FOR THE DIFFERENT MATERIAL INSTALLED.
 3. PROVIDE NEW ARW WATTS FRPP BLUELINE RIONFUSE CF (ELECTROFUSION) PIPING AND FITTINGS TO REPLACE EXISTING PORTIONS OF BEER STAND VENT PIPING. PROVIDE ADDITIONAL HANGERS AND SUPPORTS AS NECESSARY FOR THE DIFFERENT MATERIAL INSTALLED.
 4. DEMOLISH AND REPLACE EXISTING SANITARY FROM GREASE INTERCEPTOR OUTLET PIPING ABOVE FROM RATE FIELD KITCHEN. THE EXISTING SANITARY IS CONNECTED TO STORM CURRENTLY. DISCONNECT OFF STORM PIPING AND PROVIDE NEW TIE-INS TO EXISTING SANITARY DRAINAGE PIPING. PROVIDE NEW PIPING AT DEMOLISHED PORTION OF THE STORM PIPING TO CORRECT THIS EXISTING CONDITION.

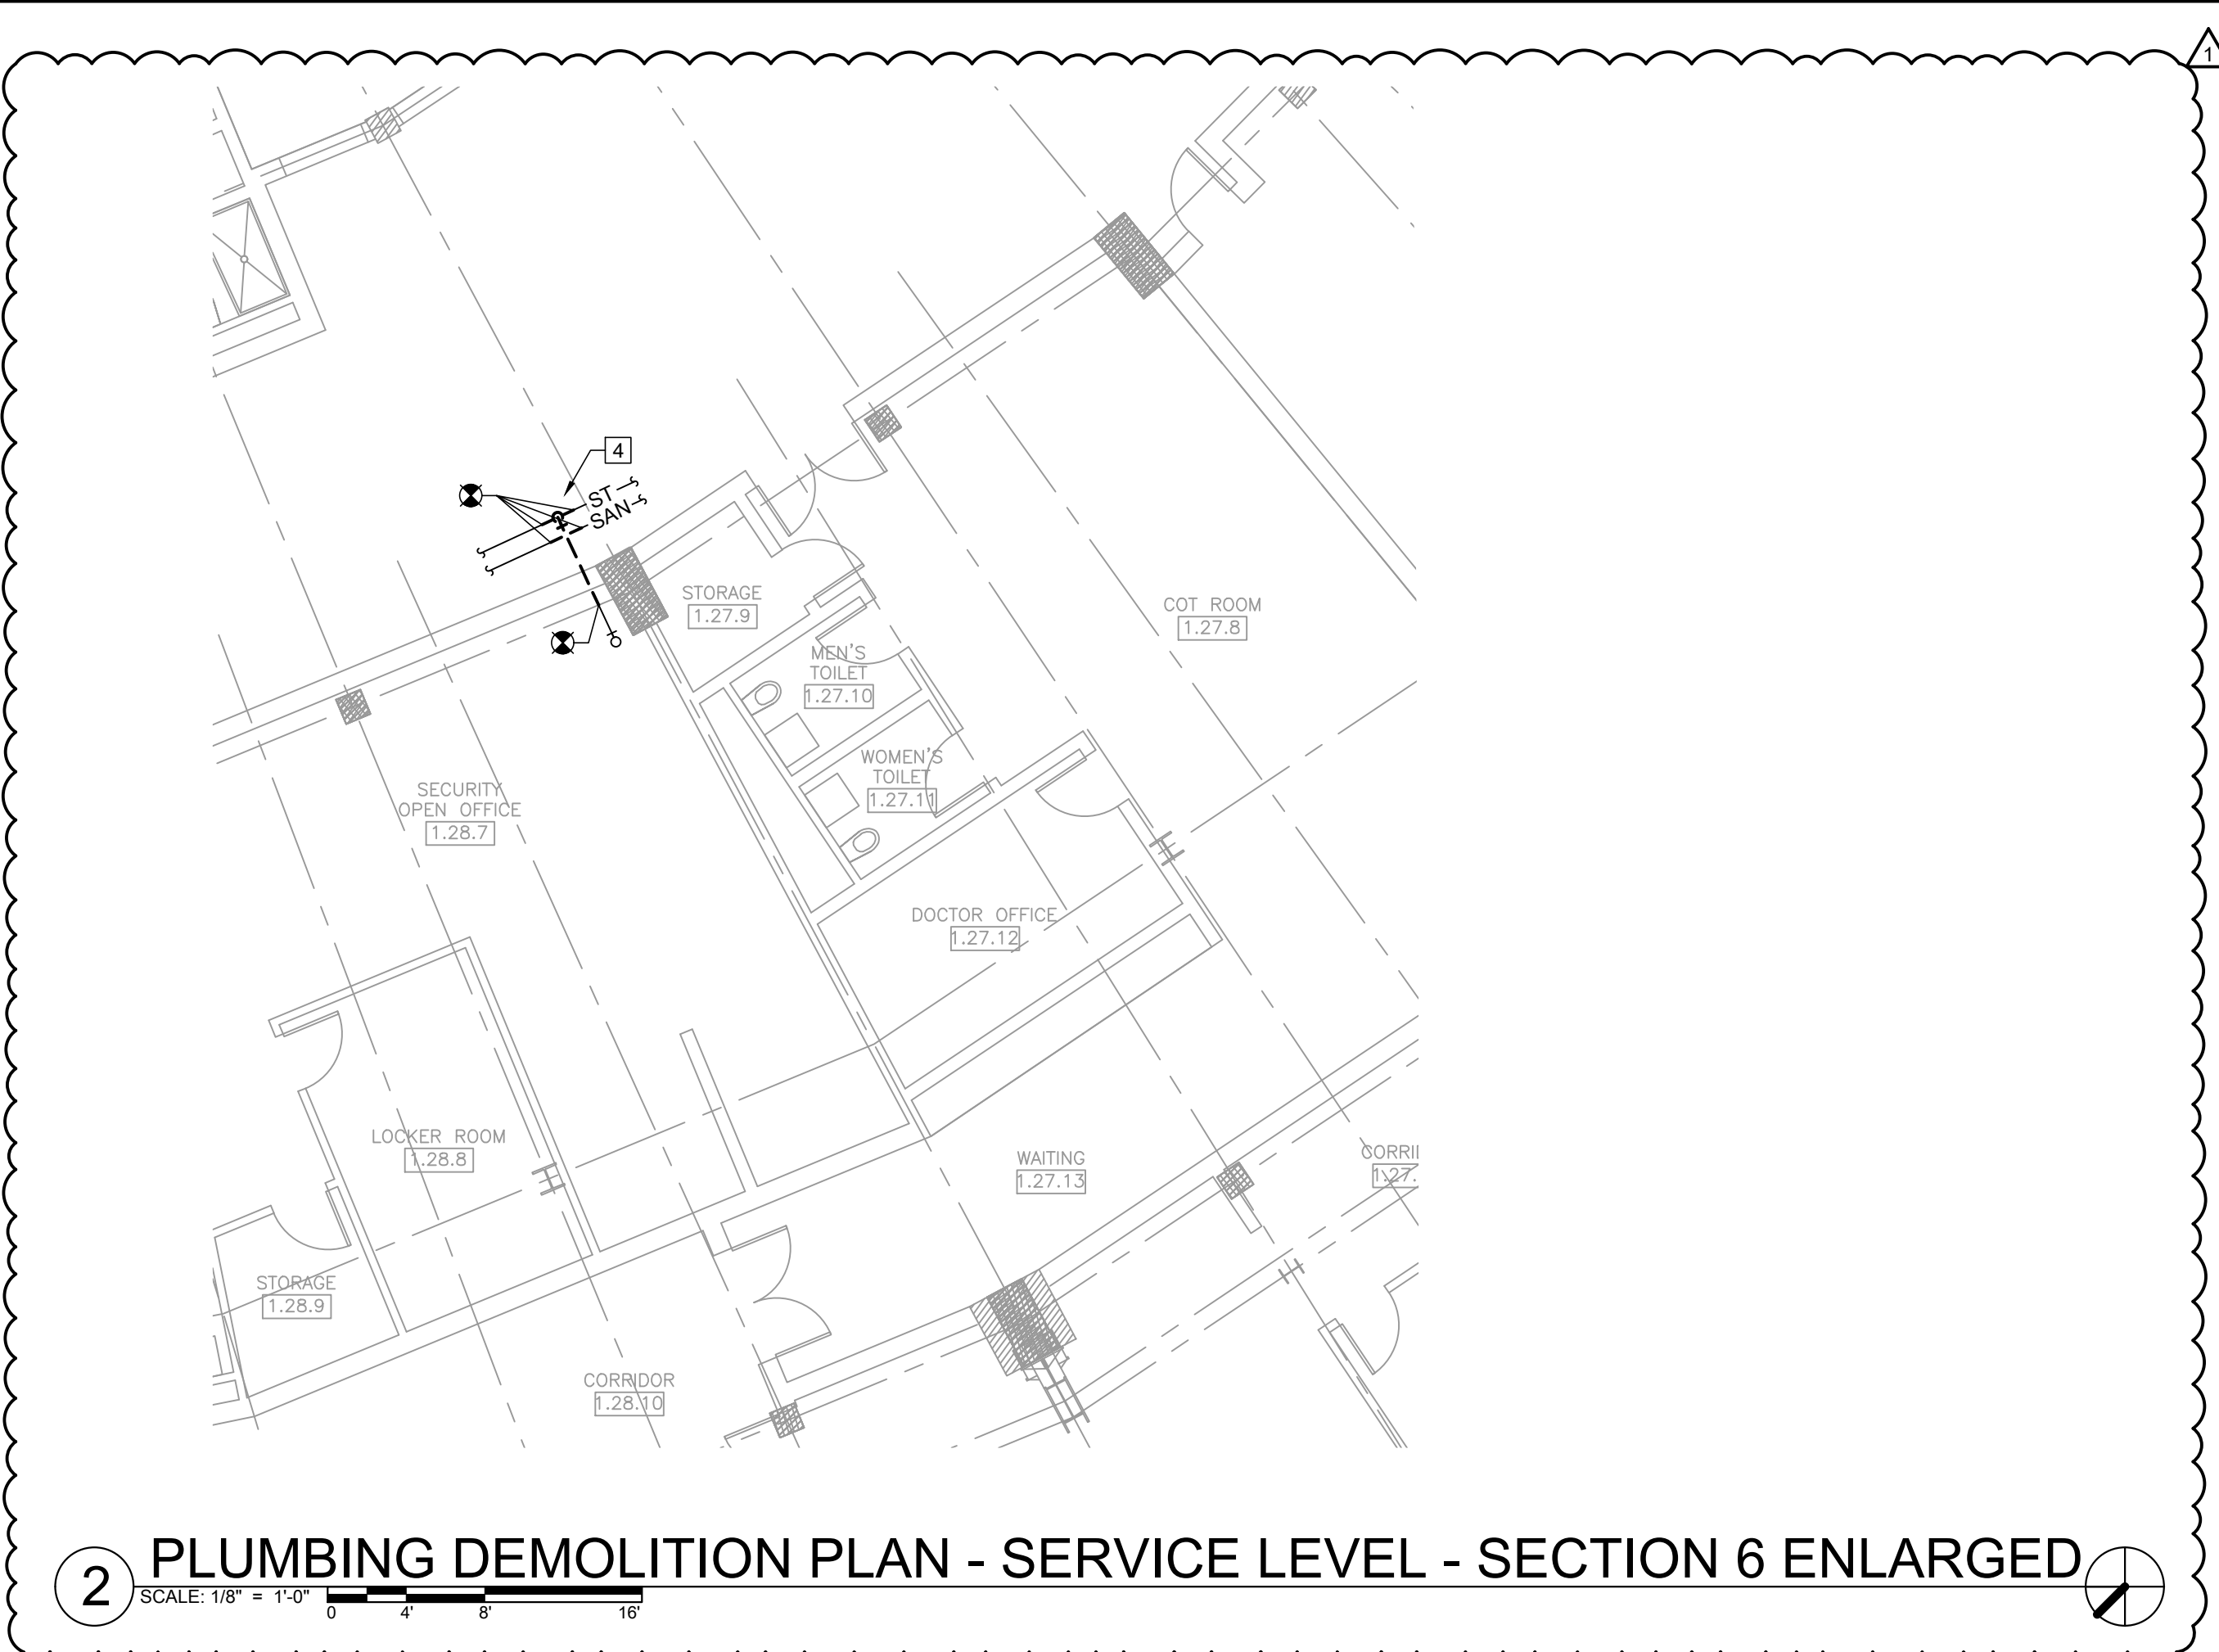

1 PLUMBING PLAN - SERVICE LEVEL - SECTION 6 ENLARGED
SCALE: 1/8" = 1'-0"

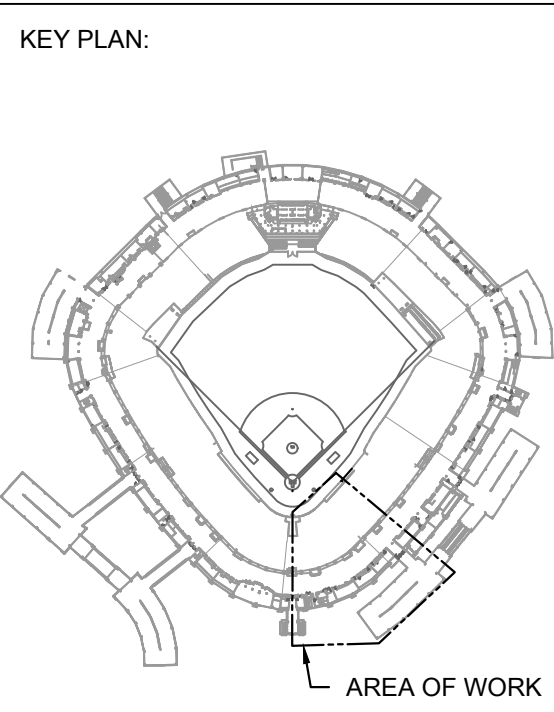

ISSUE/REVISION:		
REV.	DATE	DESCRIPTION
111425		ISSUE FOR BID
110925		ISSUE FOR ADDENDUM NO. 1

PROJECT:
GUARANTEED RATE FIELD -
WASTE/VENT PIPING FY2026


333 W 35TH STREET,
CHICAGO, ILLINOIS 60616

DRAWING TITLE:
PLUMBING PLAN - SERVICE
LEVEL - SECTION 6

DESIGNED BY:	CF
CHECKED BY:	MS
PROJECT NO:	25081
SCALE:	1/8" = 1'-0"
SHEET NO.	



- ## KEY PLUMBING SHEET NOTES
1. VERIFY LAVORATORY FAUCET IS OLDER OBSOLETE TO FAUCET MODEL. WHERE OLDER OBSOLETE TO FAUCET MODEL IS PRESENT, REPLACE THE FAUCET WITH NEW REPLACEMENT SYMBOLS FAUCET MODEL(S) (SYMBOL MODEL 586868).
 2. REUSE EXISTING NON-FAUCET COMPONENTS SUCH AS WATER SUPPLY STOP VALVES, ETC. PROVIDE ALL NEW WATER SUPPLY TUBING AND NEW PUMP/ PUMP INSULATION FOR P-RAP, DRAINAGE PIPING, AND WATER PIPING. PROVIDE NEW SYMBOL MODEL 8010T THERMOSTATIC MIXING VALVE. THE NUMBER OF FAUCETS TO VERIFY IS IDENTIFIED ON PLANS WITH CIRCLE TAG.
 3. PROVIDE NEW ARV WATTS FRP BLUELINE ROUNDOUSE OF ELECTROFUSION PIPING AND FITTINGS TO REPLACE EXISTING PORTIONS OF BEE STAND DRAINAGE PIPING. PROVIDE ADDITIONAL HANGERS AND SUPPORTS AS NECESSARY FOR THE DIFFERENT MATERIAL INSTALLED.
 4. PROVIDE NEW ARV WATTS FRP BLUELINE ROUNDOUSE OF ELECTROFUSION PIPING AND FITTINGS TO REPLACE EXISTING PORTIONS OF THE PLUMBING FAUCET PIPING. PROVIDE ADDITIONAL HANGERS AND SUPPORTS AS NECESSARY FOR THE DIFFERENT MATERIAL INSTALLED.
 5. REPLACE EXISTING SUMP PUMP, PIPING, VALVES, UNIONS, FLOATS, CONTROLS, CONTROL PANEL, ETC. REPLACE VERTICAL PIPE AND FITTINGS AND DEMOLISH AND REPLACE THE ENTIRE PUMP/ DISCHARGE PIPE (MAINTAINING EXISTING PIPE SIZING). TO ROUTE FURTHER TOWARDS INTERIOR OF BALL-POND SPACES TO REDUCE FREEZE POTENTIAL. THE PIPING SHALL BE REROUTED WITH IMPROVED PIPE SLOPE. PROVIDE NEW CORES THROUGH WALLS, NEW HANGERS, ETC. PATCH EXISTING CORES NO LONGER USED. MATCH EXISTING CONSTRUCTION. SEE PHOTOS ON SHEET.
 6. POXY LINE THE SANITARY VERTICAL PIPE, PIN-HOLE LEAK OBSERVED. SEE PHOTO ON THIS SHEET.

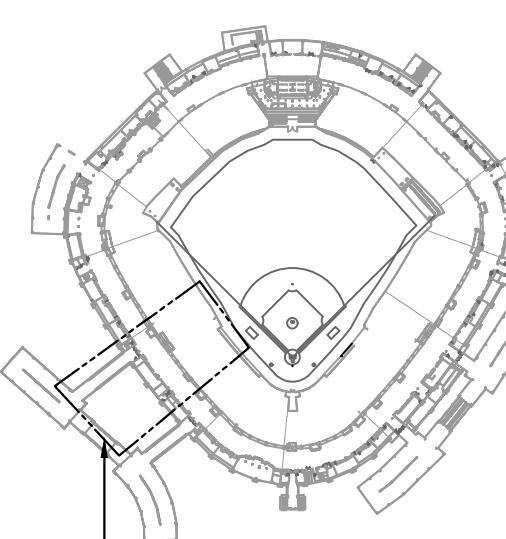[illegible]

PROJECT:
GUARANTEED RATE FIELD -
WASTE/VENT PIPING FY2026


333 W 35TH STREET,
CHICAGO, ILLINOIS 60616

PLUMBING PLAN - SERVICE
LEVEL - SECTION 8

DESIGNED BY:	CF
CHECKED BY:	MS
PROJECT NO:	25081
SCALE:	1/8" = 1'-0"
SHEET NO.	



1 PLUMBING PLAN - SERVICE LEVEL - SECTION 9 ENLARGED

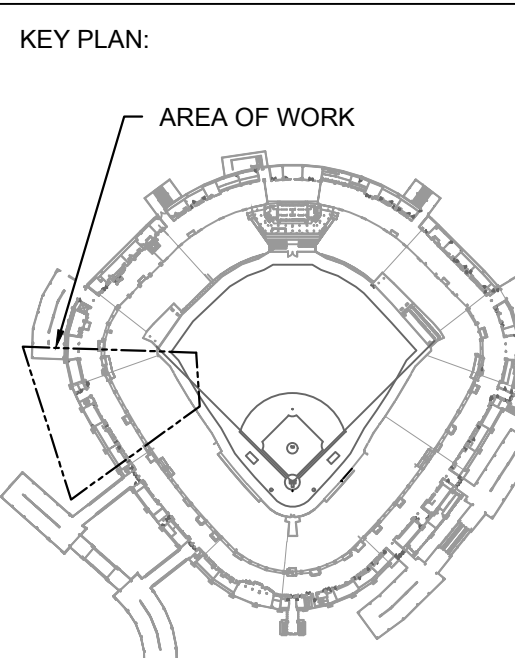

ISSUE/REVISION:		
REV.	DATE	DESCRIPTION
111425		ISSUE FOR BID
110925		ISSUE FOR ADDENDUM NO. 1


PROJECT:
GUARANTEED RATE FIELD -
WASTE/VENT PIPING FY2026

333 W 35TH STREET,
CHICAGO, ILLINOIS 60616

DRAWING TITLE:
PLUMBING PLAN - SERVICE
LEVEL - SECTION 9

DESIGNED BY: CF
CHECKED BY: MS
PROJECT NO: 25081
SCALE: 1/8" = 1'-0"

SHEET NO.
P1.S09

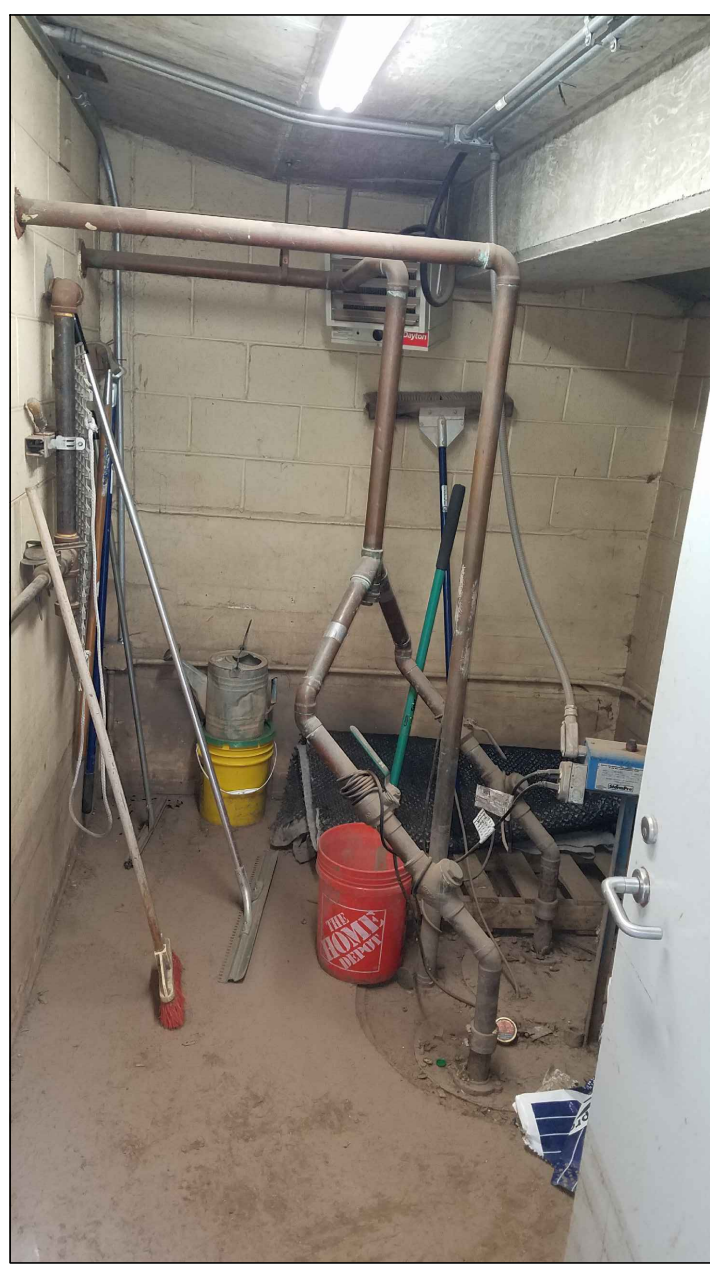


2 STORAGE 1.51.1 - SUMP PUMP
SCALE: NO SCALE



3 STORAGE 1.51.1 - SUMP PUMP
SCALE: NO SCALE




4 STORAGE 1.51.1 - SUMP PUMP
SCALE: NO SCALE

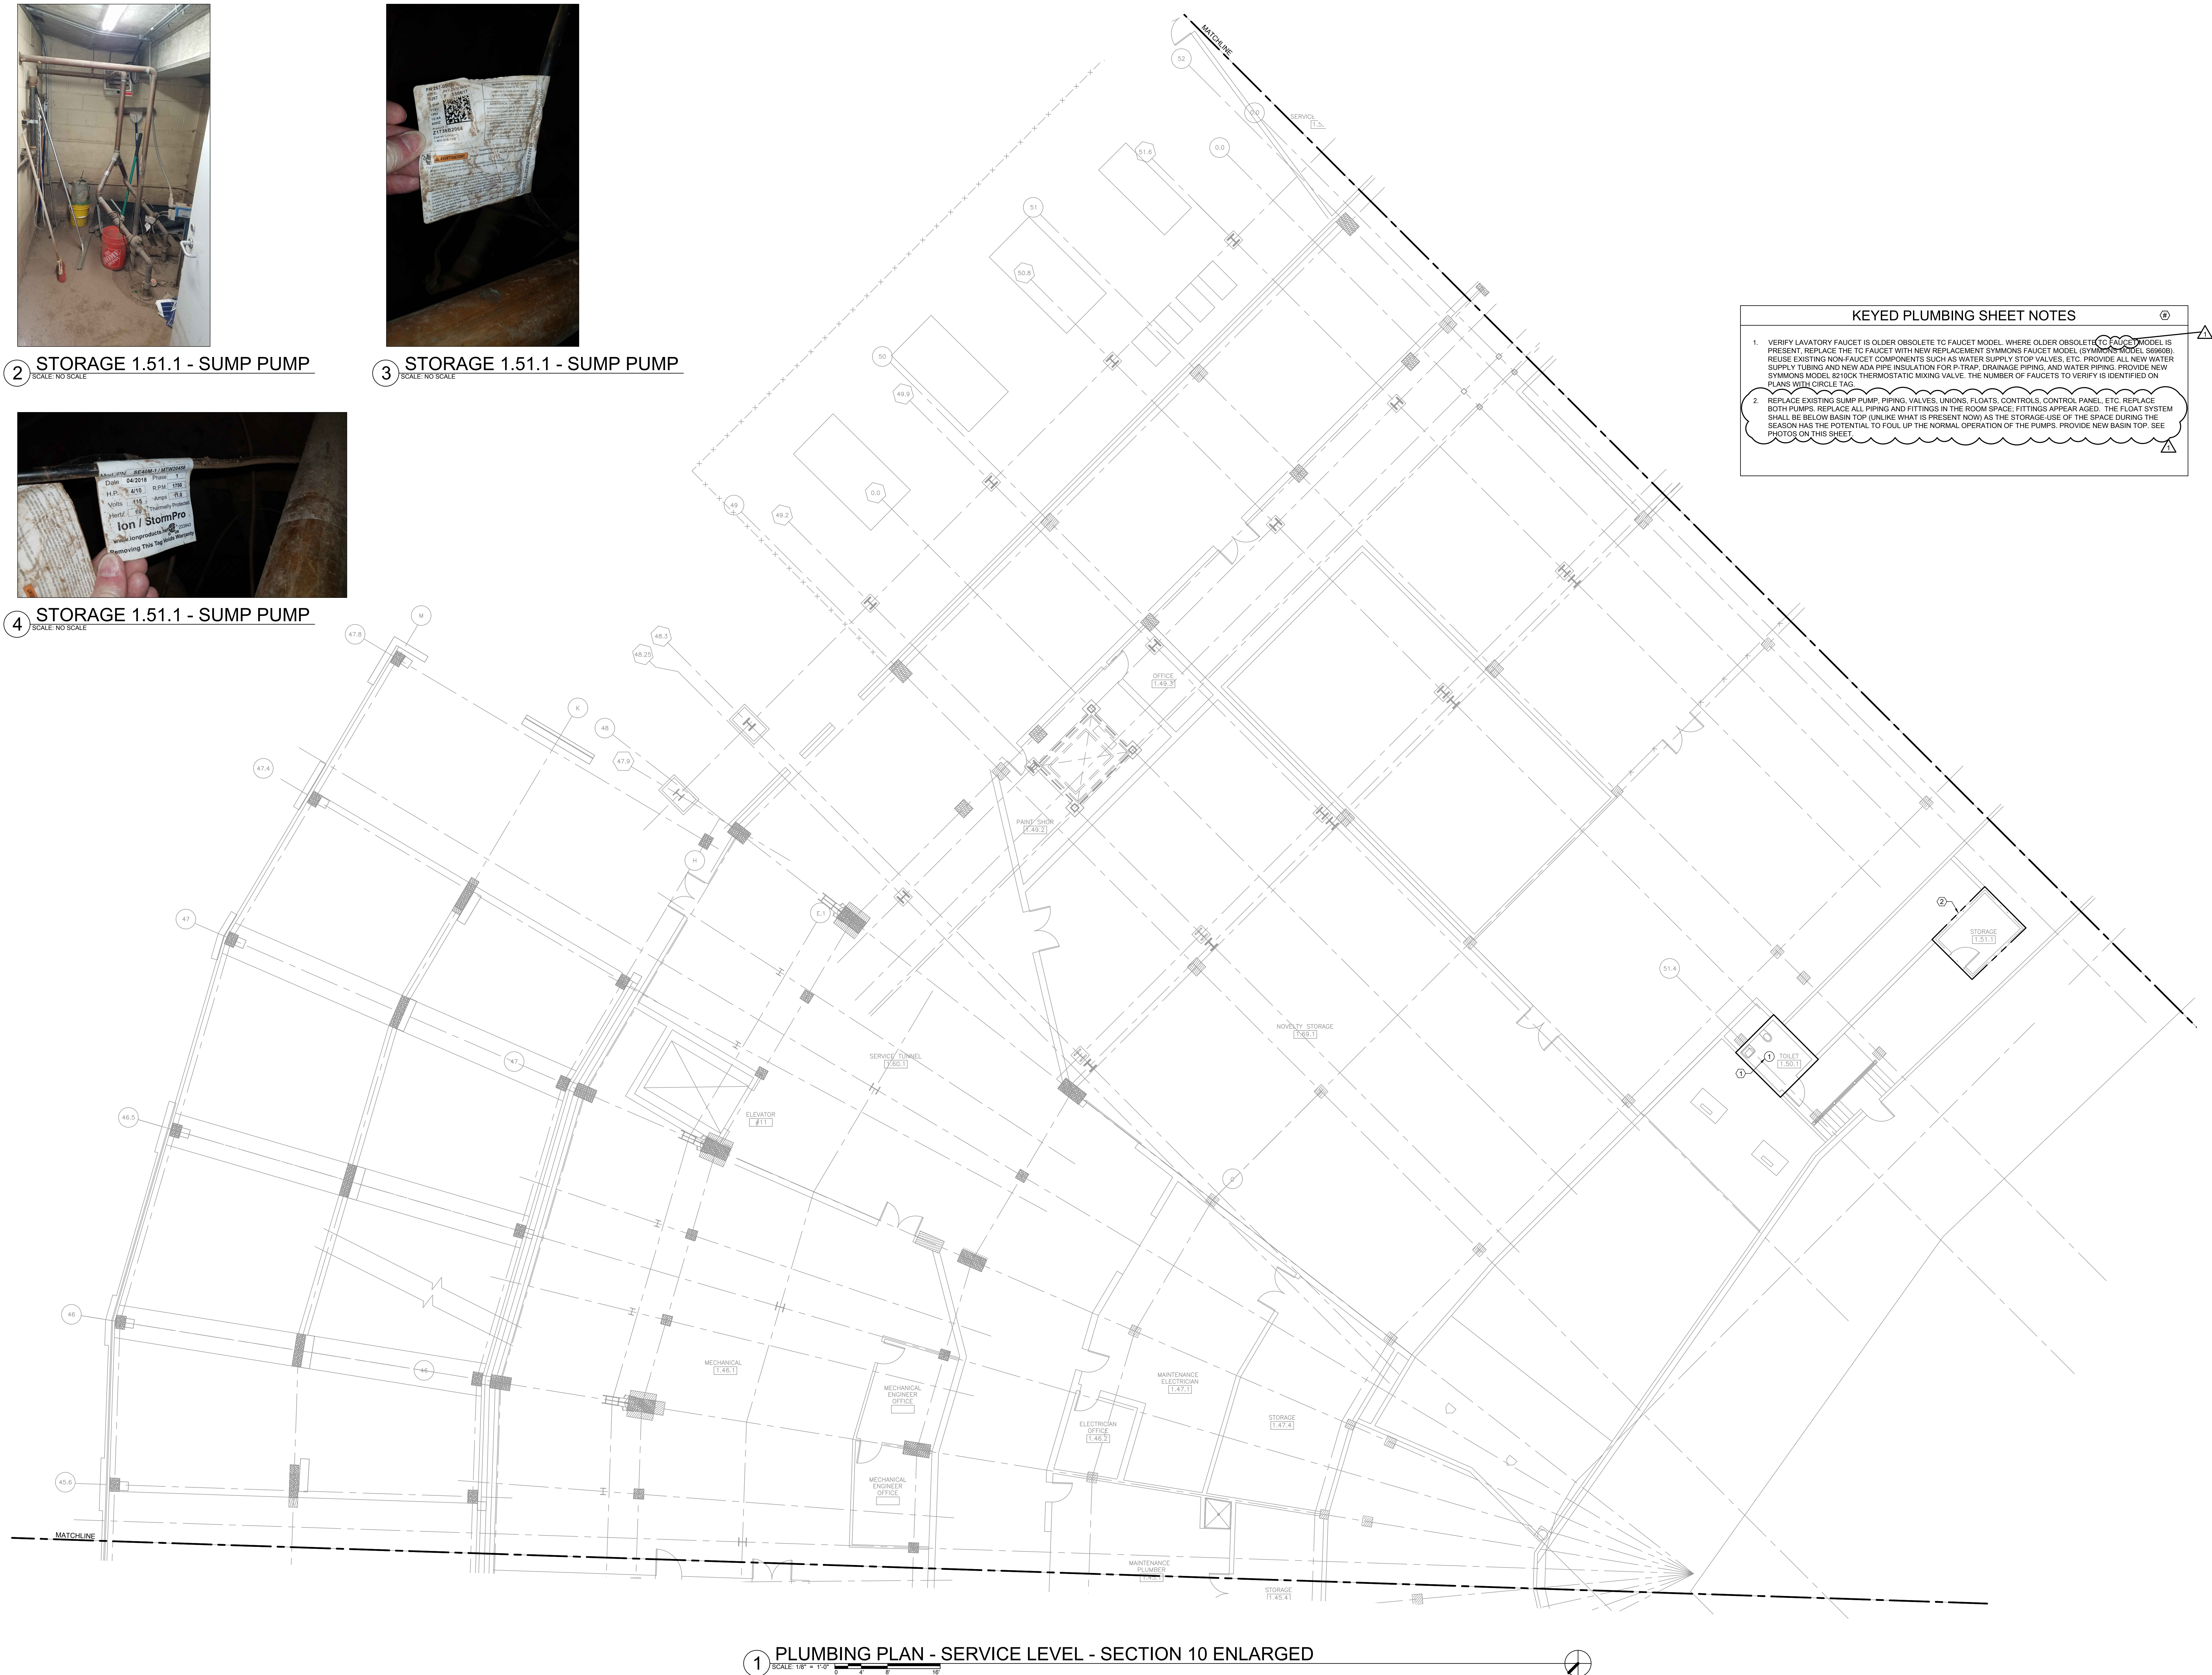

KEYED PLUMBING SHEET NOTES

1. VERIFY LAVATORY FAUCET IS OLDER OBSOLETE TC FAUCET MODEL. WHERE OLDER OBSOLETE TC FAUCET MODEL IS PRESENT, REPLACE THE TC FAUCET WITH NEW REPLACEMENT SYMMONS FAUCET MODEL (SYMMONS MODEL 999999). REUSE EXISTING NON-FAUCET COMPONENTS SUCH AS WATER SUPPLY STOP VALVES, ETC. PROVIDE ALL NEW WATER SUPPLY TUBING AND NEW ADA PIPE INSULATION FOR P-TRAP, DRAINAGE PIPING, AND WATER PIPING. PROVIDE NEW SYMMONS MODEL 52000 THERMOSTATIC MIXING VALVE. THE NUMBER OF FAUCETS TO VERIFY IS IDENTIFIED ON PLANS WITH CIRCLE TAG.

2. REPLACE EXISTING SUMP PUMP, PIPING, VALVES, UNIONS, FLOATS, CONTROLS, CONTROL PANEL, ETC. REPLACE BOTH PUMPS. REPLACE ALL PIPING AND FITTINGS IN THE ROOM SPACE. FITTINGS APPEAR AGED. THE FLOAT SYSTEM SHALL BE BELOW BASIN TOP (UNLIKE WHAT IS PRESENT NOW) AS THE STORAGE-USE OF THE SPACE DURING THE SEASON HAS THE POTENTIAL TO FOUL UP THE NORMAL OPERATION OF THE PUMPS. PROVIDE NEW BASIN TOP. SEE PHOTOS ON THIS SHEET.

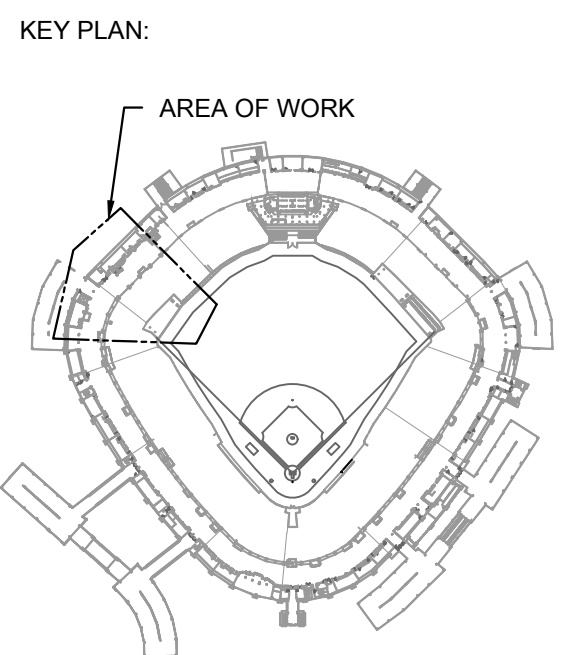

ISSUE/REVISION:		
REV.	DATE	DESCRIPTION
111425		ISSUE FOR BID
110925		ISSUE FOR ADDENDUM NO. 1

PROJECT:
GUARANTEED RATE FIELD -
WASTE/VENT PIPING FY2026

333 W 35TH STREET,
CHICAGO, ILLINOIS 60616

DRAWING TITLE:
PLUMBING PLAN - SERVICE
LEVEL - SECTION 10


DESIGNED BY: CF
CHECKED BY: MS
PROJECT NO: 25081
SCALE: 1/8" = 1'-0"

SHEET NO.



KEYED PLUMBING SHEET NOTES

1. VERIFY LAVATORY FAUCET IS OLDER OBSOLETE TC FAUCET MODEL. WHERE OLDER OBSOLETE TC FAUCET MODEL IS PRESENT, REPLACE THE TC FAUCET WITH NEW REPLACEMENT SYMMONS FAUCET MODEL (SYMMONS MODEL 969698). REUSE EXISTING NON-FAUCET COMPONENTS SUCH AS WATER SUPPLY STOP VALVES, ETC. PROVIDE ALL NEW WATER SUPPLY TUBING AND NEW ADA PIPE INSULATION FOR P-TRAP. DRAINAGE PIPING, AND WATER PIPING. PROVIDE NEW SYMMONS MODEL 821004 THERMOSTATIC MIXING VALVE. THE NUMBER OF FAUCETS TO VERIFY IS IDENTIFIED ON PLANS WITH CIRCLE TAG.

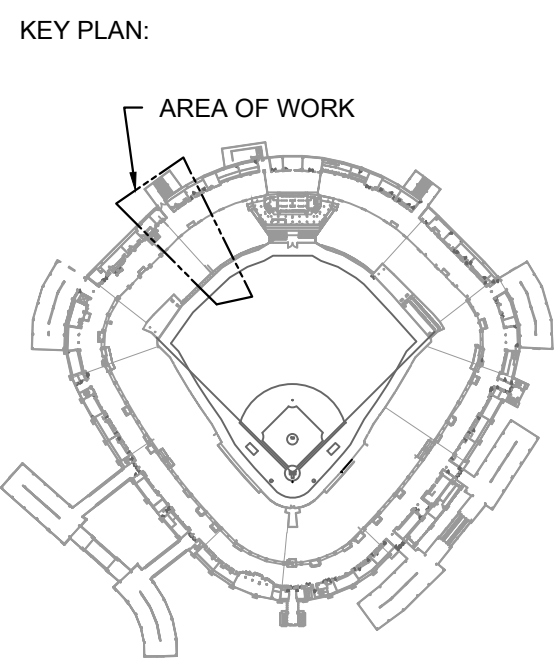

ISSUE/REVISION:		
REV.	DATE	DESCRIPTION
1	11/14/25	ISSUE FOR BID
2	11/09/25	ISSUE FOR ADDENDUM NO. 1


PROJECT:
GUARANTEED RATE FIELD -
WASTE/VENT PIPING FY2026

333 W 35TH STREET,
CHICAGO, ILLINOIS 60616

DRAWING TITLE:
PLUMBING PLAN - SERVICE
LEVEL - SECTION 11

DESIGNED BY:	CF
CHECKED BY:	MS
PROJECT NO:	25081
SCALE:	1/8" = 1'-0"

SHEET NO.
P1.S11

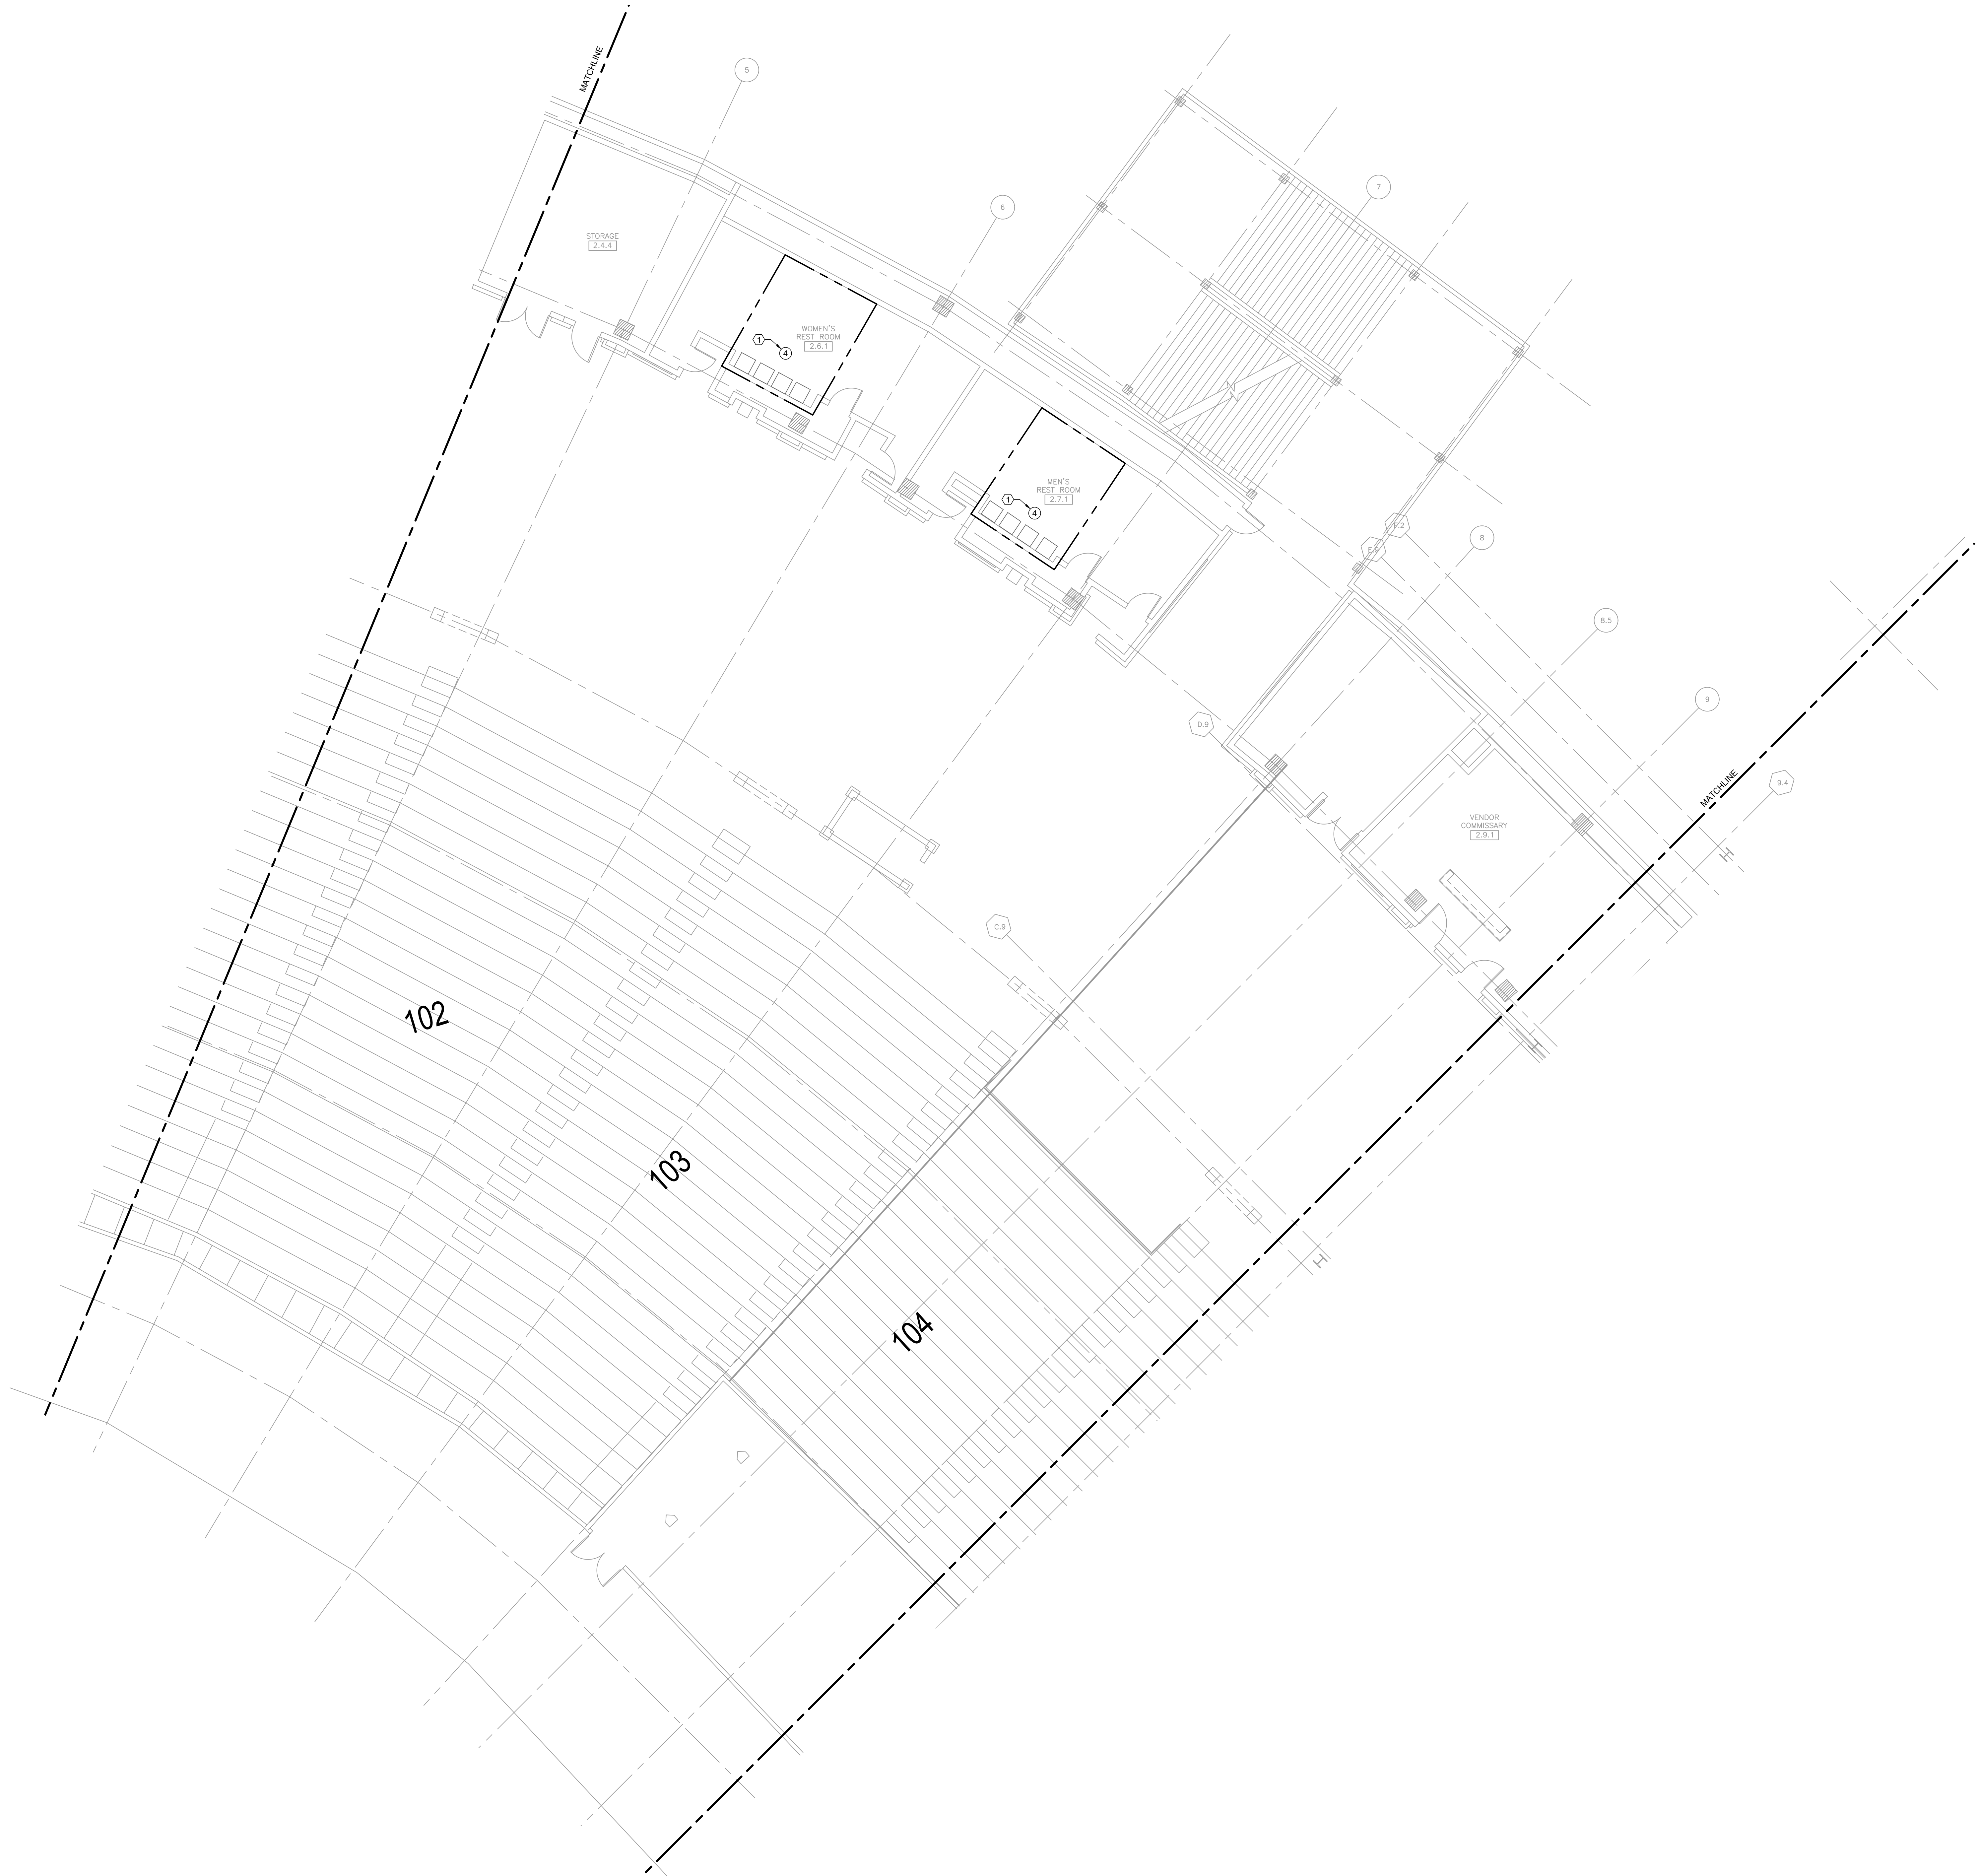


KEYED PLUMBING SHEET NOTES


1. VERIFY LAVATORY FAUCET IS OLDER OBSOLETE TC FAUCET MODEL. WHERE OLDER OBSOLETE TC FAUCET MODEL IS PRESENT, REPLACE THE TC FAUCET WITH NEW REPLACEMENT SYMMONS FAUCET MODEL (SYMMONS MODEL 66800). REUSE EXISTING NON-FAUCET COMPONENTS SUCH AS WATER SUPPLY STOP VALVES, ETC. PROVIDE ALL NEW WATER SUPPLY TUBING AND NEW ADA PIPE INSULATION FOR R-TRAP, DRAINAGE PIPING, AND WATER PIPING. PROVIDE NEW SYMMONS MODEL 6210CK THERMOSTATIC MIXING VALVE. THE NUMBER OF FAUCETS TO VERIFY IS IDENTIFIED ON PLANS WITH CIRCLE TAG.

1 PLUMBING PLAN - 100 LEVEL - SECTION 2 ENLARGED

 SCALE: 1/8" = 1'-0"



KEY PLAN:

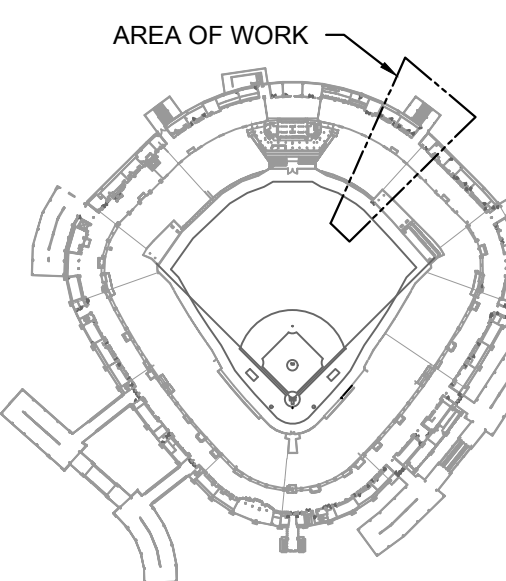

ISSUE/REVISION:

REV.	DATE	DESCRIPTION
111425		ISSUE FOR BID
110925		ISSUE FOR ADDENDUM NO. 1

PROJECT:
GUARANTEED RATE FIELD -
WASTE/VENT PIPING FY2026


333 W 35TH STREET,
CHICAGO, ILLINOIS 60616

DRAWING TITLE:
PLUMBING PLAN - LEVEL 100 -
SECTION 2

DESIGNED BY: CF
CHECKED BY: MS
PROJECT NO: 25081
SCALE: 1/8" = 1'-0"

SHEET NO.

P1.102

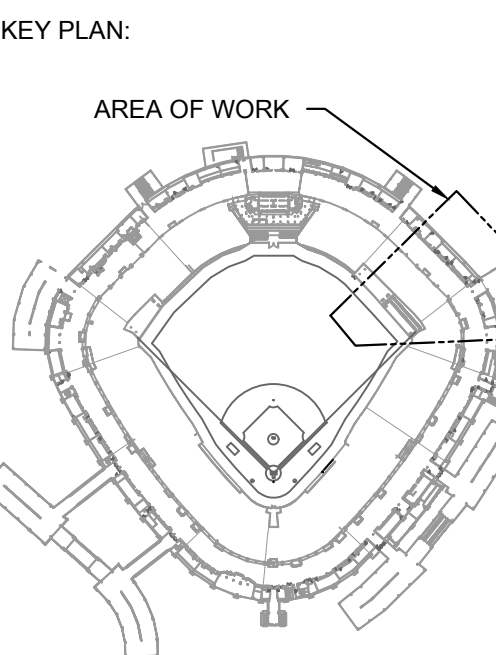

ISSUE/REVISION:		
REV.	DATE	DESCRIPTION
1	11/14/25	ISSUE FOR BID
2	11/09/25	ISSUE FOR ADDENDUM NO. 1

PROJECT:
GUARANTEED RATE FIELD -
WASTE/VENT PIPING FY2026

333 W 35TH STREET,
CHICAGO, ILLINOIS 60616

DRAWING TITLE:
PLUMBING PLAN - LEVEL 100 -
SECTION 3


DESIGNED BY: CF
CHECKED BY: MS
PROJECT NO: 25081
SCALE: 1/8" = 1'-0"

SHEET NO.

P1.103

KEYED PLUMBING SHEET NOTES

1. VERIFY LAVATORY FAUCET IS OLDER OBSOLETE TC FAUCET MODEL. WHERE OLDER OBSOLETE TC FAUCET MODEL IS PRESENT, REPLACE THE TC FAUCET WITH NEW REPLACEMENT SYMMONS FAUCET MODEL (SYMMONS MODEL 56A006). REUSE EXISTING NON-FAUCET COMPONENTS SUCH AS WATER SUPPLY STOP VALVES, ETC. PROVIDE ALL NEW WATER SUPPLY TUBING AND NEW ADA PIPE INSULATION FOR P-TRAP, DRAINAGE PIPING, AND WATER PIPING. PROVIDE NEW SYMMONS MODEL 62150CK THERMOSTATIC MIXING VALVE. THE NUMBER OF FAUCETS TO VERIFY IS IDENTIFIED ON PLANS WITH CIRCLE TAG.

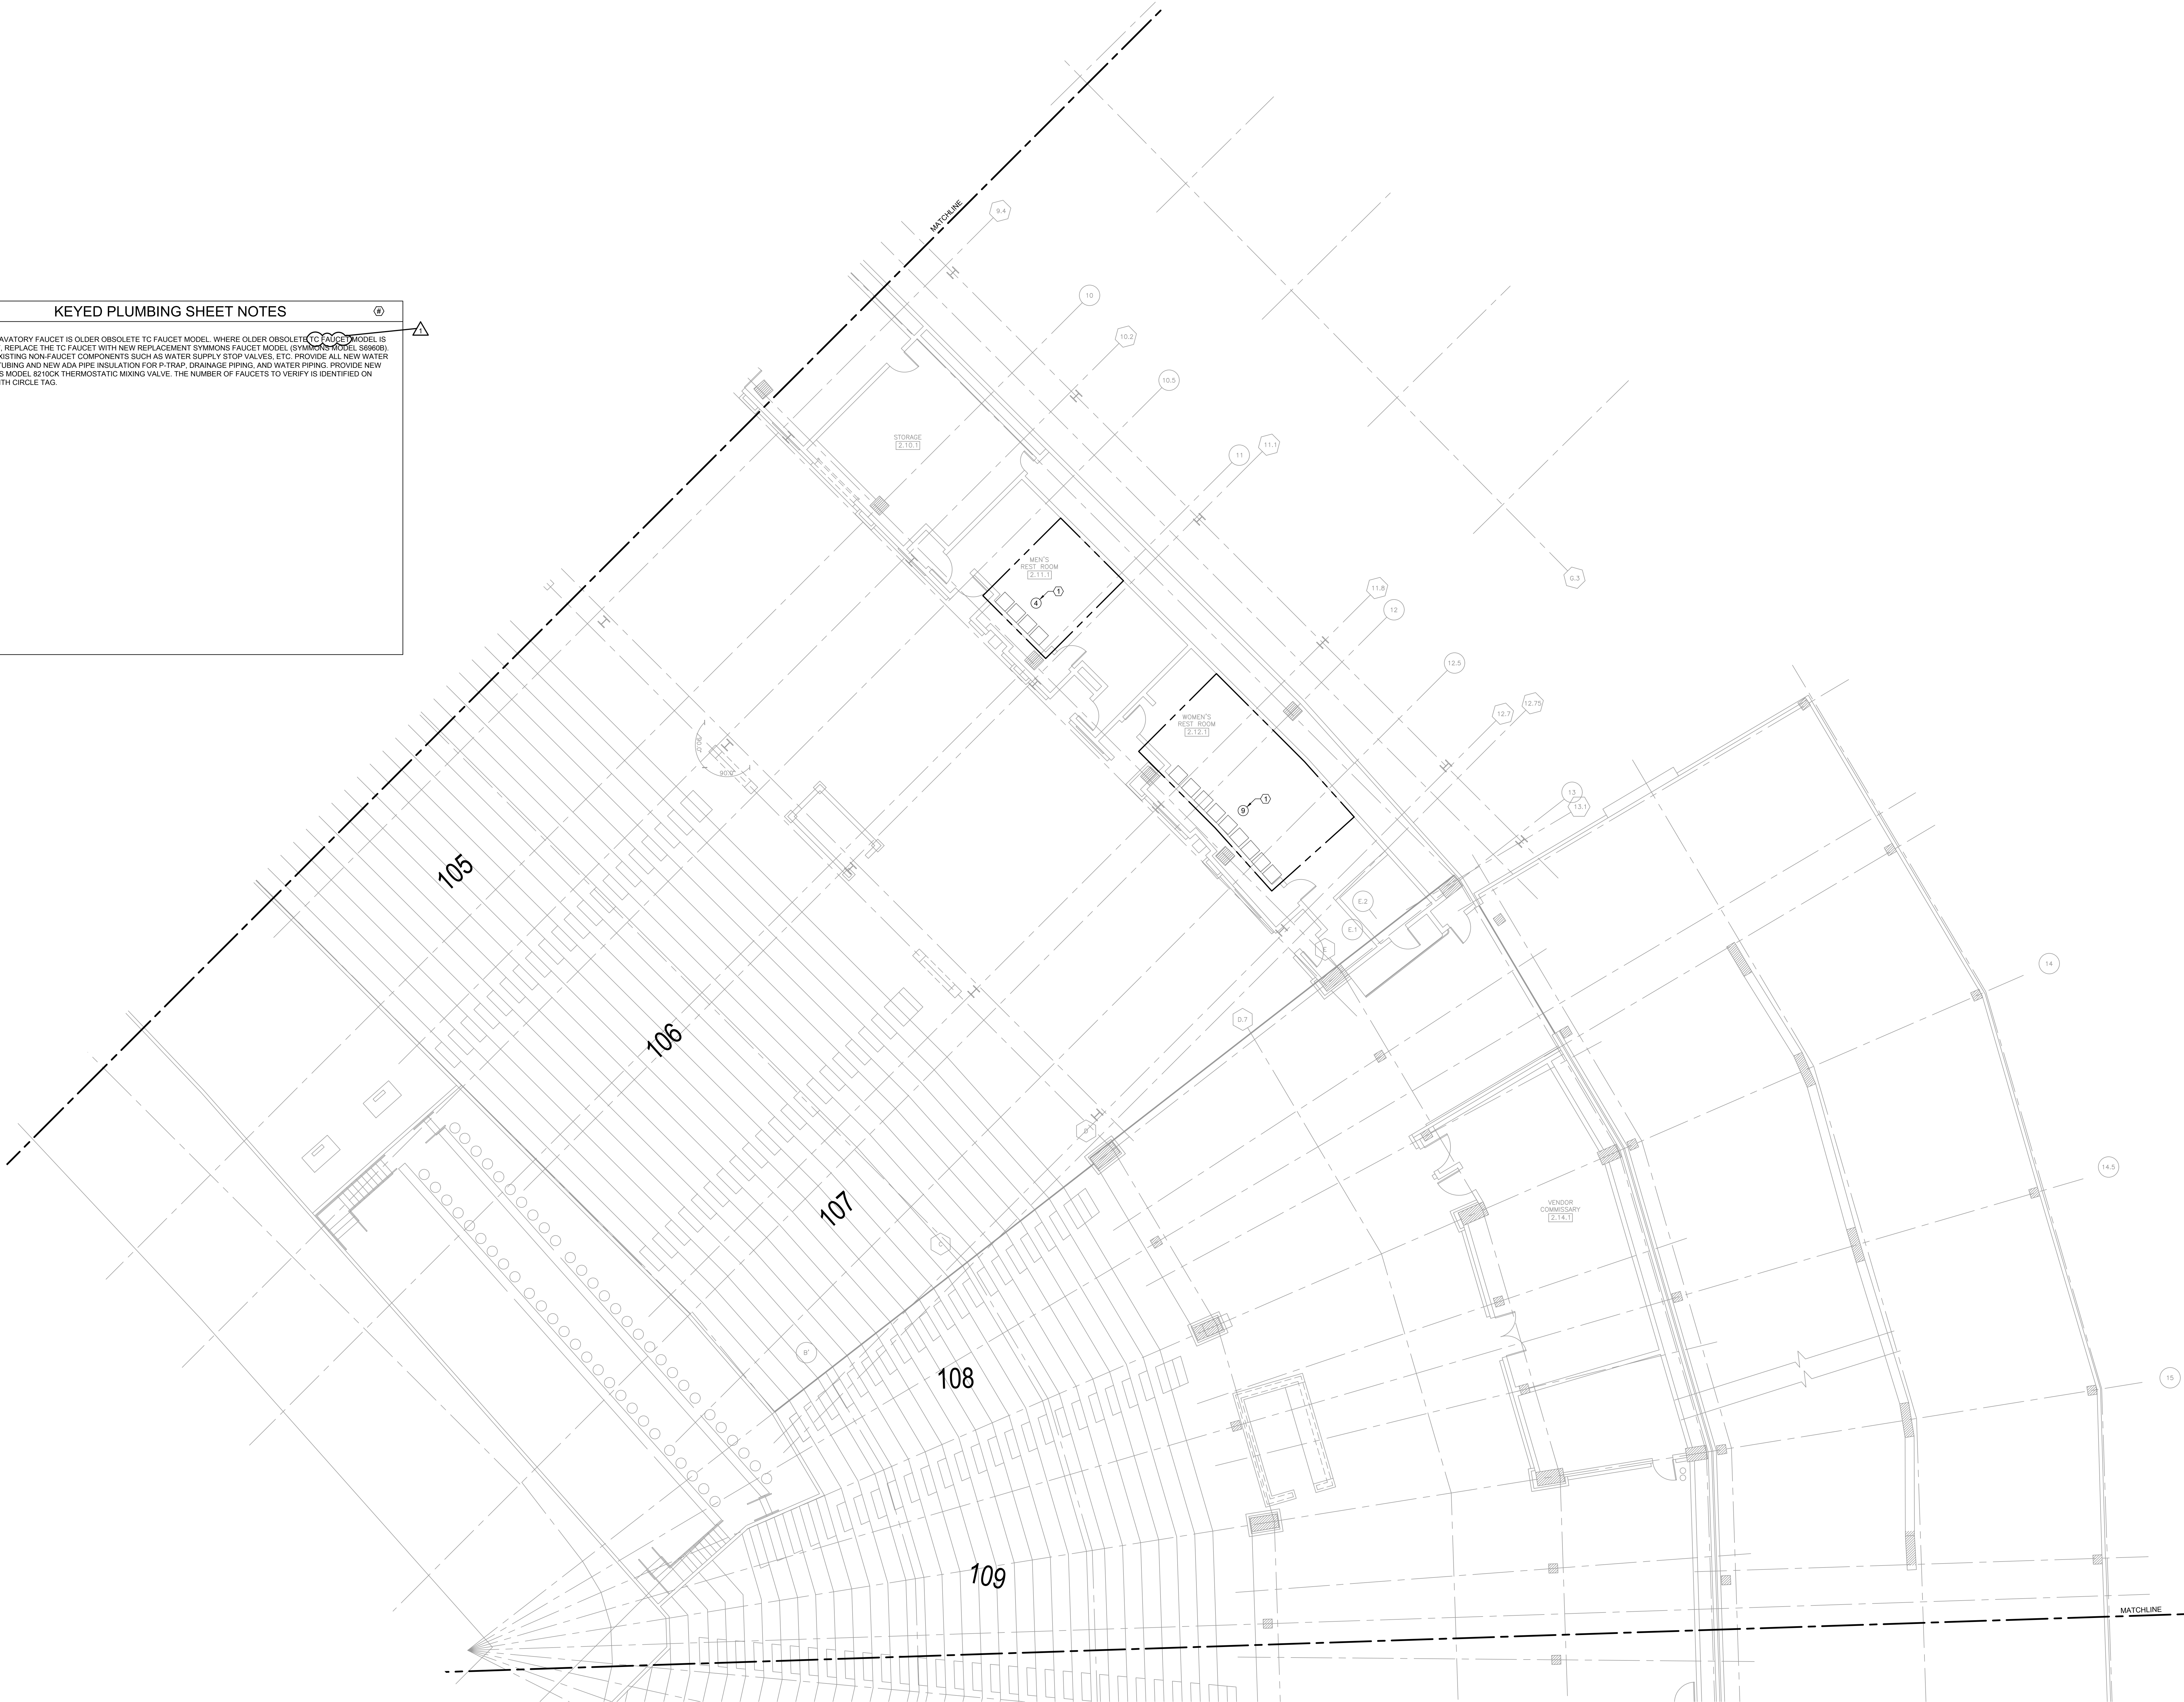

1 PLUMBING PLAN - 100 LEVEL - SECTION 3 ENLARGED

SCALE: 1/8" = 1'-0"




KEYED PLUMBING SHEET NOTES

1. VERIFY LAVATORY FAUCET IS OLDER OBSOLETE TC FAUCET MODEL. WHERE OLDER OBSOLETE TC FAUCET MODEL IS PRESENT, REPLACE THE TC FAUCET WITH NEW REPLACEMENT SYMMONS FAUCET MODEL (SYMMONS MODEL S6900B). REUSE EXISTING NON-FAUCET COMPONENTS SUCH AS WATER SUPPLY STOP VALVES, ETC. PROVIDE ALL NEW WATER SUPPLY TUBING AND NEW ADA PIPE INSULATION FOR P-TRAP, DRAINAGE PIPING, AND WATER PIPING. PROVIDE NEW SYMMONS MODEL 8210CK THERMOSTATIC MIXING VALVE. THE NUMBER OF FAUCETS TO VERIFY IS IDENTIFIED ON PLANS WITH CIRCLE TAG.

1 PLUMBING PLAN - 100 LEVEL - SECTION 4 ENLARGED

KEY PLAN:

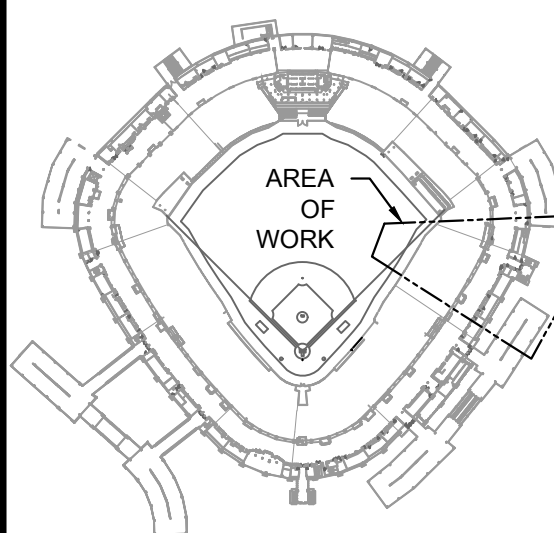

ISSUE/REVISION:

REV.	DATE	DESCRIPTION
111425		ISSUE FOR BID
110925		ISSUE FOR ADDENDUM NO. 1

PROJECT:

GUARANTEED RATE FIELD -
WASTE/VENT PIPING FY2026

333 W 35TH STREET,
CHICAGO, ILLINOIS 60616

DRAWING TITLE:

PLUMBING PLAN - LEVEL 100 -
SECTION 4

DESIGNED BY: CF
CHECKED BY: MS
PROJECT NO: 25081
SCALE: 1/8" = 1'-0"

SHEET NO.


P1.104

KEYED PLUMBING SHEET NOTES

1. VERIFY LAVATORY FAUCET IS OLDER OBSOLETE TC FAUCET MODEL. WHERE OLDER OBSOLETE TC FAUCET MODEL IS PRESENT, REPLACE THE TC FAUCET WITH NEW REPLACEMENT SYMMONS FAUCET MODEL (SYMMONS MODEL 599080). REUSE EXISTING NON-FAUCET COMPONENTS SUCH AS WATER SUPPLY STOP VALVES, ETC. PROVIDE ALL NEW WATER SUPPLY TUBING AND NEW ADA PIPE INSULATION FOR P-TRAP, DRAINAGE PIPING, AND WATER PIPING. PROVIDE NEW SYMMONS MODEL 62100K THERMOSTATIC MIXING VALVE. THE NUMBER OF FAUCETS TO VERIFY IS IDENTIFIED ON PLANS WITH CIRCLE TAG.

2. PROVIDE NEW DECK DRAIN TO REPLACE EXISTING FAILING DECK DRAIN. PROVIDE SMITH MODEL 1410 TO REPLACE EXISTING UNIT. PROVIDE NEW ARW WATTS FRPP BLUELINE RIONFUSE OF (ELECTROFUSION) PIPING AND FITTINGS TO REPLACE EXISTING PORTIONS OF BEER STAND DRAINAGE PIPING UP TO NEW DECK DRAIN. EPOXY LINE BEER STAND DECK DRAIN BODY DRAIN INLET AND DOWNSTREAM PIPING INTO/THTHROUGH THE ARW PIPING.


3. EXISTING TO REMAIN LOOP VENT PIPING IN EXISTING TO REMAIN CMU WALL AT BEER STAND.

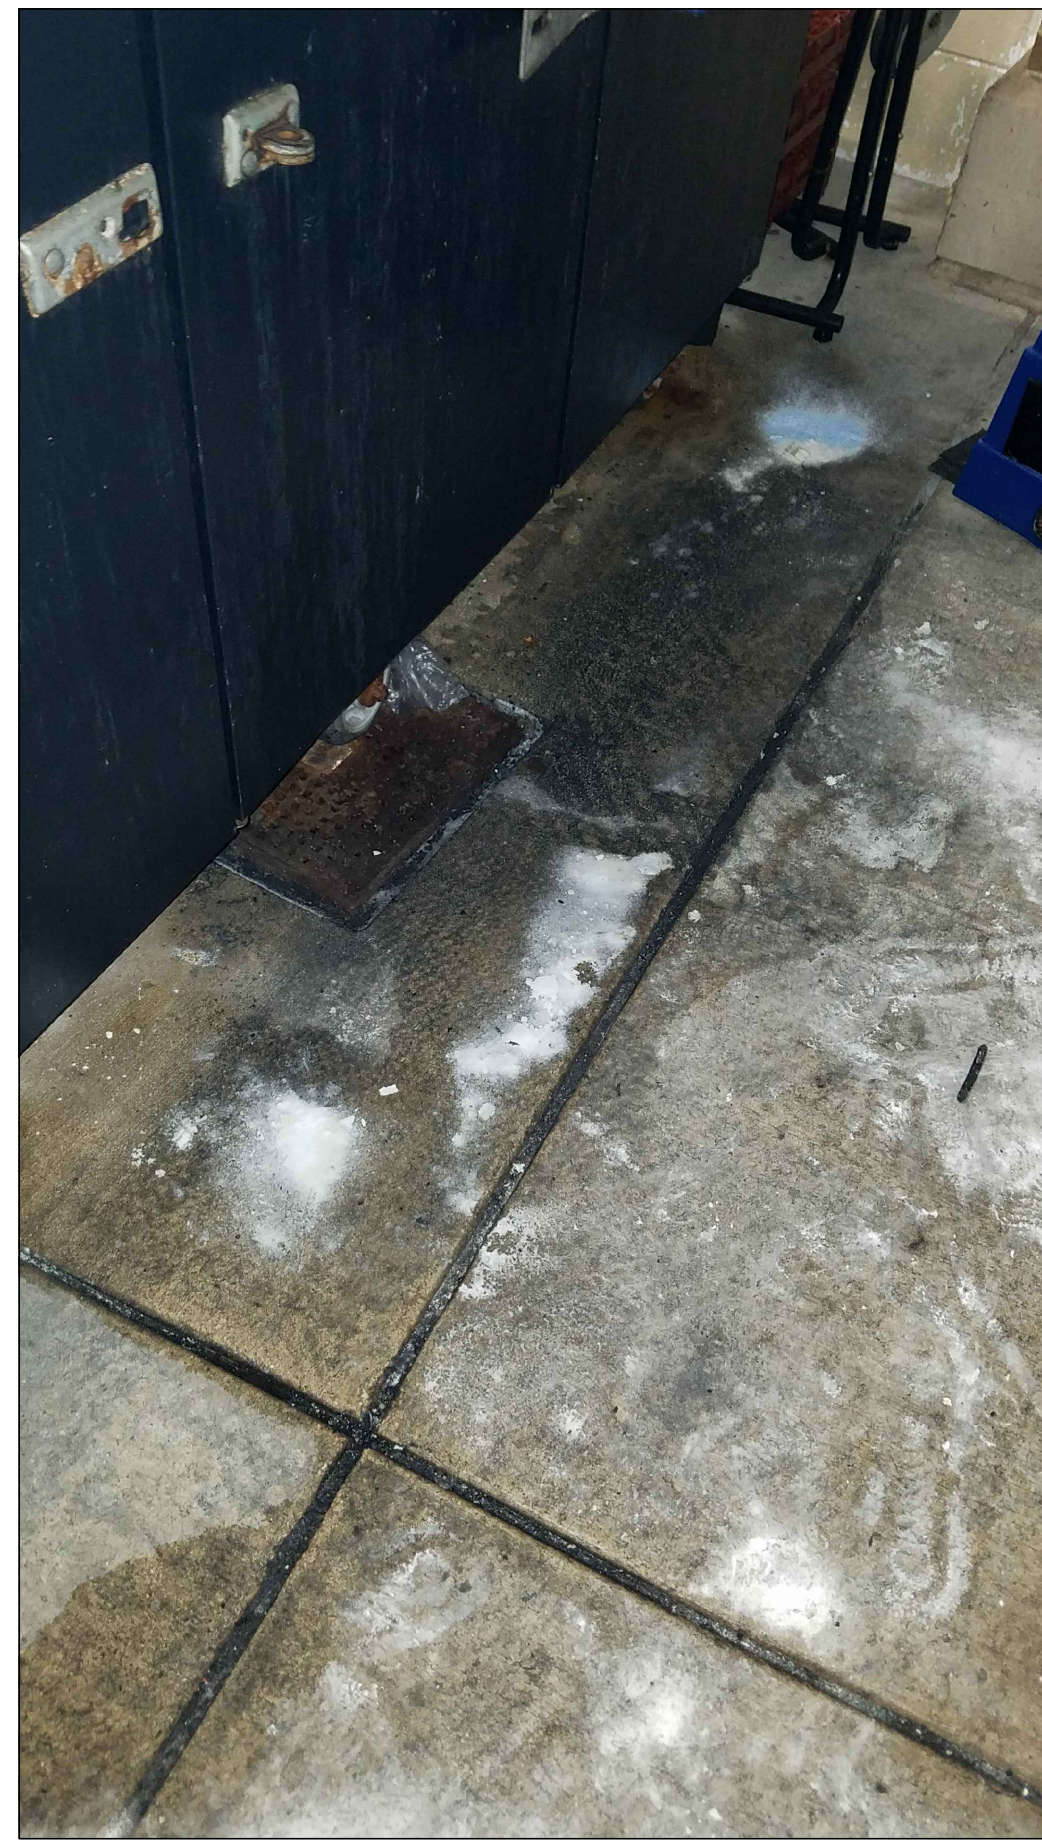

2 BEER STAND - FLOOR DRAIN
SCALE: NO SCALE

1 PLUMBING PLAN - 100 LEVEL - SECTION 5 ENLARGED
SCALE: 1/8" = 1'-0"

KEY PLAN:

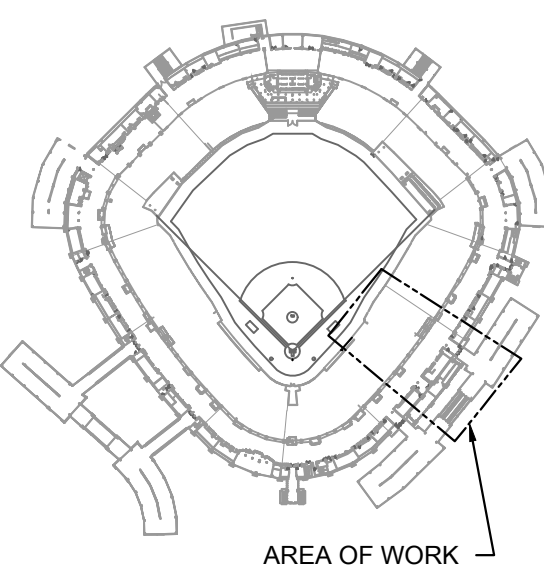

ISSUE/REVISION:

REV.	DATE	DESCRIPTION
111425		ISSUE FOR BID
110925		ISSUE FOR ADDENDUM NO. 1

PROJECT:

GUARANTEED RATE FIELD -
WASTE/VENT PIPING FY2026

333 W 35TH STREET,
CHICAGO, ILLINOIS 60616

DRAWING TITLE:

PLUMBING PLAN - LEVEL 100 -
SECTION 5


DESIGNED BY:	CF
CHECKED BY:	MS
PROJECT NO:	25081
SCALE:	1/8" = 1'-0"
SHEET NO.	



- KEYED PLUMBING SHEET NOTES**
1. VERIFY LAVATORY FAUCET IS OLDER OBSOLETE TO FAUCET MODEL. WHERE OLDER OBSOLETE TO FAUCET MODEL IS PRESENT, REPLACE THE TO FAUCET WITH NEW REPLACEMENT SYMMONS FAUCET MODEL (SYMMONS MODEL 599R08). REUSE EXISTING NON-FAUCET COMPONENTS SUCH AS WATER SUPPLY STOP VALVES, ETC. PROVIDE ALL NEW WATER SUPPLY TUBING AND NEW ADA PIPE INSULATION FOR P-TRAP, DRAINAGE PIPING, AND WATER PIPING. PROVIDE NEW SYMMONS MODEL 821000 THERMOSTATIC MIXING VALVE. THE NUMBER OF FAUCETS TO VERIFY IS IDENTIFIED ON PLANS WITH CIRCLE TAG.
 2. PROVIDE NEW DECK DRAIN TO REPLACE EXISTING FAILING DECK DRAIN. PROVIDE SMITH MODEL 1410 TO REPLACE EXISTING UNIT. PROVIDE NEW ARW WATTS FRPP BLUELINE RIONFUSE CF (ELECTROFUSION) PIPING AND FITTINGS TO REPLACE EXISTING PORTIONS OF BEER STAND DRAINAGE PIPING UP TO NEW DECK DRAIN. EPOXY LINE BEER STAND DECK DRAIN BODY DRAIN INLET AND DOWNSTREAM PIPING INTO THROUGH THE ARW PIPING.
 3. EXISTING TO REMAIN LOOP VENT PIPING IN EXISTING TO REMAIN CMU WALL AT BEER STAND.

2 BEER STAND - FLOOR DRAIN
SCALE: NO SCALE

KEY PLAN:

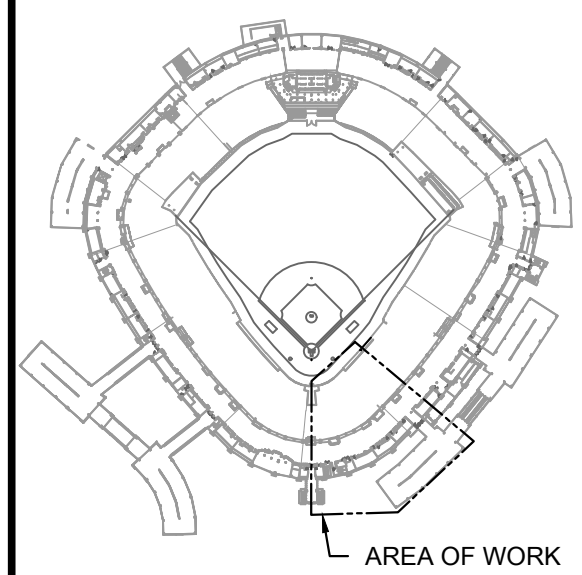

AREA OF WORK

ISSUE/REVISION:

REV.	DATE	DESCRIPTION
111425		ISSUE FOR BID
110925		ISSUE FOR ADDENDUM NO. 1

PROJECT:
GUARANTEED RATE FIELD -
WASTE/VENT PIPING FY2026

333 W 35TH STREET,
CHICAGO, ILLINOIS 60616

DRAWING TITLE:
PLUMBING PLAN - LEVEL 100 -
SECTION 6

DESIGNED BY: CF
CHECKED BY: MS
PROJECT NO: 25081
SCALE: 1/8" = 1'-0"

SHEET NO.

P1.106



- KEYED PLUMBING SHEET NOTES**
1. VERIFY LAVATORY FAUCET IS OLDER OBSOLETE TO FAUCET MODEL, WHERE OLDER OBSOLETE TO FAUCET MODEL IS PRESENT, REPLACE THE TO FAUCET WITH NEW REPLACEMENT SYMMONS FAUCET MODEL (SYMMONS MODEL S6960B). REUSE EXISTING NON-FAUCET COMPONENTS SUCH AS WATER SUPPLY STOP VALVES, ETC. PROVIDE ALL NEW WATER SUPPLY TUBING AND NEW ADA PIPE INSULATION FOR P-TRAP, DRAINAGE PIPING, AND WATER PIPING. PROVIDE NEW SYMMONS MODEL 8210CK THERMOSTATIC MIXING VALVE. THE NUMBER OF FAUCETS TO VERIFY IS IDENTIFIED ON PLANS WITH CIRCLE TAG.
 2. PROVIDE NEW DECK DRAIN TO REPLACE EXISTING FAILING DECK DRAIN. PROVIDE SMITH MODEL 1410 TO REPLACE EXISTING UNIT. PROVIDE NEW ARW WATTS FRPP BLUELINE RIONFUSE OF (ELECTROFUSION) PIPING AND FITTINGS TO REPLACE EXISTING PORTIONS OF BEER STAND DRAINAGE PIPING UP TO NEW DECK DRAIN. EPOXY LINE BEER STAND DECK DRAIN BODY DRAIN INLET AND DOWNSTREAM PIPING INTO THROUGH THE ARW PIPING.
 3. EXISTING TO REMAIN LOOP VENT PIPING IN EXISTING TO REMAIN CMU WALL AT BEER STAND.



2 BEER STAND - FLOOR DRAIN
SCALE: NO SCALE

1 PLUMBING PLAN - 100 LEVEL - SECTION 7 ENLARGED
SCALE: 1/8" = 1'-0"

elaraeng.com | (708) 236-0300

INLAND SPOKES FACILITIES AUTHORITY


KEY PLAN:		
AREA OF WORK:		
ISSUE/REVISION:		
REV.	DATE	DESCRIPTION
111425		ISSUE FOR BID
110925		ISSUE FOR ADDENDUM NO. 1
PROJECT:		
GUARANTEED RATE FIELD - WASTE/VENT PIPING FY2026		
333 W 35TH STREET, CHICAGO, ILLINOIS 60616		
DRAWING TITLE:		
PLUMBING PLAN - LEVEL 100 - SECTION 7		
DESIGNED BY: CF		
CHECKED BY: MS		
PROJECT NO: 25081		
SCALE: 1/8" = 1'-0"		
SHEET NO.		




2 BEER STAND - FLOOR DRAIN
SCALE: NO SCALE



2 MECHANICAL 2.36.02 - SANITARY PIPING
SCALE: NO SCALE

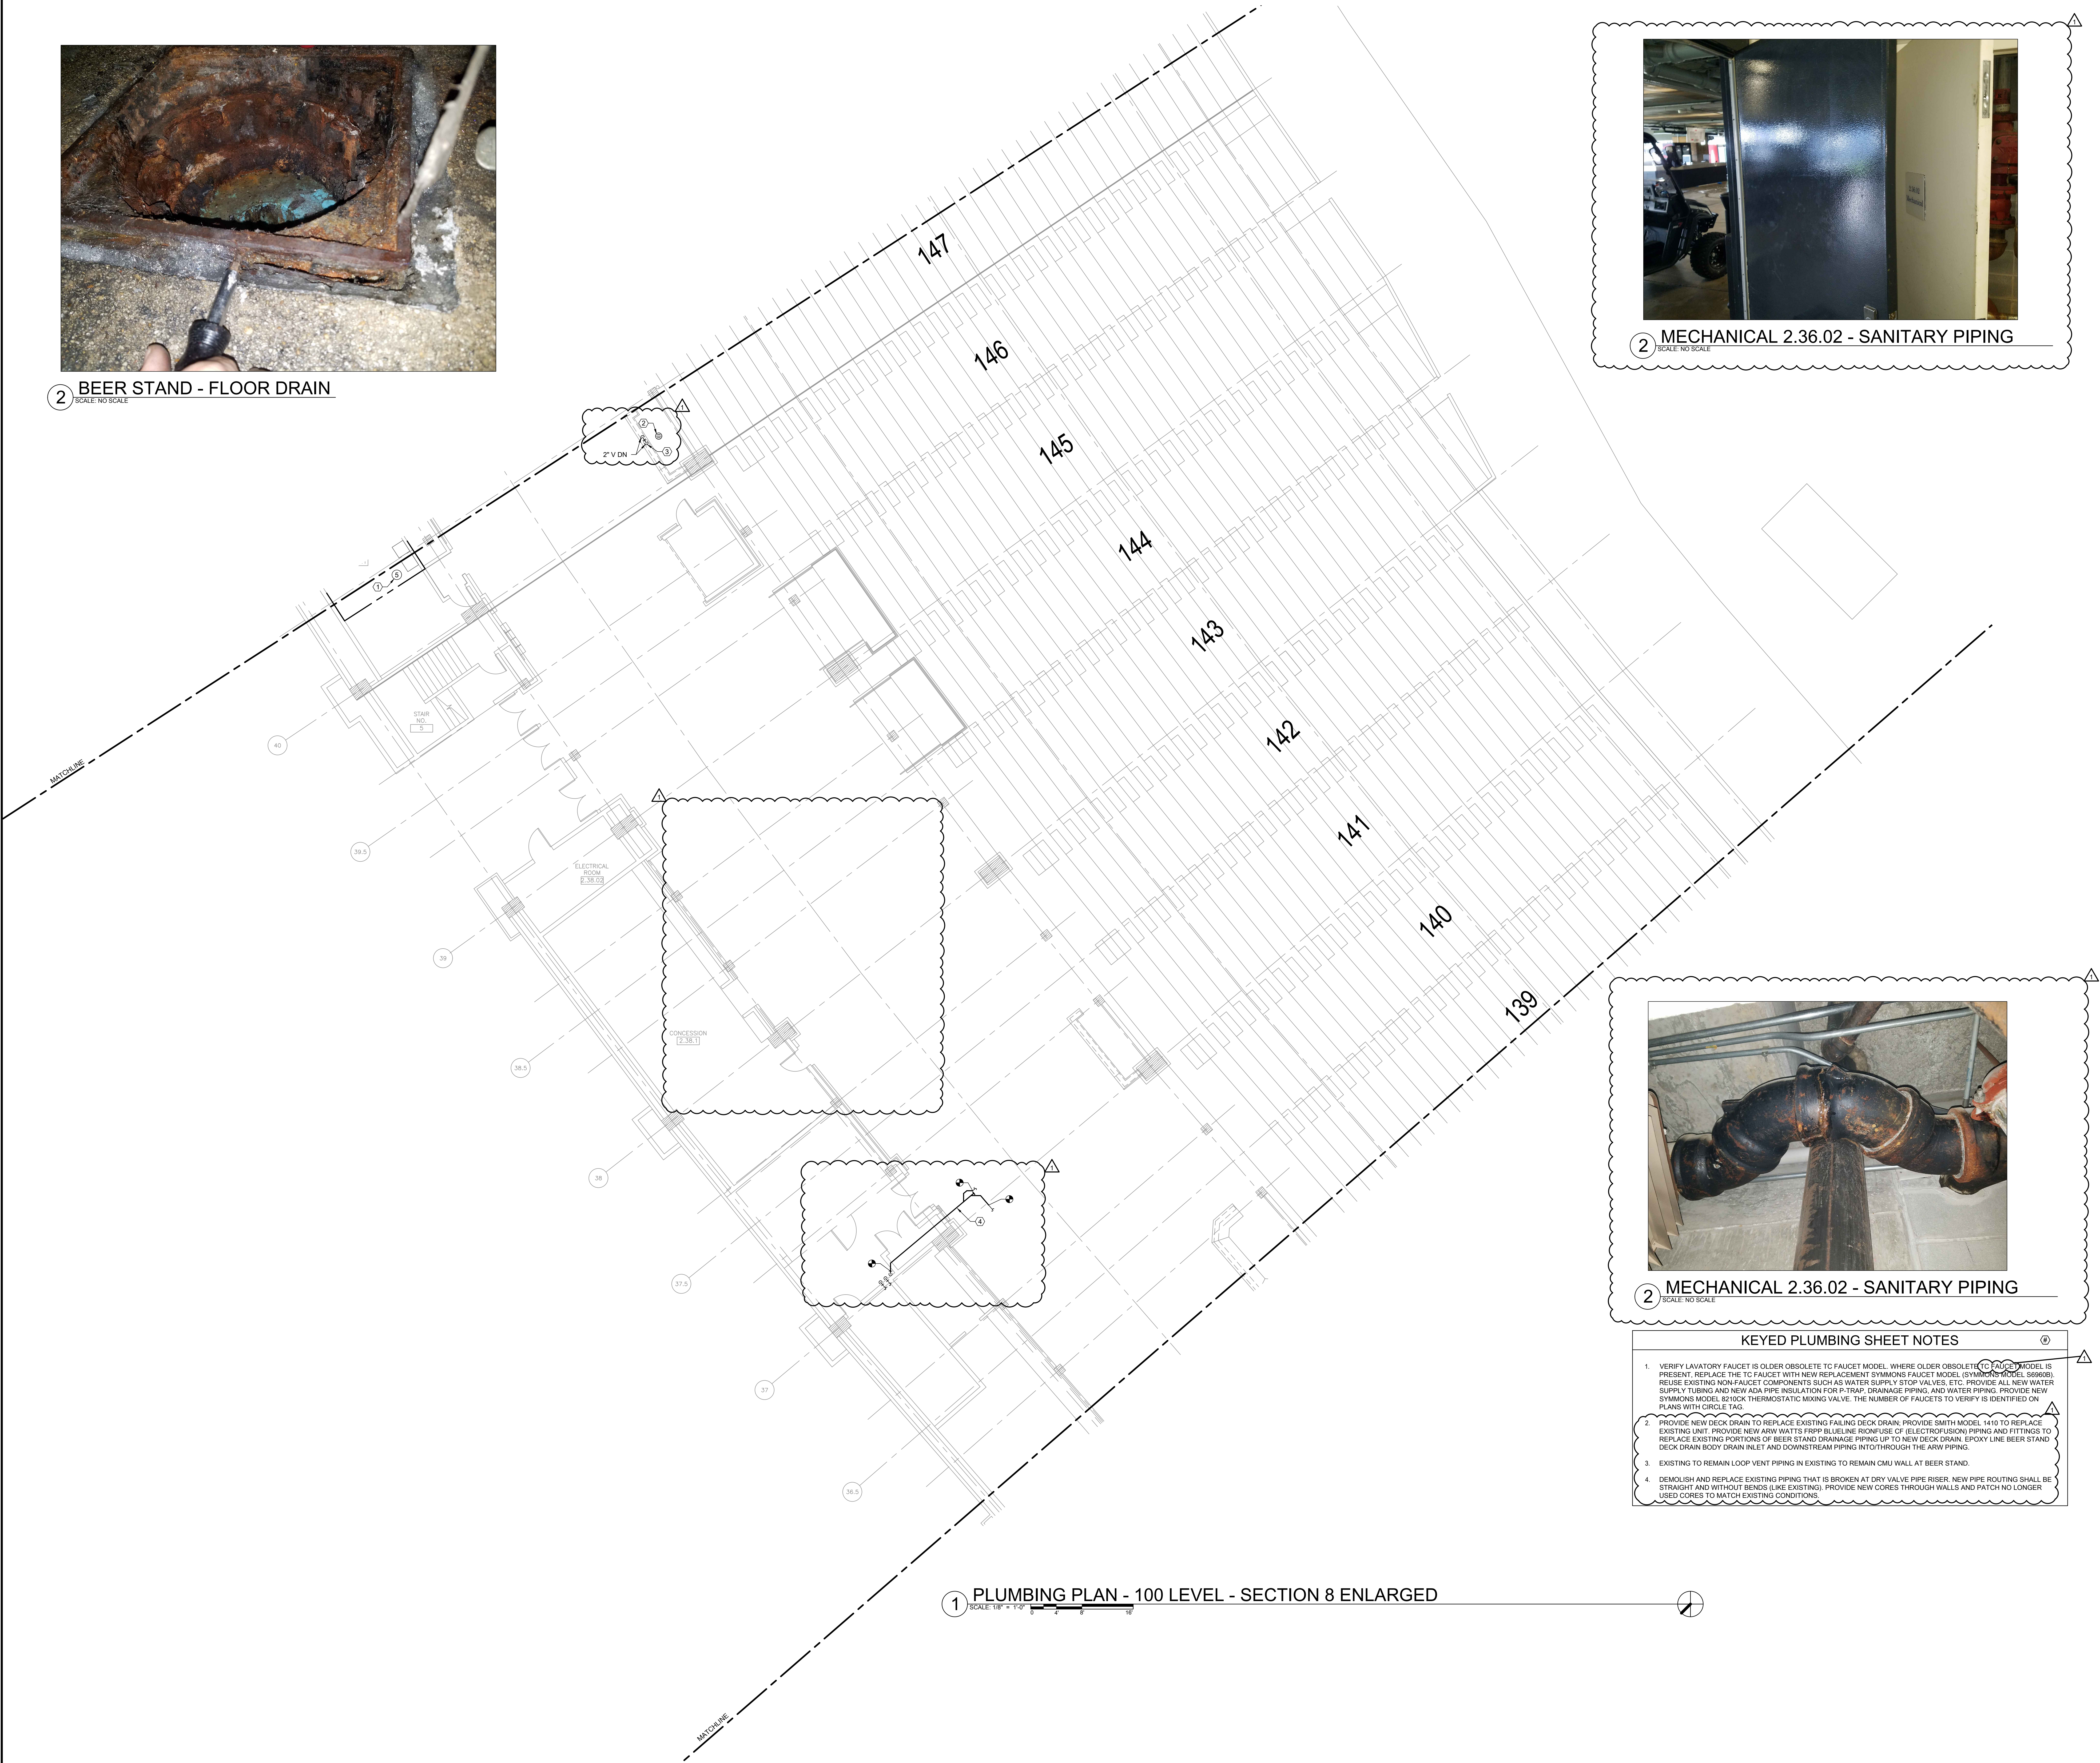

1 PLUMBING PLAN - 100 LEVEL - SECTION 8 ENLARGED
SCALE: 1/8" = 1'-0"

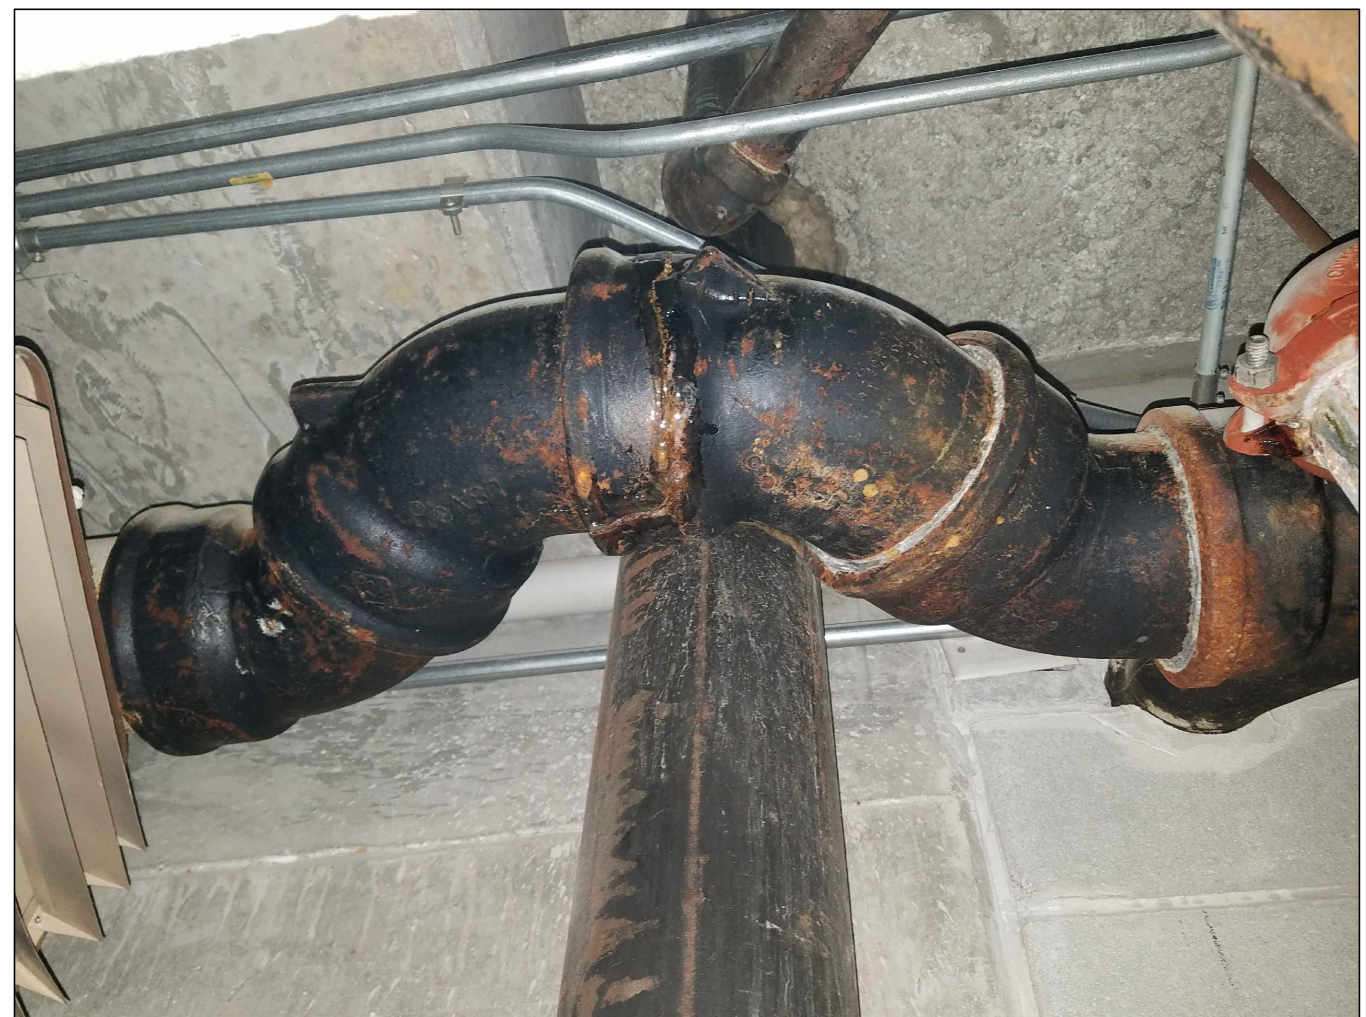


2 MECHANICAL 2.36.02 - SANITARY PIPING
SCALE: NO SCALE

KEYED PLUMBING SHEET NOTES

- VERIFY LAVATORY FAUCET IS OLDER OBSOLETE TC FAUCET MODEL WHERE OLDER OBSOLETE TC FAUCET MODEL IS PRESENT. REPLACE THE TC FAUCET WITH NEW REPLACEMENT SYMMONS FAUCET MODEL (SYMMONS MODEL 569006). REUSE EXISTING NON-FAUCET COMPONENTS SUCH AS WATER SUPPLY STOP VALVES, ETC. PROVIDE ALL NEW WATER SUPPLY TUBING AND NEW ADA PIPE INSULATION FOR P-TRAP, DRAINAGE PIPING, AND WATER PIPING. PROVIDE NEW SYMMONS MODEL 8210CK THERMOSTATIC MIXING VALVE. THE NUMBER OF FAUCETS TO VERIFY IS IDENTIFIED ON PLANS WITH CIRCLE TAG.
- PROVIDE NEW DECK DRAIN TO REPLACE EXISTING FAILING DECK DRAIN. PROVIDE SMITH MODEL 1410 TO REPLACE EXISTING UNIT. PROVIDE NEW ARW WATTS FRPP BLUELINE RIM/FUSE OF (ELECTROFUSION) PIPING AND FITTINGS TO REPLACE EXISTING PORTIONS OF BEER STAND DRAINAGE PIPING UP TO NEW DECK DRAIN. EPOXY LINE BEER STAND DECK DRAIN BODY DRAIN INLET AND DOWNSTREAM PIPING INTO/THROUGH THE ARW PIPING.
- EXISTING TO REMAIN LOOP VENT PIPING IN EXISTING TO REMAIN CMU WALL AT BEER STAND.
- DEMOLISH AND REPLACE EXISTING PIPING THAT IS BROKEN AT DRY VALVE PIPE RISER. NEW PIPE ROUTING SHALL BE STRAIGHT AND WITHOUT BENDS (LIKE EXISTING). PROVIDE NEW CORES THROUGH WALLS AND PATCH NO LONGER USED CORES TO MATCH EXISTING CONDITIONS.

KEY PLAN:

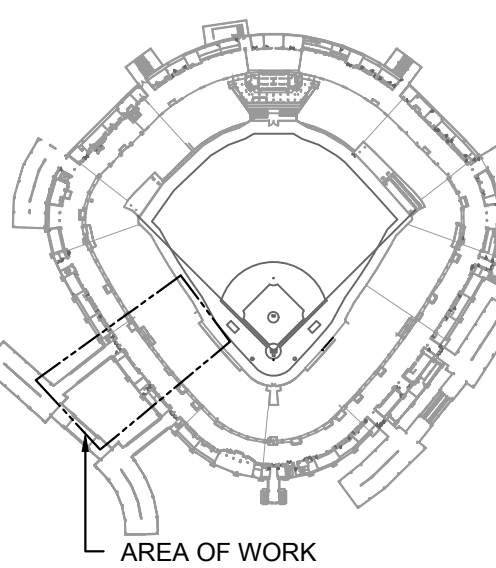

ISSUE/REVISION:

REV.	DATE	DESCRIPTION
111425		ISSUE FOR BID
110925		ISSUE FOR ADDENDUM NO. 1

PROJECT:
GUARANTEED RATE FIELD -
WASTE/VENT PIPING FY2026

333 W 35TH STREET,
CHICAGO, ILLINOIS 60616

DRAWING TITLE:
PLUMBING PLAN - LEVEL 100 -
SECTION 8

DESIGNED BY: CF
CHECKED BY: MS
PROJECT NO: 25081
SCALE: 1/8" = 1'-0"

SHEET NO.



1 PLUMBING PLAN - 100 LEVEL - SECTION 9 ENLARGED
SCALE: 1/8" = 1'-0" 0 5 10

KEYED PLUMBING SHEET NOTES

1. VERIFY LAVATORY FAUCET IS OLDER OBSOLETE TO FAUCET MODEL. WHERE OLDER OBSOLETE TO FAUCET MODEL IS PRESENT, REPLACE THE TO FAUCET WITH NEW REPLACEMENT SYMMONS FAUCET MODEL (SYMMONS MODEL 889608). REUSE EXISTING NON-FAUCET COMPONENTS SUCH AS WATER SUPPLY STOP VALVES, ETC. PROVIDE ALL NEW WATER SUPPLY TUBING AND NEW ADA PIPE INSULATION FOR P-TRAP, DRAINAGE PIPING, AND WATER PIPING. PROVIDE NEW SYMMONS MODEL 8210CK THERMOSTATIC MIXING VALVE. THE NUMBER OF FAUCETS TO VERIFY IS IDENTIFIED ON PLANS WITH CIRCLE TAG.




elaraeng.com | (708) 236-0300



ISFA
INLAND SPOKE
FACILITIES AUTHORITY



KEY PLAN:
AREA OF WORK

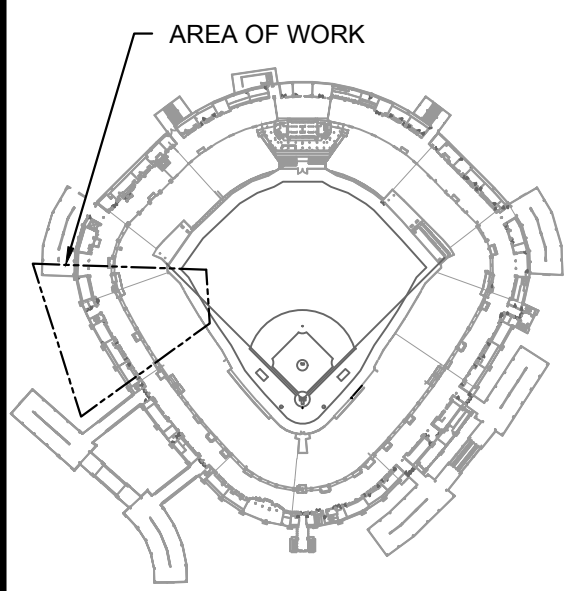

ISSUE/REVISION:

REV.	DATE	DESCRIPTION
1111425		ISSUE FOR BID
1109025		ISSUE FOR ADDENDUM NO. 1

PROJECT:

GUARANTEED RATE FIELD -
WASTE/VENT PIPING FY2026

333 W 35TH STREET,
CHICAGO, ILLINOIS 60616

DRAWING TITLE:

PLUMBING PLAN - LEVEL 100 -
SECTION 9

DESIGNED BY:

CF

CHECKED BY:

MS

PROJECT NO.:



25081

SCALE:

1/8" = 1'-0"

SHEET NO.

P1.109

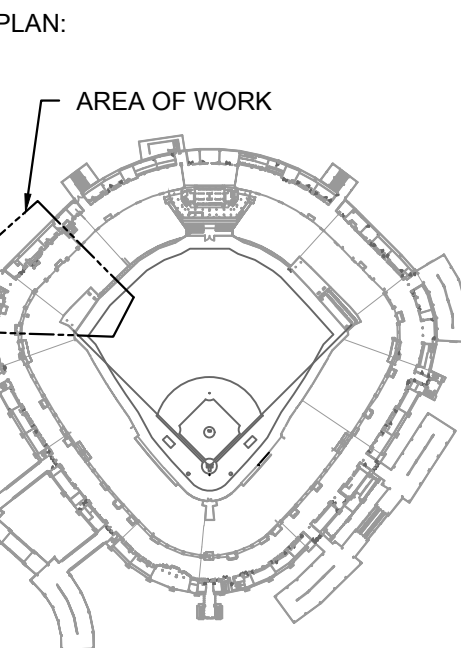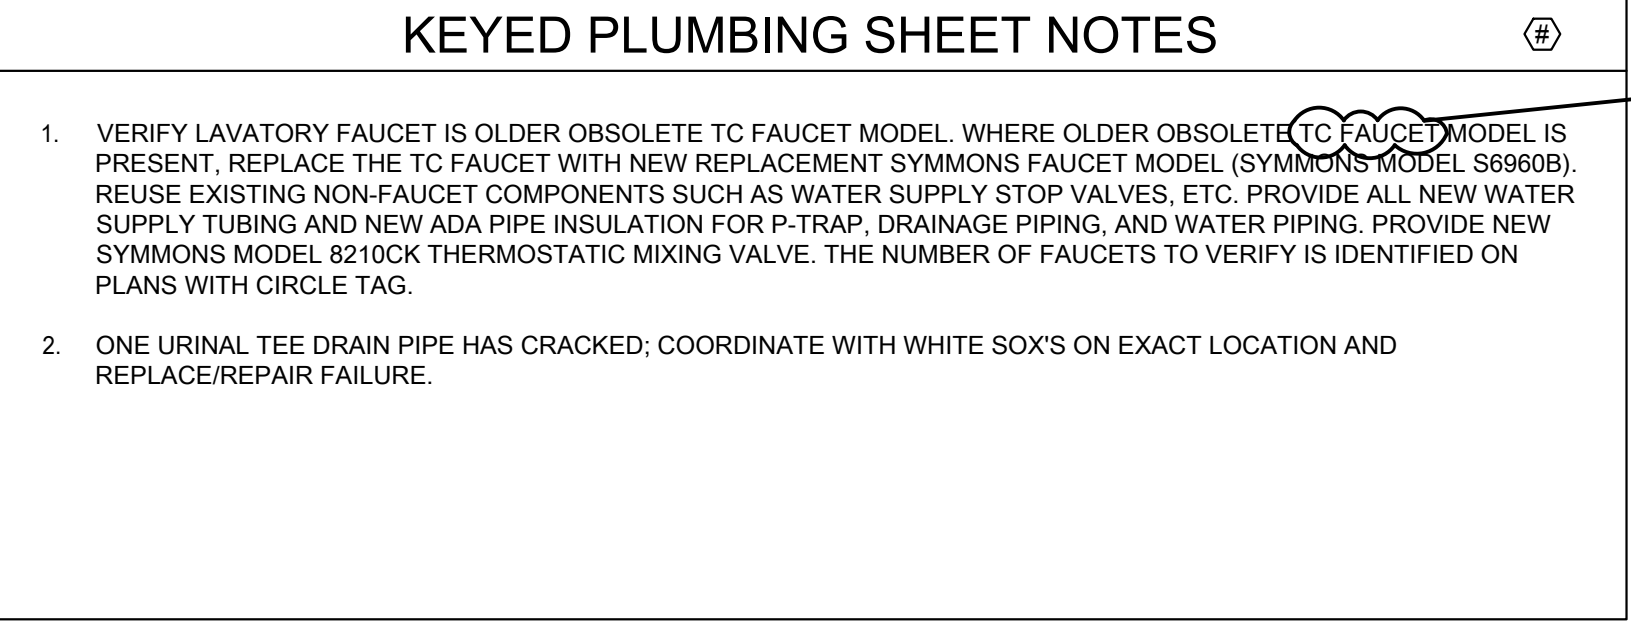[illegible]

ECT:
 GUARANTEED RATE FIELD -
 WASTE/VENT PIPING FY2026



35TH STREET,
CHICAGO, ILLINOIS 60616

CLIMBING PLAN - LEVEL 100 -
SECTION 10

DESIGNED BY:	CF
DRAWN BY:	MS
PROJECT NO:	25081
SCALE:	1/8" = 1'-0"

T NO.

P1.110

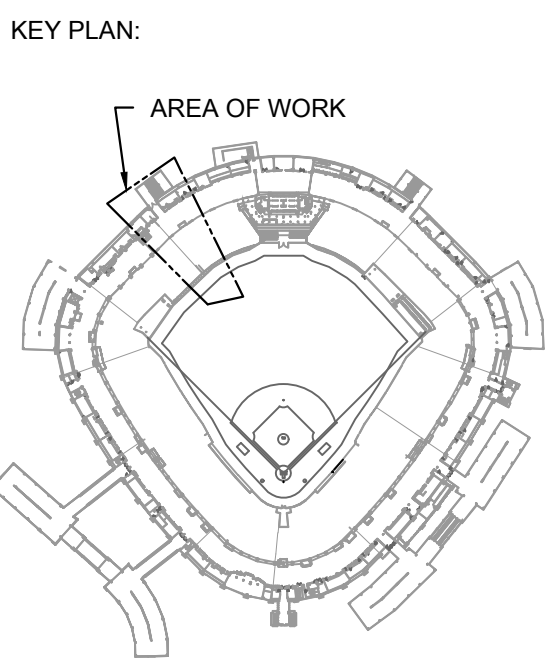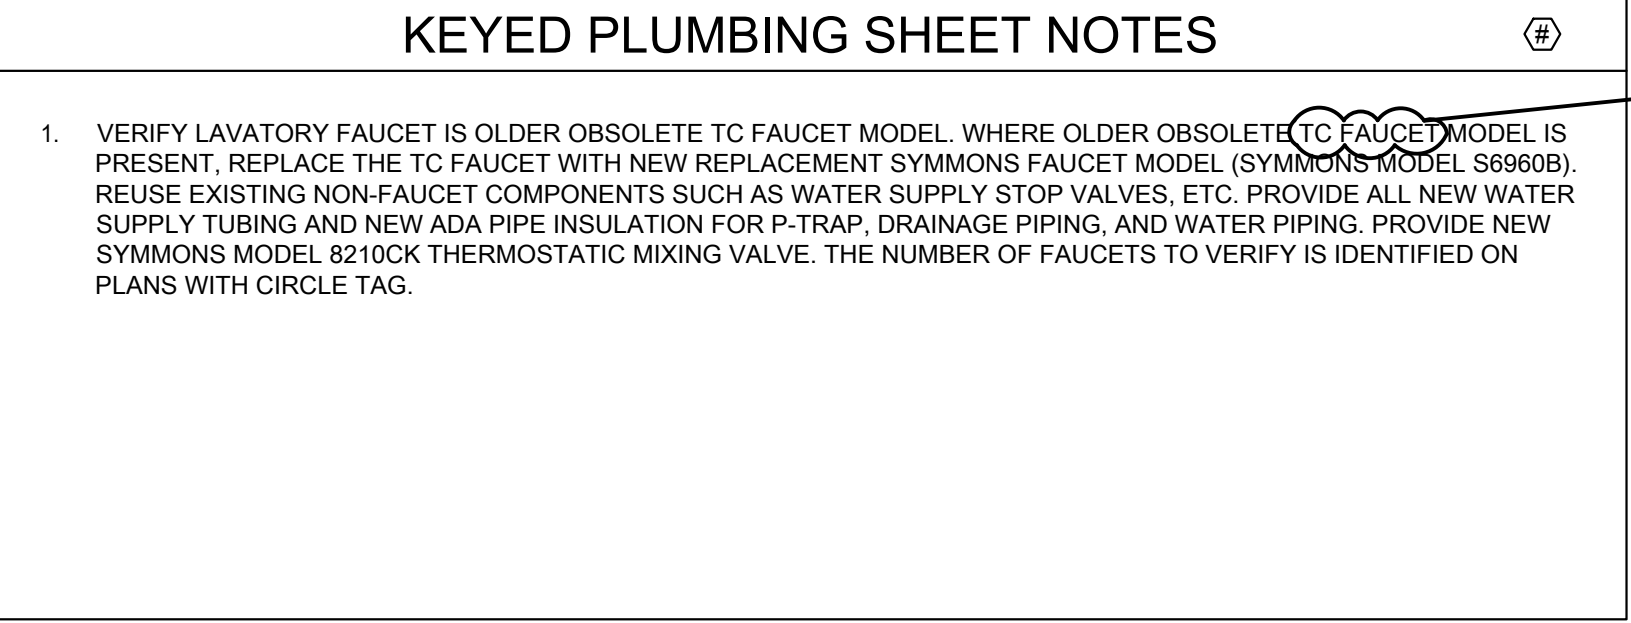[illegible]

PROJECT:
GUARANTEED RATE FIELD -
WASTE/VENT PIPING FY2026

333 W 35TH STREET,
CHICAGO, ILLINOIS 60616

DRAWING TITLE:


PLUMBING PLAN - LEVEL 100 -
SECTION 11

DESIGNED BY:	CF
CHECKED BY:	MS
PROJECT NO:	25081
SCALE:	1/8" = 1'-0"

SHEET NO.

P1.111

1 PLUMBING PLAN - 100 LEVEL - SECTION 11 ENLARGED
SCALE: 1/8" = 1'-0"
0 4' 8' 16'

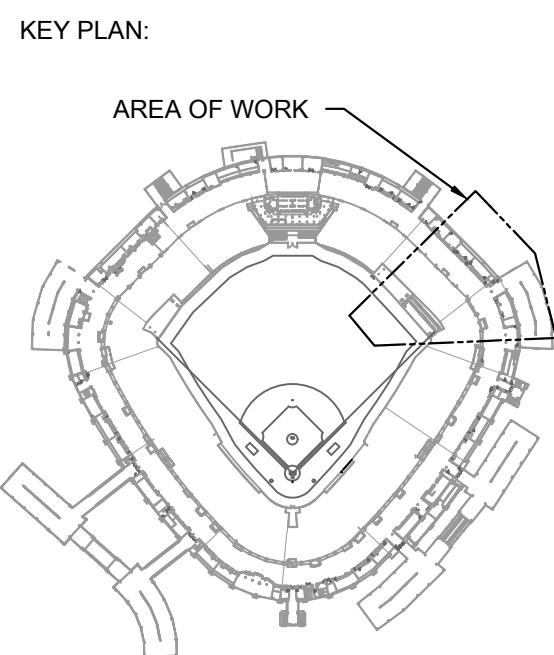

ISSUE/REVISION:		
REV.	DATE	DESCRIPTION
11/14/25		ISSUE FOR BID
11/09/25		ISSUE FOR ADDENDUM NO. 1

PROJECT:
GUARANTEED RATE FIELD -
WASTE/VENT PIPING FY2026

333 W 35TH STREET,
CHICAGO, ILLINOIS 60616

DRAWING TITLE:
PLUMBING PLAN - LEVEL 200 -
SECTION 3

DESIGNED BY: CF
CHECKED BY: MS
PROJECT NO: 25081
SCALE: 1/8" = 1'-0"

SHEET NO.

P1.203

KEYED PLUMBING SHEET NOTES

1. VERIFY LAVATORY FAUCET IS OLDER OBSOLETE TC FAUCET MODEL. WHERE OLDER OBSOLETE TC FAUCET MODEL IS PRESENT, REPLACE THE TC FAUCET WITH NEW REPLACEMENT SYMMONS FAUCET MODEL (SYMMONS MODEL 56A006). REUSE EXISTING NON-FAUCET COMPONENTS SUCH AS WATER SUPPLY STOP VALVES, ETC. PROVIDE ALL NEW WATER SUPPLY TUBING AND NEW ADA PIPE INSULATION FOR P-TRAP, DRAINAGE PIPING, AND WATER PIPING. PROVIDE NEW SYMMONS MODEL 62100K THERMOSTATIC MIXING VALVE. THE NUMBER OF FAUCETS TO VERIFY IS IDENTIFIED ON PLANS WITH CIRCLE TAG.


1 PLUMBING PLAN - 200 LEVEL - SECTION 3 ENLARGED
SCALE: 1/8" = 1'-0"



KEYED PLUMBING SHEET NOTES

1. VERIFY LAVATORY FAUCET IS OLDER OBSOLETE TC FAUCET MODEL, WHERE OLDER OBSOLETE TC FAUCET MODEL IS PRESENT, REPLACE THE TC FAUCET WITH NEW REPLACEMENT SYMMONS FAUCET MODEL (SYMMONS MODEL S6900B). REUSE EXISTING NON-FAUCET COMPONENTS SUCH AS WATER SUPPLY STOP VALVES, ETC. PROVIDE ALL NEW WATER SUPPLY TUBING AND NEW ADA PIPE INSULATION FOR P-TRAP, DRAINAGE PIPING, AND WATER PIPING. PROVIDE NEW SYMMONS MODEL 8210CK THERMOSTATIC MIXING VALVE. THE NUMBER OF FAUCETS TO VERIFY IS IDENTIFIED ON PLANS WITH CIRCLE TAG.

1 PLUMBING PLAN - 200 LEVEL - SECTION 4 ENLARGED

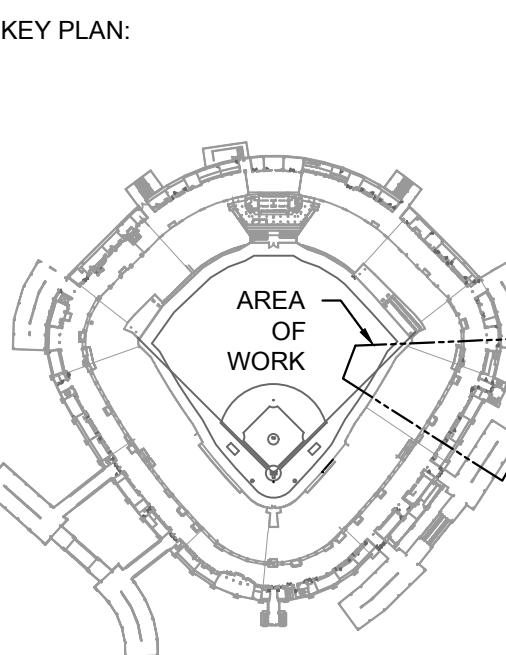

ISSUE/REVISION:		
REV.	DATE	DESCRIPTION
1	11/14/25	ISSUE FOR BID
2	11/09/25	ISSUE FOR ADDENDUM NO. 1

PROJECT:
GUARANTEED RATE FIELD -
WASTE/VENT PIPING FY2026



333 W 35TH STREET,
CHICAGO, ILLINOIS 60616

DRAWING TITLE:
PLUMBING PLAN - LEVEL 200 -
SECTION 4

DESIGNED BY: CF
CHECKED BY: MS
PROJECT NO: 25081
SCALE: 1/8" = 1'-0"

SHEET NO.

P1.204

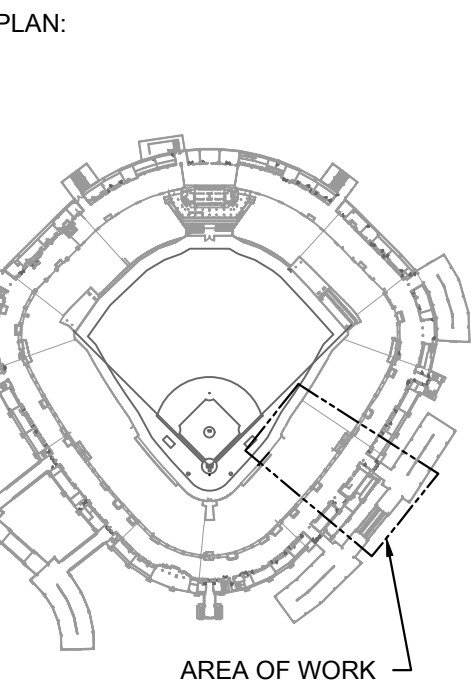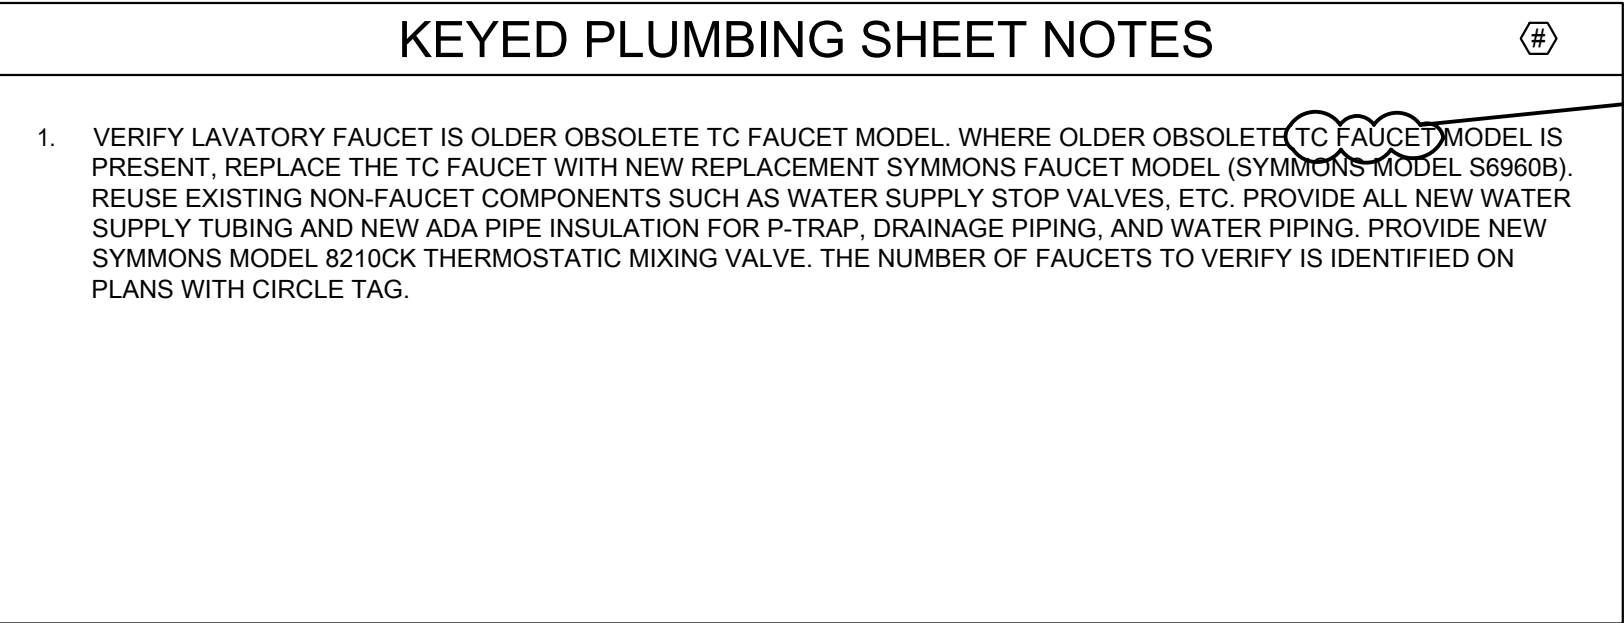[illegible]

ECT:
 GUARANTEED RATE FIELD -
 WASTE/VENT PIPING FY2026

735TH STREET,
CHICAGO, ILLINOIS 60616



CLIMBING PLAN - LEVEL 200 -
SECTION 5

DESIGNED BY:	CF
DRAWN BY:	MS
PROJECT NO:	25081
SCALE:	1/8" = 1'-0"

T NO.

P1.205

1 PLUMBING PLAN - 200 LEVEL - SECTION 5 ENLARGED
SCALE: 1/8" = 1'-0"
0 4 8 16'

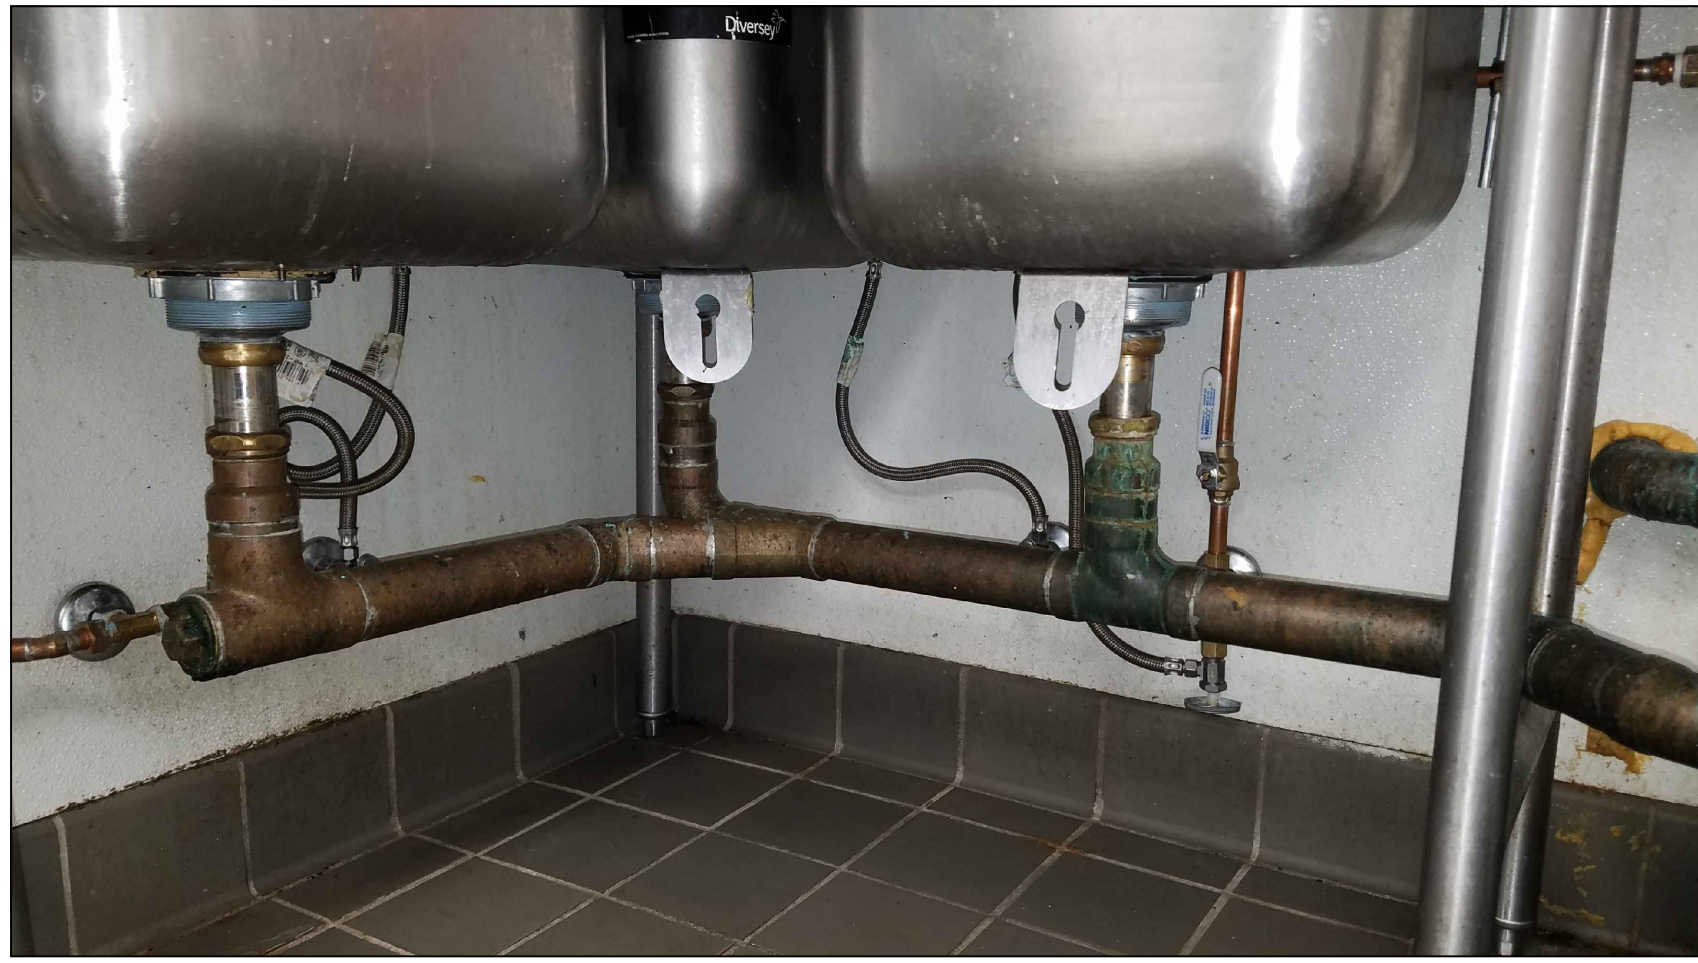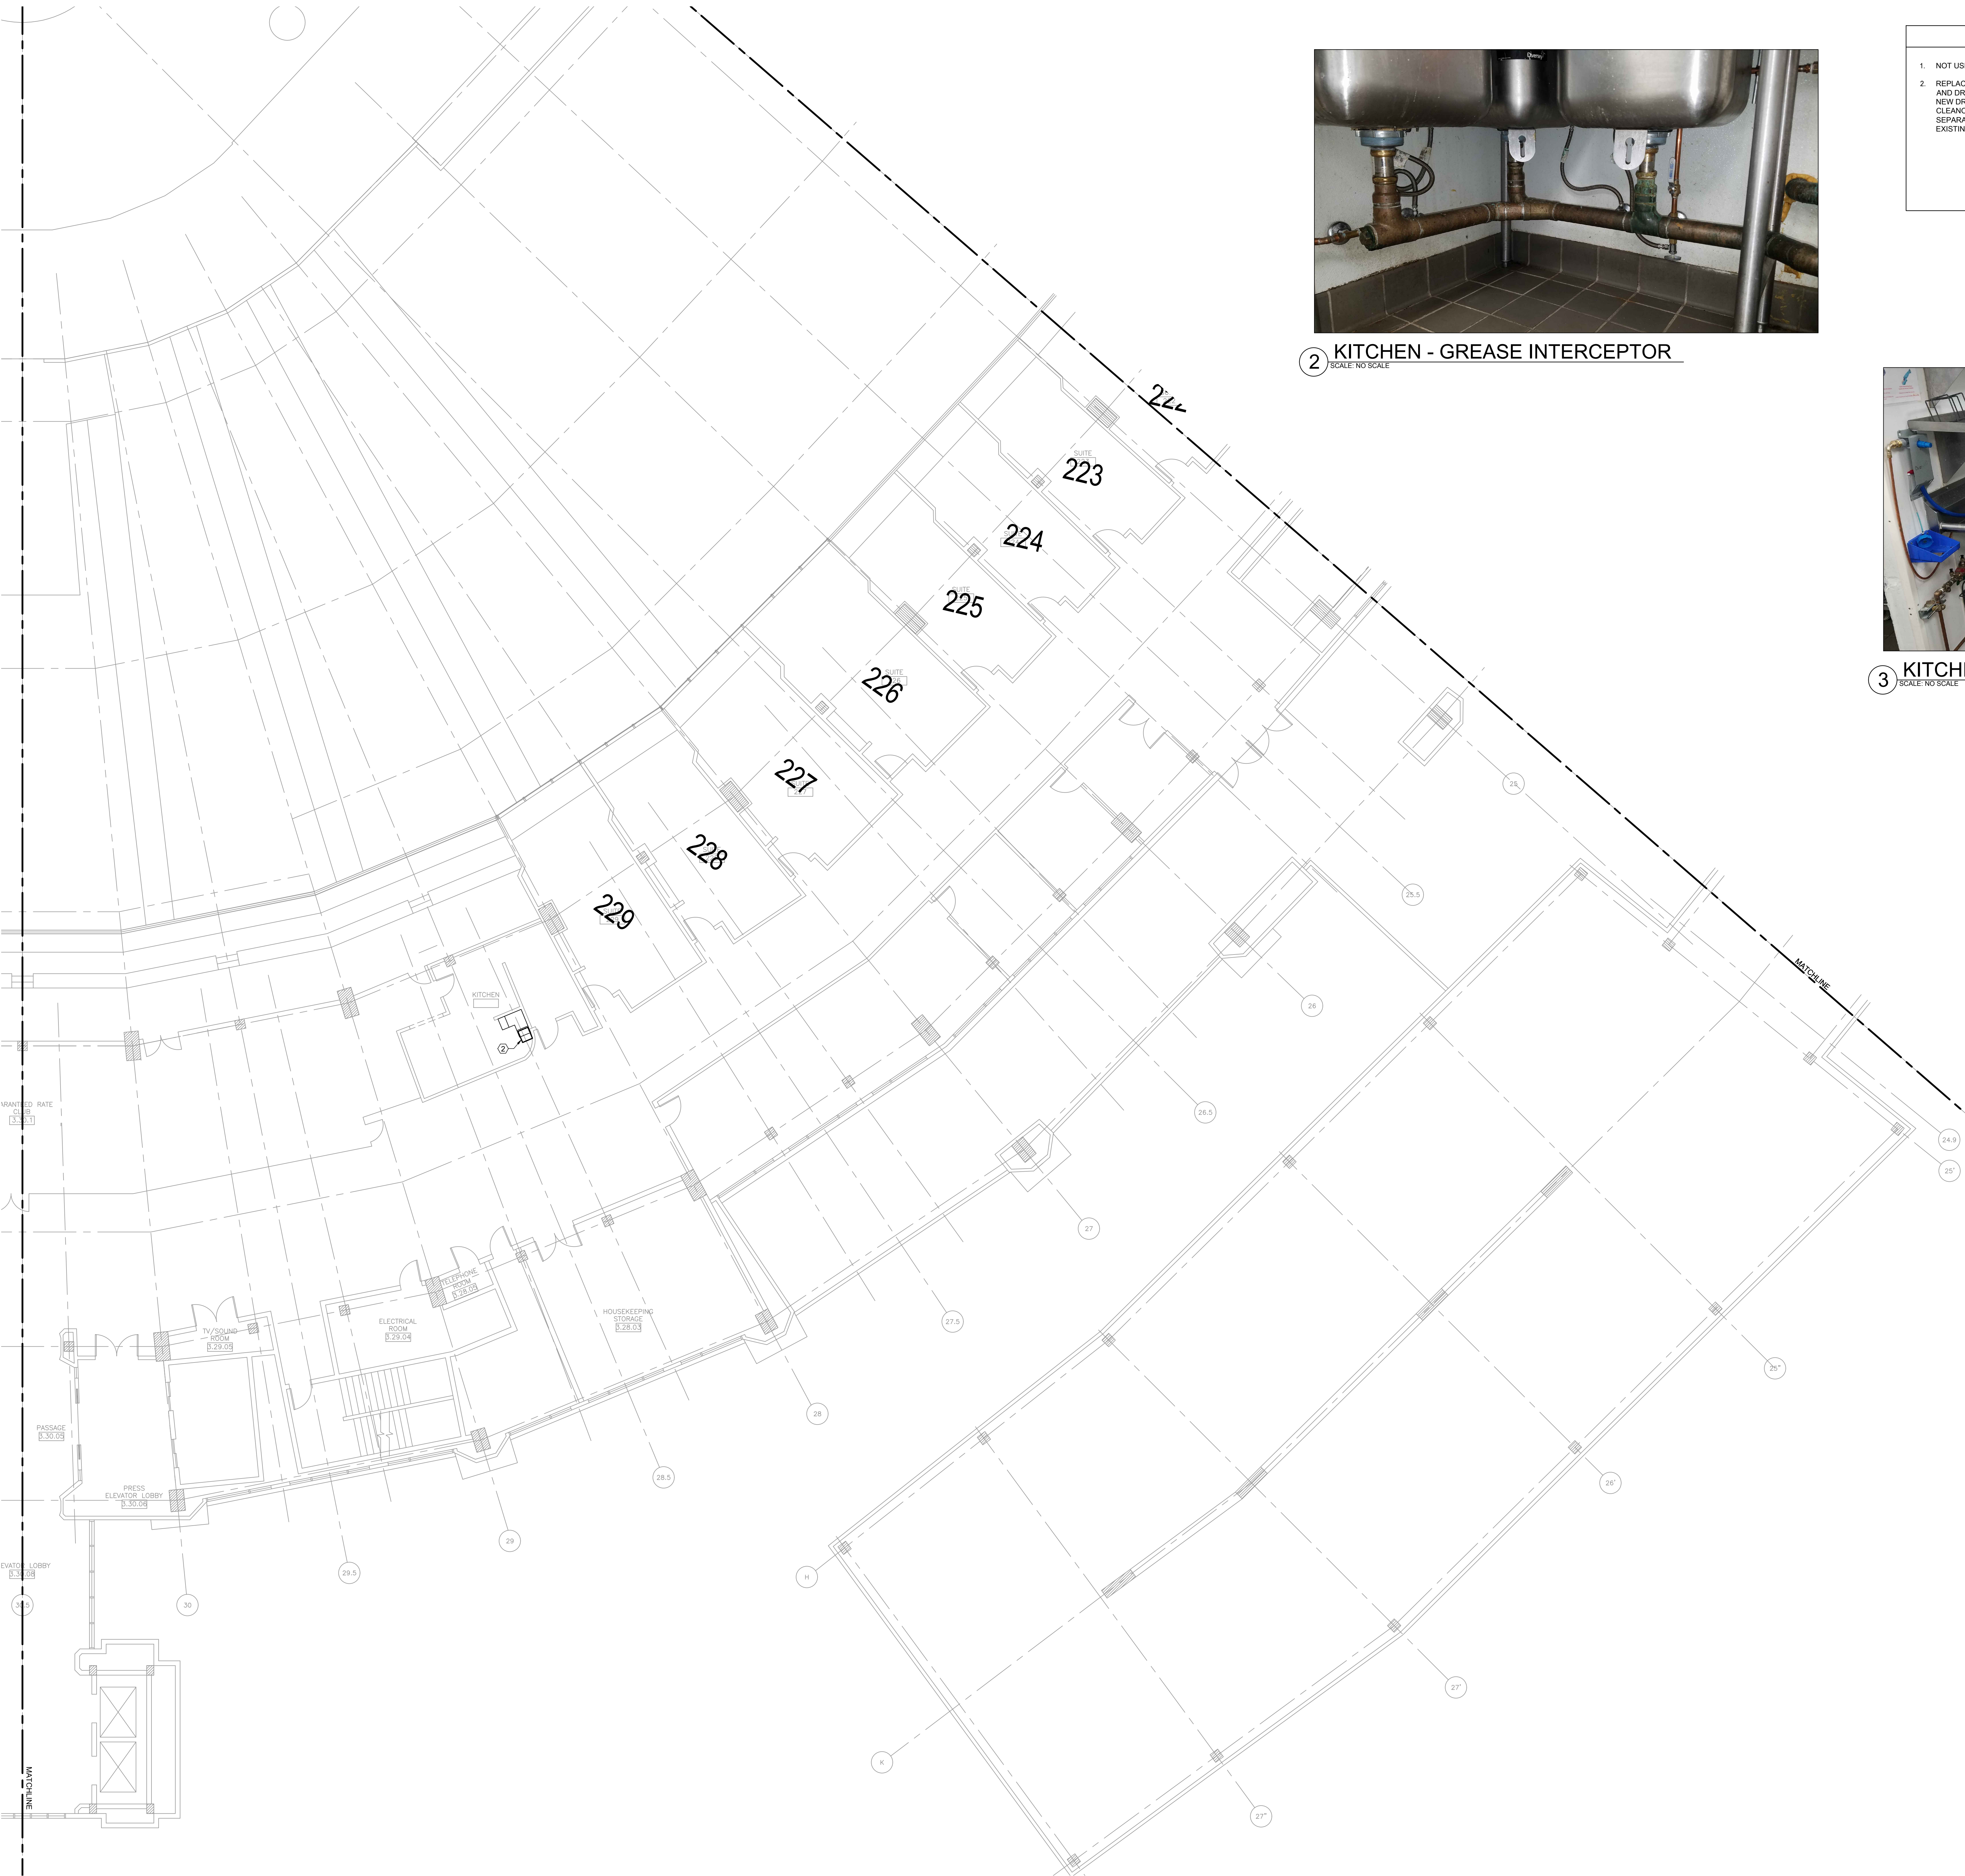


2 KITCHEN - GREASE INTERCEPTOR
SCALE: NO SCALE


KEYED PLUMBING SHEET NOTES		
1.	NOT USED.	
2.	REPLACE EXISTING GREASE INTERCEPTOR WITH NEW GREASE INTERCEPTOR. REPLACE EXISTING DRAINAGE PIPING AND DRAIN STOPPER AT EACH COMPARTMENT OF THE THREE-COMPARTMENT SINK WITH NEW DRAINAGE PIPING AND NEW DRAIN STOPPER. REPLACE EXISTING DOWNSTREAM DRAINAGE PIPING FROM THE GREASE INTERCEPTOR WITH CLEANOUT ABOVE FLOOR WITH NEW DRAINAGE PIPING. SEE DETAILS ON THIS SHEET. PROVIDE ROCKFORD SEPARATOR MODEL GF-1020-L WITH STAINLESS STEEL CONSTRUCTION. UNIT SHALL SITE ON FLOOR SIMILAR TO EXISTING INSTALLATION.	



3 KITCHEN - GREASE INTERCEPTOR
SCALE: NO SCALE

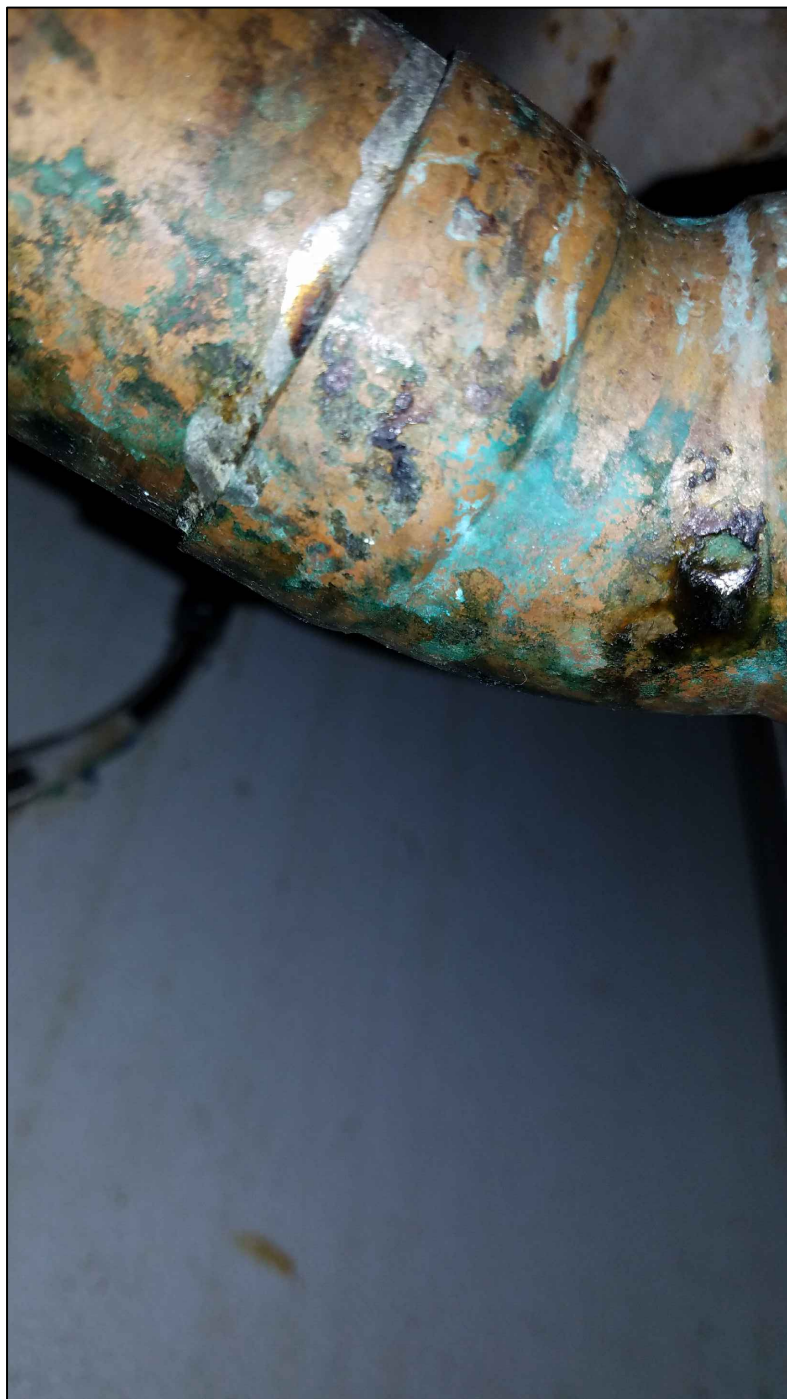

4 KITCHEN - GREASE INTERCEPTOR
SCALE: NO SCALE

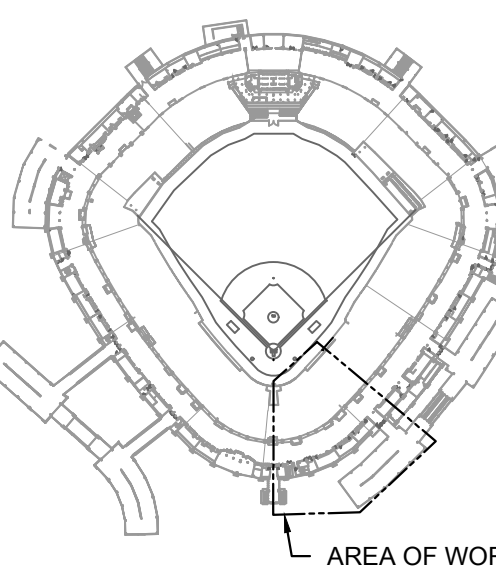


REV.	DATE	DESCRIPTION
111425		ISSUE FOR BID
110925		ISSUE FOR ADDENDUM NO. 1



1. VERIFY LAVATORY FAUCET IS OLDER OBSOLETE TC FAUCET MODEL. WHERE OLDER OBSOLETE TC FAUCET MODEL IS PRESENT, REPLACE THE TC FAUCET WITH NEW REPLACEMENT SYMMONS FAUCET MODEL (SYMMONS MODEL S6960B). REUSE EXISTING NON-FAUCET COMPONENTS SUCH AS WATER SUPPLY STOP VALVES, ETC. PROVIDE ALL NEW WATER SUPPLY TUBING AND NEW ADA PIPE INSULATION FOR P-TRAP, DRAINAGE PIPING, AND WATER PIPING. PROVIDE NEW SYMMONS MODEL 8210CK THERMOSTATIC MIXING VALVE. THE NUMBER OF FAUCETS TO VERIFY IS IDENTIFIED ON PLANS WITH CIRCLE TAG.



LAN:

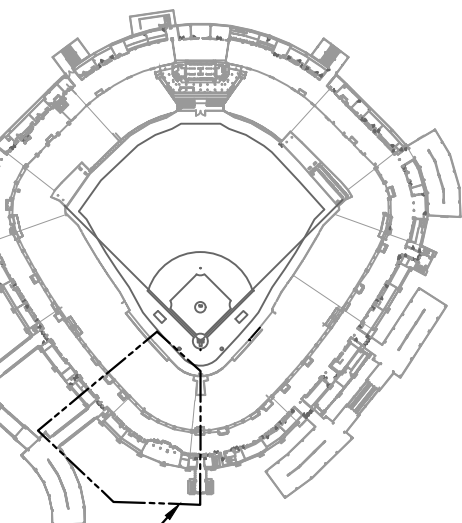

WORK

DATE	DESCRIPTION
1/14/25	ISSUE FOR BID
1/29/25	ISSUE FOR ADDENDUM NO. 1

GUARANTEED RATE FIELD -
TE/VENT PIPING FY2026

35TH STREET,
GO, ILLINOIS 60616

ING TITLE:
MBING PLAN - LEVEL 200 -
TION 7

DESIGNED BY:	CF
CHECKED BY:	MS
PROJECT NO:	25081
SCALE:	1/8" = 1'-0"

NO.

P1.207



1 PLUMBING PLAN - 200 LEVEL - SECTION 8 ENLARGED

KEYED PLUMBING SHEET NOTES

1

VERIFY LAVATORY FAUCET IS OLDER OBSOLETE TC FAUCET MODEL. WHERE OLDER OBSOLETE TC FAUCET MODEL IS PRESENT, REPLACE THE TC FAUCET WITH NEW REPLACEMENT SYMMONS FAUCET MODEL (SYMMONS MODEL 686906). REUSE EXISTING NON-FAUCET COMPONENTS SUCH AS WATER SUPPLY STOP VALVES, ETC. PROVIDE ALL NEW WATER SUPPLY TUBING AND NEW ADA PIPE INSULATION FOR P-TRAP, DRAINAGE PIPING, AND WATER PIPING. PROVIDE NEW SYMMONS MODEL 8210CK THERMOSTATIC MIXING VALVE. THE NUMBER OF FAUCETS TO VERIFY IS IDENTIFIED ON PLANS WITH CIRCLE TAG.




elaraeng.com | (708) 236-0300



INLAND SPOKE FACILITIES AUTHORITY

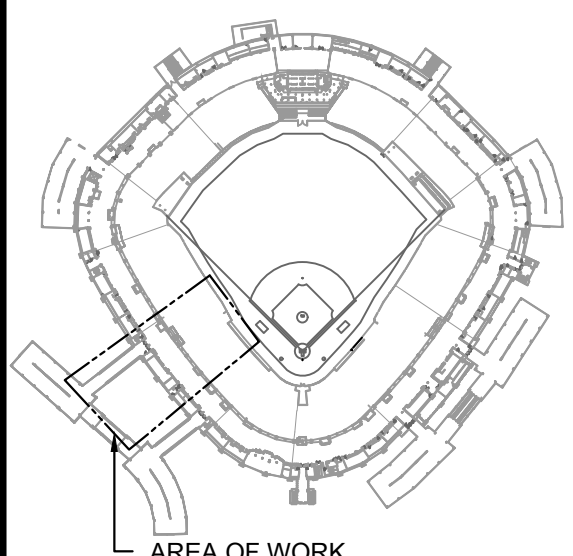

KEY PLAN:


AREA OF WORK

ISSUE/REVISION:

REV.	DATE	DESCRIPTION
11/14/25		ISSUE FOR BID
11/09/25		ISSUE FOR ADDENDUM NO. 1

PROJECT:

GUARANTEED RATE FIELD - WASTE/VENT PIPING FY2026

333 W 35TH STREET, CHICAGO, ILLINOIS 60616

DRAWING TITLE:

PLUMBING PLAN - LEVEL 200 - SECTION 8

DESIGNED BY:

CF

CHECKED BY:

MS

PROJECT NO.:

25081

SCALE:

1/8" = 1'-0"

SHEET NO.


P1.208



1 PLUMBING PLAN - 200 LEVEL - SECTION 9 ENLARGED
SCALE: 1/8" = 1'-0" 0 5 10

KEYED PLUMBING SHEET NOTES

1. VERIFY LAVATORY FAUCET IS OLDER OBSOLETE TO FAUCET MODEL. WHERE OLDER OBSOLETE TO FAUCET MODEL IS PRESENT, REPLACE THE TO FAUCET WITH NEW REPLACEMENT SYMMONS FAUCET MODEL (SYMMONS MODEL 889608). REUSE EXISTING NON-FAUCET COMPONENTS SUCH AS WATER SUPPLY STOP VALVES, ETC. PROVIDE ALL NEW WATER SUPPLY TUBING AND NEW ADA PIPE INSULATION FOR P-TRAP, DRAINAGE PIPING, AND WATER PIPING. PROVIDE NEW SYMMONS MODEL 8210CK THERMOSTATIC MIXING VALVE. THE NUMBER OF FAUCETS TO VERIFY IS IDENTIFIED ON PLANS WITH CIRCLE TAG.

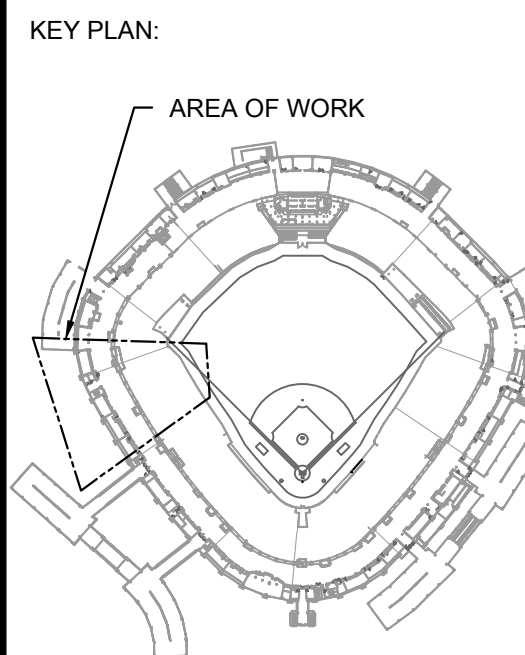

ISSUE/REVISION:		
REV.	DATE	DESCRIPTION
1111425		ISSUE FOR BID
1109025		ISSUE FOR ADDENDUM NO. 1



PROJECT:
GUARANTEED RATE FIELD -
WASTE/VENT PIPING FY2026

333 W 35TH STREET,
CHICAGO, ILLINOIS 60616

DRAWING TITLE:
PLUMBING PLAN - LEVEL 200 -
SECTION 9

DESIGNED BY: CF
CHECKED BY: MS
PROJECT NO: 25081
SCALE: 1/8" = 1'-0"

SHEET NO.
P1.209

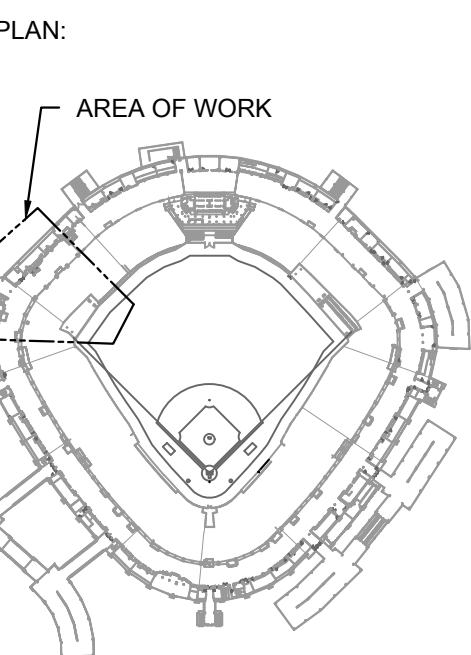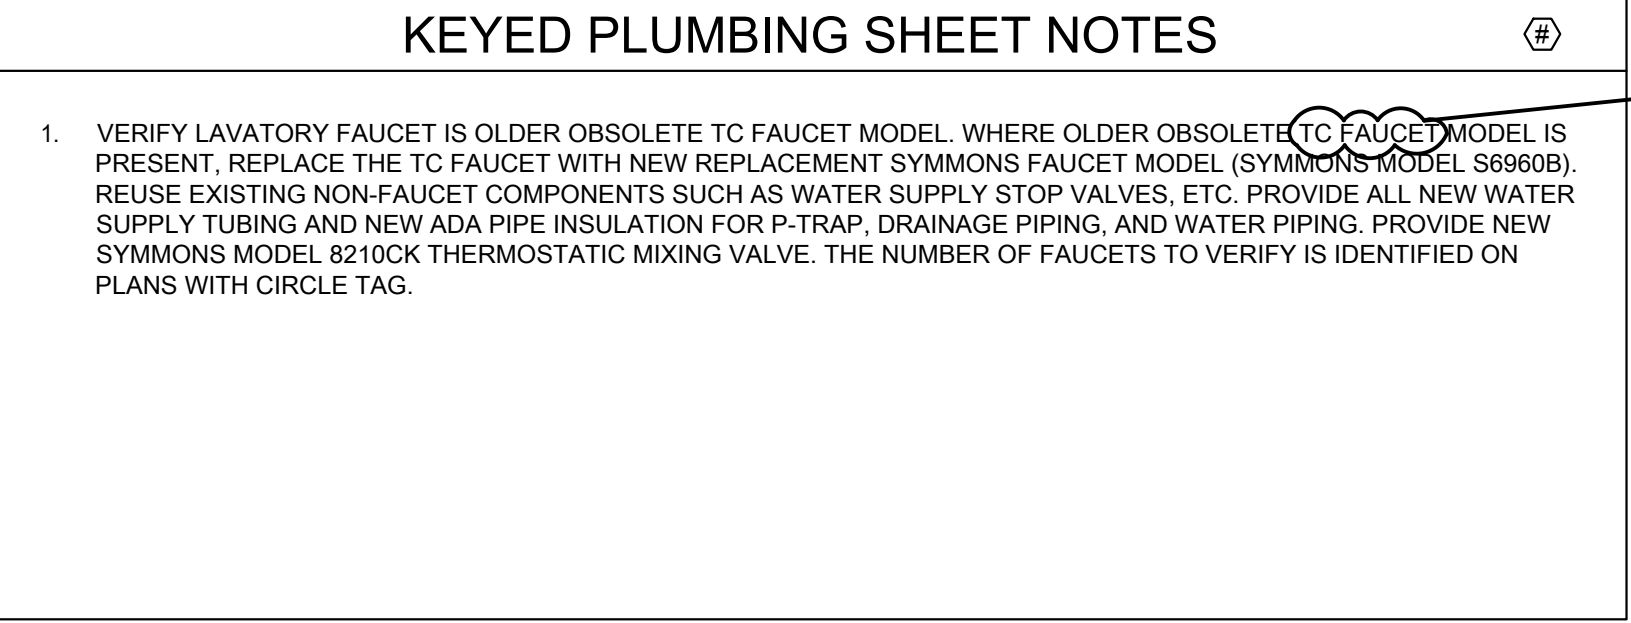

DATE/REVISION:	
DATE	DESCRIPTION
11/14/25	ISSUE FOR BID
11/26/25	ISSUE FOR ADDENDUM NO. 1

GUARANTEED RATE FIELD -
WASTE/VENT PIPING FY2026

Y 35TH STREET,
AGO, ILLINOIS 60616

CLIMBING PLAN - LEVEL 200 -
SECTION 10

DESIGNED BY:	CF
DRAWN BY:	MS
PROJECT NO:	25081
SCALE:	1/8" = 1'-0"

T NO.

P1.210




KEYED PLUMBING SHEET NOTES

1. VERIFY LAVATORY FAUCET IS OLDER OBSOLETE TC FAUCET MODEL. WHERE OLDER OBSOLETE TC FAUCET MODEL IS PRESENT, REPLACE THE TC FAUCET WITH NEW REPLACEMENT SYMMONS FAUCET MODEL (SYMMONS MODEL S6900B). REUSE EXISTING NON-FAUCET COMPONENTS SUCH AS WATER SUPPLY STOP VALVES, ETC. PROVIDE ALL NEW WATER SUPPLY TUBING AND NEW ADA PIPE INSULATION FOR P-TRAP, DRAINAGE PIPING, AND WATER PIPING. PROVIDE NEW SYMMONS MODEL 8210CK THERMOSTATIC MIXING VALVE. THE NUMBER OF FAUCETS TO VERIFY IS IDENTIFIED ON PLANS WITH CIRCLE TAG.
2. PROVIDE NEW 3/4" HOT WATER RETURN PIPING FROM END OF THE HOT WATER SUPPLY PIPING TO THE LAST SINK FIXTURE TO IMPROVE THE HOT WATER DELIVERY TO THE KITCHEN AND FOOD PREP AREA. INSULATE PIPING AND PROVIDE NEW HOT WATER RETURN BALANCING STATION.
3. DEMOLISH AND REPLACE EXISTING HOT WATER SUPPLY PIPING IN AREAS OF WORK SCOPE HERE; REPLACE AS SHOWN BACK-UPSTREAM TO THE ELBOW DROP DOWN TO FLOOR BELOW.

1 PLUMBING PLAN - 300 LEVEL - SECTION 4 ENLARGED

KEY PLAN:

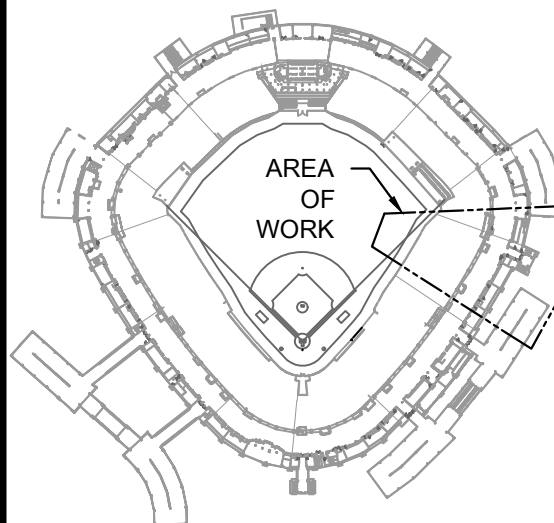

ISSUE/REVISION:

REV.	DATE	DESCRIPTION
111425		ISSUE FOR BID
110925		ISSUE FOR ADDENDUM NO. 1

PROJECT:
GUARANTEED RATE FIELD -
WASTE/VENT PIPING FY2026

333 W 35TH STREET,
CHICAGO, ILLINOIS 60616

DRAWING TITLE:
PLUMBING PLAN - LEVEL 300 -
SECTION 4

DESIGNED BY: CF
CHECKED BY: MS
PROJECT NO: 25081
SCALE: 1/8" = 1'-0"

SHEET NO.



KEYED PLUMBING SHEET NOTES

1. VERIFY LAVATORY FAUCET IS OLDER OBSOLETE TC FAUCET MODEL. WHERE OLDER OBSOLETE TC FAUCET MODEL IS PRESENT, REPLACE THE TC FAUCET WITH NEW REPLACEMENT SYMMONS FAUCET MODEL (SYMMONS MODEL S99R08). REUSE EXISTING NON-FAUCET COMPONENTS SUCH AS WATER SUPPLY STOP VALVES, ETC. PROVIDE ALL NEW WATER SUPPLY TUBING AND NEW ADA PIPE INSULATION FOR P-TRAP, DRAINAGE PIPING, AND WATER PIPING. PROVIDE NEW SYMMONS MODEL 82 LOCK THERMOSTATIC MIXING VALVE. THE NUMBER OF FAUCETS TO VERIFY IS IDENTIFIED ON PLANS WITH CIRCLE TAG.




elaraeng.com | (708) 236-0300



ILLINOIS SPORTS FACILITIES AUTHORITY



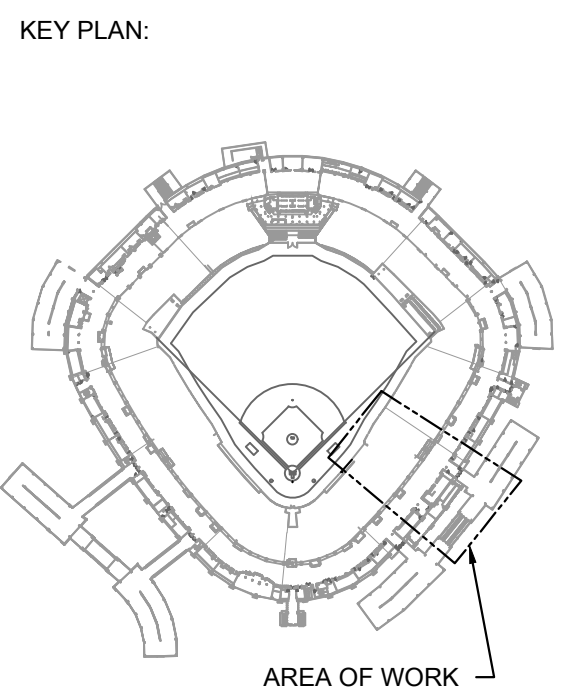

ISSUE/REVISION:		
REV.	DATE	DESCRIPTION
1	11/14/25	ISSUE FOR BID
2	11/09/25	ISSUE FOR ADDENDUM NO. 1

PROJECT:
GUARANTEED RATE FIELD -
WASTE/VENT PIPING FY2026

333 W 35TH STREET,
CHICAGO, ILLINOIS 60616

DRAWING TITLE:
PLUMBING PLAN - LEVEL 300 -
SECTION 5

DESIGNED BY: CF
CHECKED BY: MS
PROJECT NO: 25081
SCALE: 1/8" = 1'-0"

SHEET NO:
P1.305



KEYED PLUMBING SHEET NOTES

1. VERIFY LAVATORY FAUCET IS OLDER OBSOLETE TC FAUCET MODEL. WHERE OLDER OBSOLETE TC FAUCET MODEL IS PRESENT, REPLACE THE TC FAUCET WITH NEW REPLACEMENT SYMMONS FAUCET MODEL (SYMMONS MODEL S99R08). REUSE EXISTING NON-FAUCET COMPONENTS SUCH AS WATER SUPPLY STOP VALVES, ETC. PROVIDE ALL NEW WATER SUPPLY TUBING AND NEW ADA PIPE INSULATION FOR P-TRAP, DRAINAGE PIPING, AND WATER PIPING. PROVIDE NEW SYMMONS MODEL 821000 THERMOSTATIC MIXING VALVE. THE NUMBER OF FAUCETS TO VERIFY IS IDENTIFIED ON PLANS WITH CIRCLE TAG.

2. VIDEO SCOPE OWNER SUITE PIPING.




elaraeng.com | (708) 236-0300



ILLINOIS SPORTS FACILITIES AUTHORITY



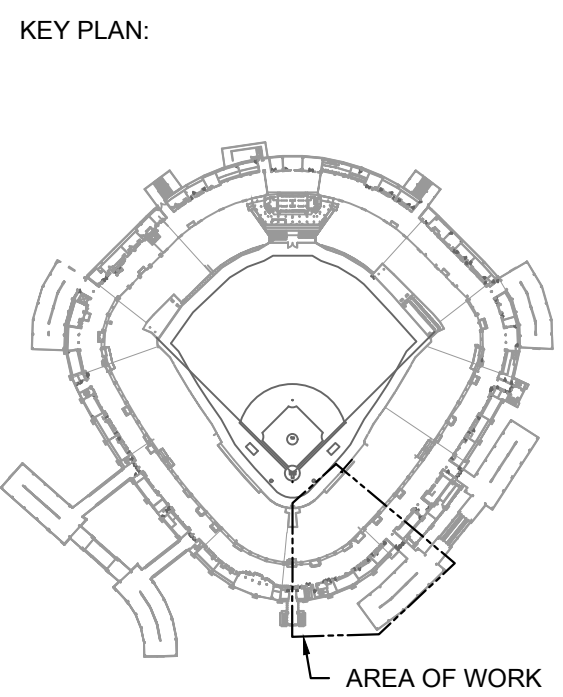

ISSUE/REVISION:		
REV.	DATE	DESCRIPTION
1	11/14/25	ISSUE FOR BID
2	11/09/25	ISSUE FOR ADDENDUM NO. 1



PROJECT:
GUARANTEED RATE FIELD -
WASTE/VENT PIPING FY2026

333 W 35TH STREET,
CHICAGO, ILLINOIS 60616

DRAWING TITLE:
PLUMBING PLAN - LEVEL 300 -
SECTION 6

DESIGNED BY:	CF
CHECKED BY:	MS
PROJECT NO:	25081
SCALE:	1/8" = 1'-0"
SHEET NO.	

P1.306

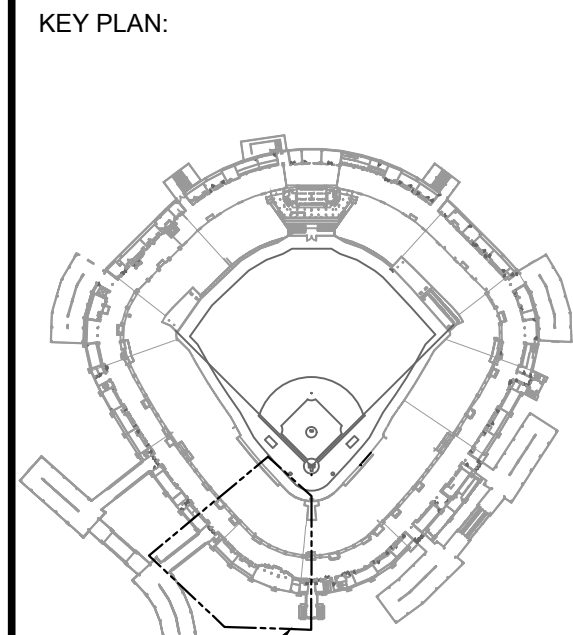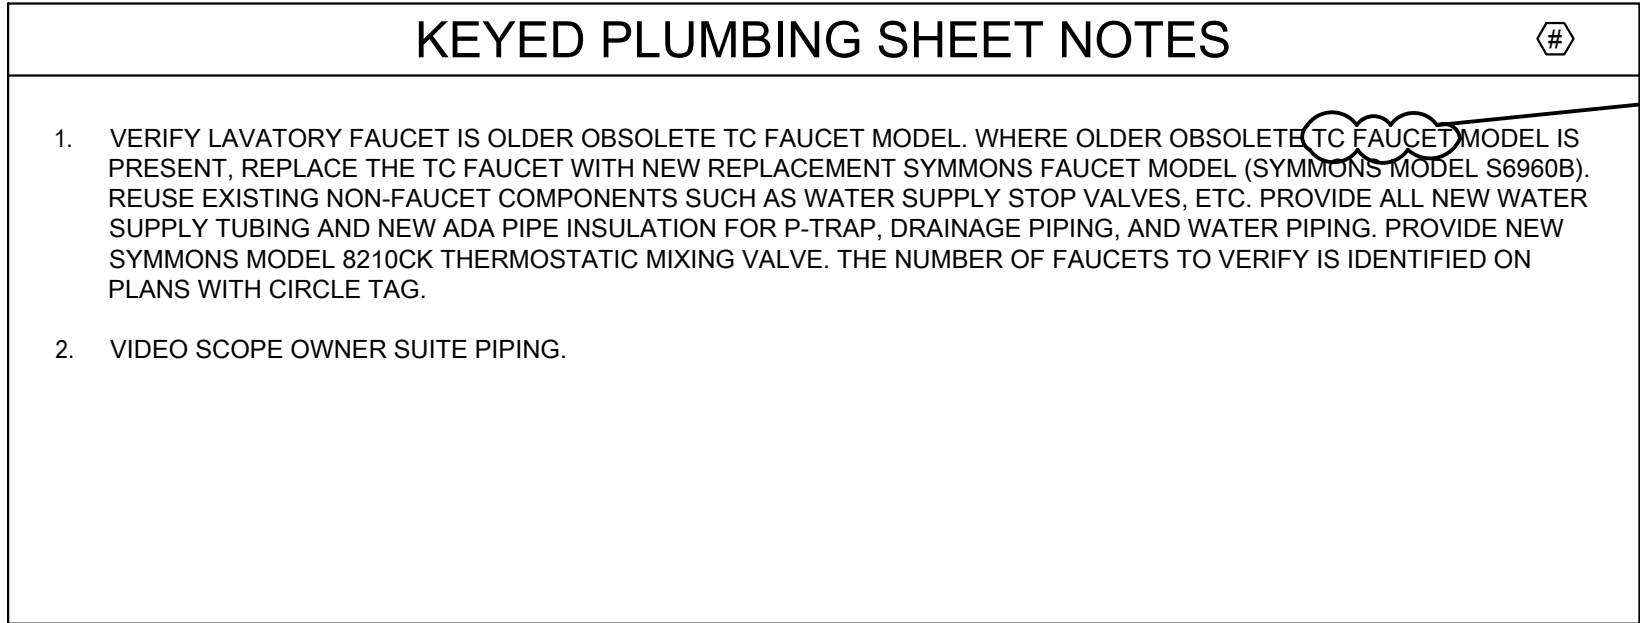[illegible]

DRAWING TITLE:
PLUMBING PLAN - LEVEL 300 -
SECTION 7

DESIGNED BY:	CF
CHECKED BY:	MS
PROJECT NO:	25081
SCALE:	1/8" = 1'-0"
SHEET NO.	

P1.307

1 PLUMBING PLAN - 300 LEVEL - SECTION 7 ENLARGED
SCALE: 1/8" = 1'-0" 0 4' 8' 16'



KEYED PLUMBING SHEET NOTES

1

VERIFY LAVATORY FAUCET IS OLDER OBSOLETE TC FAUCET MODEL. WHERE OLDER OBSOLETE TC FAUCET MODEL IS PRESENT, REPLACE THE TC FAUCET WITH NEW REPLACEMENT SYMMONS FAUCET MODEL (SYMMONS MODEL 886906). REUSE EXISTING NON-FAUCET COMPONENTS SUCH AS WATER SUPPLY STOP VALVES, ETC. PROVIDE ALL NEW WATER SUPPLY TUBING AND NEW ADA PIPE INSULATION FOR P-TRAP, DRAINAGE PIPING, AND WATER PIPING. PROVIDE NEW SYMMONS MODEL 8210CK THERMOSTATIC MIXING VALVE. THE NUMBER OF FAUCETS TO VERIFY IS IDENTIFIED ON PLANS WITH CIRCLE TAG.




P1.309



KEYED PLUMBING SHEET NOTES

1. VERIFY LAVATORY FAUCET IS OLDER OBSOLETE TC FAUCET MODEL, WHERE OLDER OBSOLETE TC FAUCET MODEL IS PRESENT, REPLACE THE TC FAUCET WITH NEW REPLACEMENT SYMMONS FAUCET MODEL (SYMMONS MODEL S6900B). REUSE EXISTING NON-FAUCET COMPONENTS SUCH AS WATER SUPPLY STOP VALVES, ETC. PROVIDE ALL NEW WATER SUPPLY TUBING AND NEW ADA PIPE INSULATION FOR P-TRAP, DRAINAGE PIPING, AND WATER PIPING. PROVIDE NEW SYMMONS MODEL 8210CK THERMOSTATIC MIXING VALVE. THE NUMBER OF FAUCETS TO VERIFY IS IDENTIFIED ON PLANS WITH CIRCLE TAG.

1 PLUMBING PLAN - 400 LEVEL - SECTION 4 ENLARGED

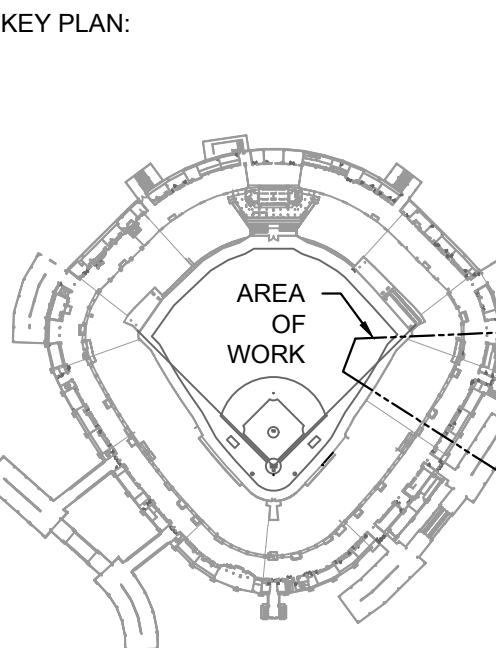

ISSUE/REVISION:		
REV.	DATE	DESCRIPTION
111425		ISSUE FOR BID
110925		ISSUE FOR ADDENDUM NO. 1



PROJECT:
GUARANTEED RATE FIELD -
WASTE/VENT PIPING FY2026

333 W 35TH STREET,
CHICAGO, ILLINOIS 60616

DRAWING TITLE:
PLUMBING PLAN - LEVEL 400 -
SECTION 4

DESIGNED BY: CF
CHECKED BY: MS
PROJECT NO: 25081
SCALE: 1/8" = 1'-0"

SHEET NO.
P1.404

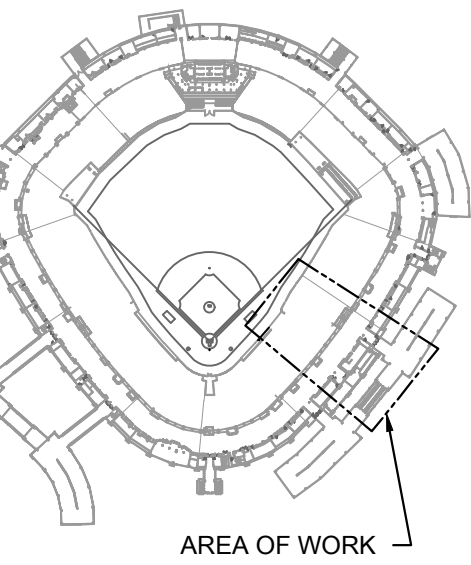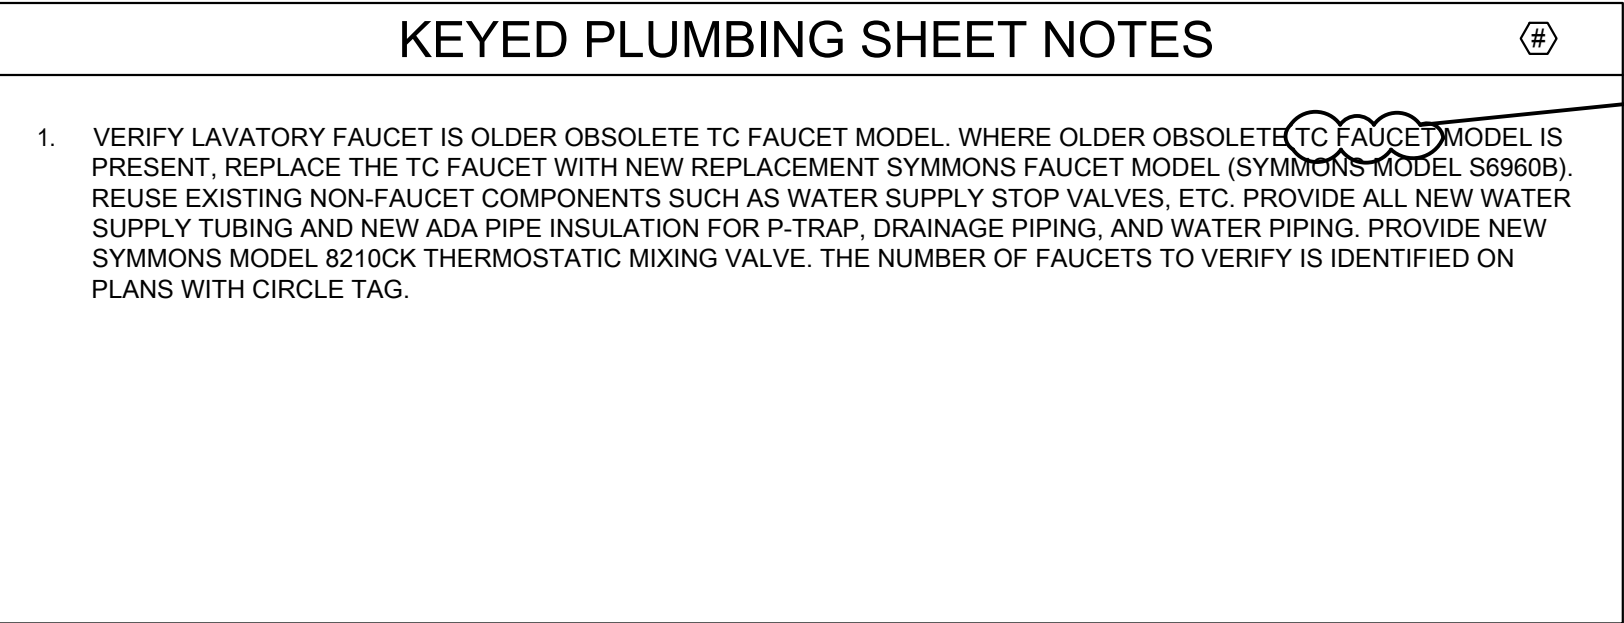[illegible]

ECT:
 GUARANTEED RATE FIELD -
 WASTE/VENT PIPING FY2026



735TH STREET,
CHICAGO, ILLINOIS 60616

CLIMBING PLAN - LEVEL 400 -
SECTION 5

DESIGNED BY:	CF
DRAWN BY:	MS
PROJECT NO:	25081
SCALE:	1/8" = 1'-0"

T NO.

P1.405

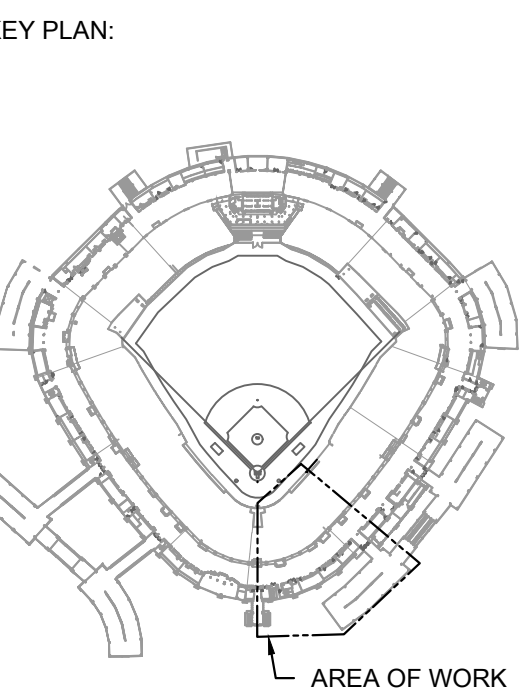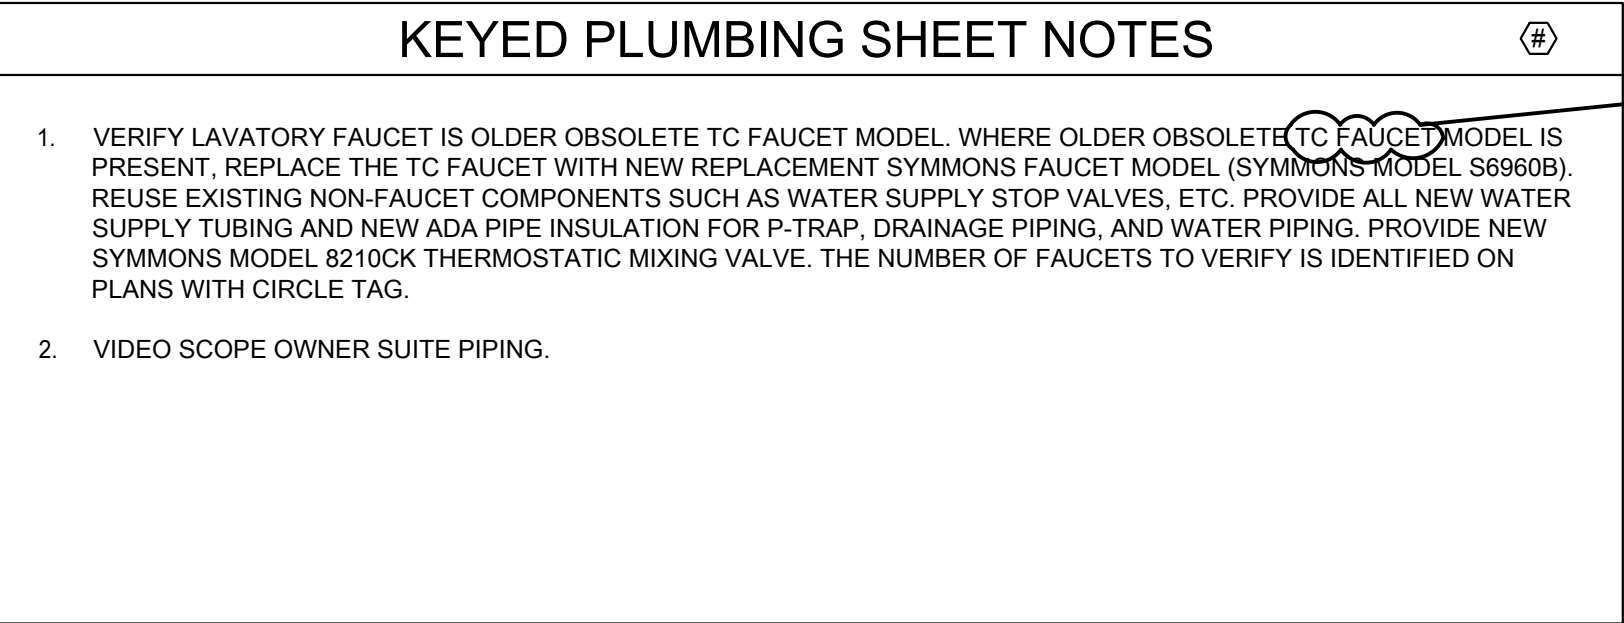[illegible]

PROJECT: GUARANTEED RATE FIELD - WASTE/VENT PIPING FY2026


33 W 35TH STREET,
CHICAGO, ILLINOIS 60616

DRAWING TITLE:
PLUMBING PLAN - LEVEL 400 -
SECTION 6

DESIGNED BY:	CF
CHECKED BY:	MS
PROJECT NO:	25081
SCALE:	1/8" = 1'-0"

SHEET NO.

P1.406

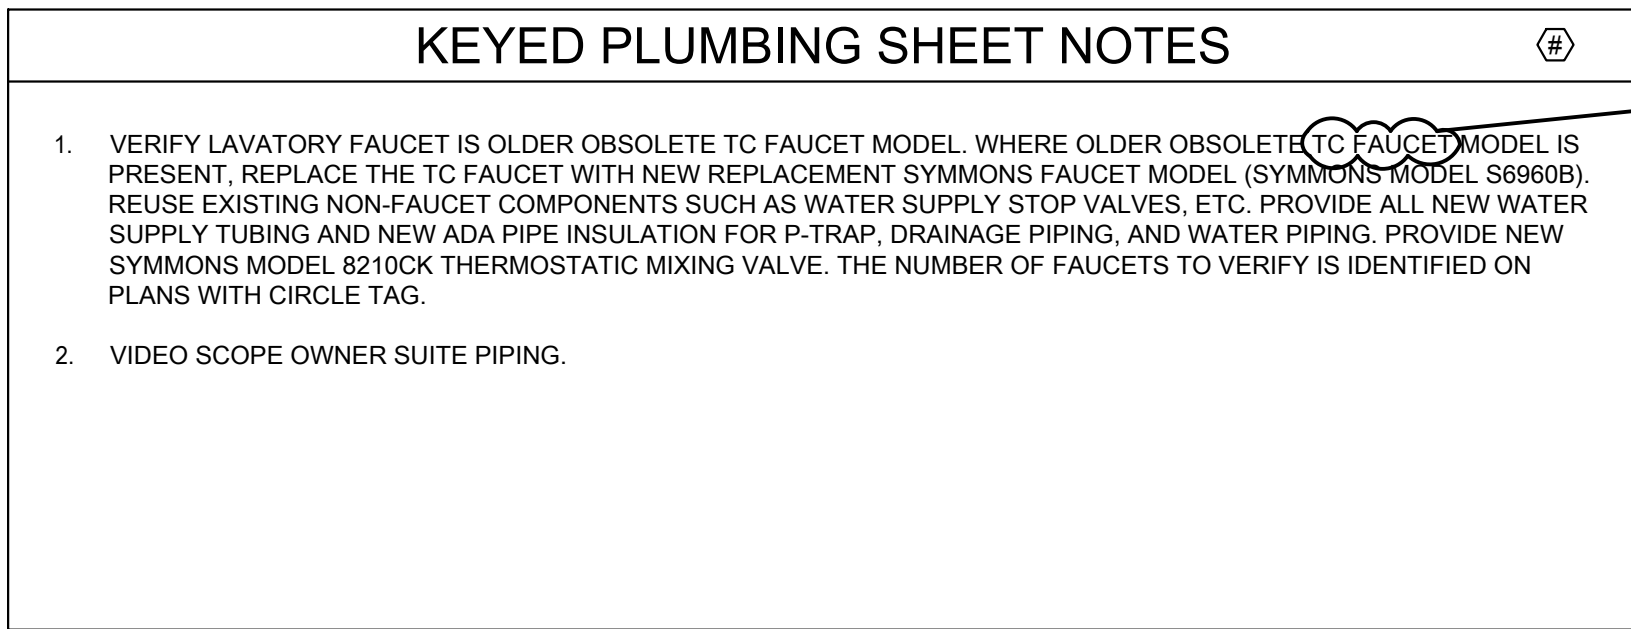




1 PLUMBING PLAN - 400 LEVEL - SECTION 8 ENLARGED

KEYED PLUMBING SHEET NOTES

1. VERIFY LAVATORY FAUCET IS OLDER OBSOLETE TC FAUCET MODEL WHERE OLDER OBSOLETE TC FAUCET MODEL IS PRESENT. REPLACE THE TC FAUCET WITH NEW REPLACEMENT SYMMONS FAUCET MODEL (SYMMONS MODEL 686906). REUSE EXISTING NON-FAUCET COMPONENTS SUCH AS WATER SUPPLY STOP VALVES, ETC. PROVIDE ALL NEW WATER SUPPLY TUBING AND NEW ADA PIPE INSULATION FOR P-TRAP, DRAINAGE PIPING, AND WATER PIPING. PROVIDE NEW SYMMONS MODEL 8210CK THERMOSTATIC MIXING VALVE. THE NUMBER OF FAUCETS TO VERIFY IS IDENTIFIED ON PLANS WITH CIRCLE TAG.

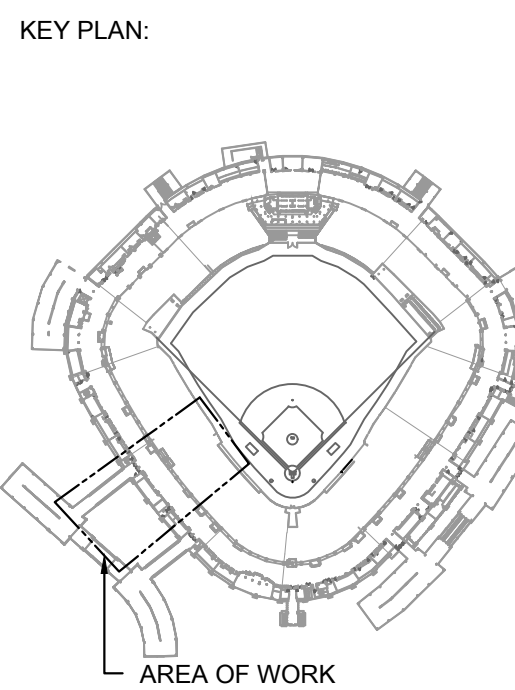

ISSUE/REVISION:		
REV.	DATE	DESCRIPTION
111426		ISSUE FOR BID
110909		ISSUE FOR ADDENDUM NO. 1

PROJECT:
GUARANTEED RATE FIELD -
WASTE/VENT PIPING FY2026

333 W 35TH STREET,
CHICAGO, ILLINOIS 60616

DRAWING TITLE:
PLUMBING PLAN - LEVEL 400 -
SECTION 8

DESIGNED BY: CF
CHECKED BY: MS
PROJECT NO: 25081
SCALE: 1/8" = 1'-0"

SHEET NO.
P1.408



KEYED PLUMBING SHEET NOTES

1.

VERIFY LAVATORY FAUCET IS OLDER OBSOLETE TO FAUCET MODEL. WHERE OLDER OBSOLETE TO FAUCET MODEL IS PRESENT, REPLACE THE TO FAUCET WITH NEW REPLACEMENT SYMMONS FAUCET MODEL (SYMMONS MODEL S89608). REUSE EXISTING NON-FAUCET COMPONENTS SUCH AS WATER SUPPLY STOP VALVES, ETC. PROVIDE ALL NEW WATER SUPPLY TUBING AND NEW ADA PIPE INSULATION FOR P-TRAP, DRAINAGE PIPING, AND WATER PIPING. PROVIDE NEW SYMMONS MODEL 8210CK THERMOSTATIC MIXING VALVE. THE NUMBER OF FAUCETS TO VERIFY IS IDENTIFIED ON PLANS WITH CIRCLE TAG.

1 PLUMBING PLAN - 400 LEVEL - SECTION 9 ENLARGED

SCALE: 1/8" = 1'-0"

0 4 8 16

North Arrow




elaraeng.com | (708) 236-0300



ISFA
ILLINOIS SPORTS
FACILITIES AUTHORITY



KEY PLAN:

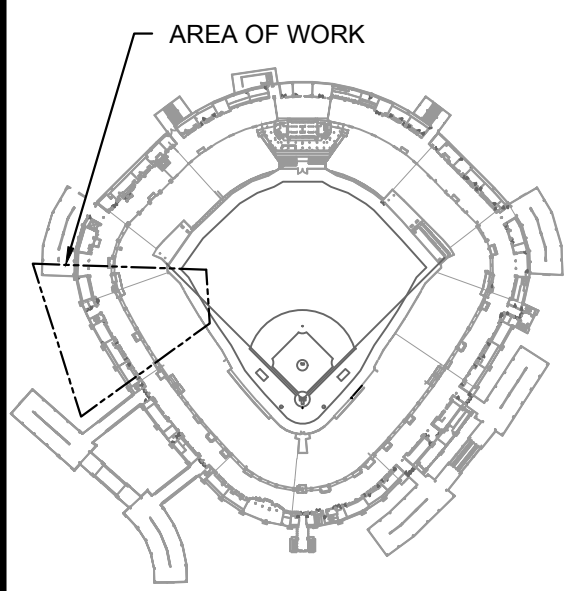

ISSUE/REVISION:

REV.	DATE	DESCRIPTION
1111425		ISSUE FOR BID
1109025		ISSUE FOR ADDENDUM NO. 1

PROJECT:

GUARANTEED RATE FIELD -
WASTE/VENT PIPING FY2026

333 W 35TH STREET,
CHICAGO, ILLINOIS 60616

DRAWING TITLE:

PLUMBING PLAN - LEVEL 400 -
SECTION 9

DESIGNED BY:

CF

CHECKED BY:

MS

PROJECT NO.:


25081

SCALE:

1/8" = 1'-0"

SHEET NO.


P1.409

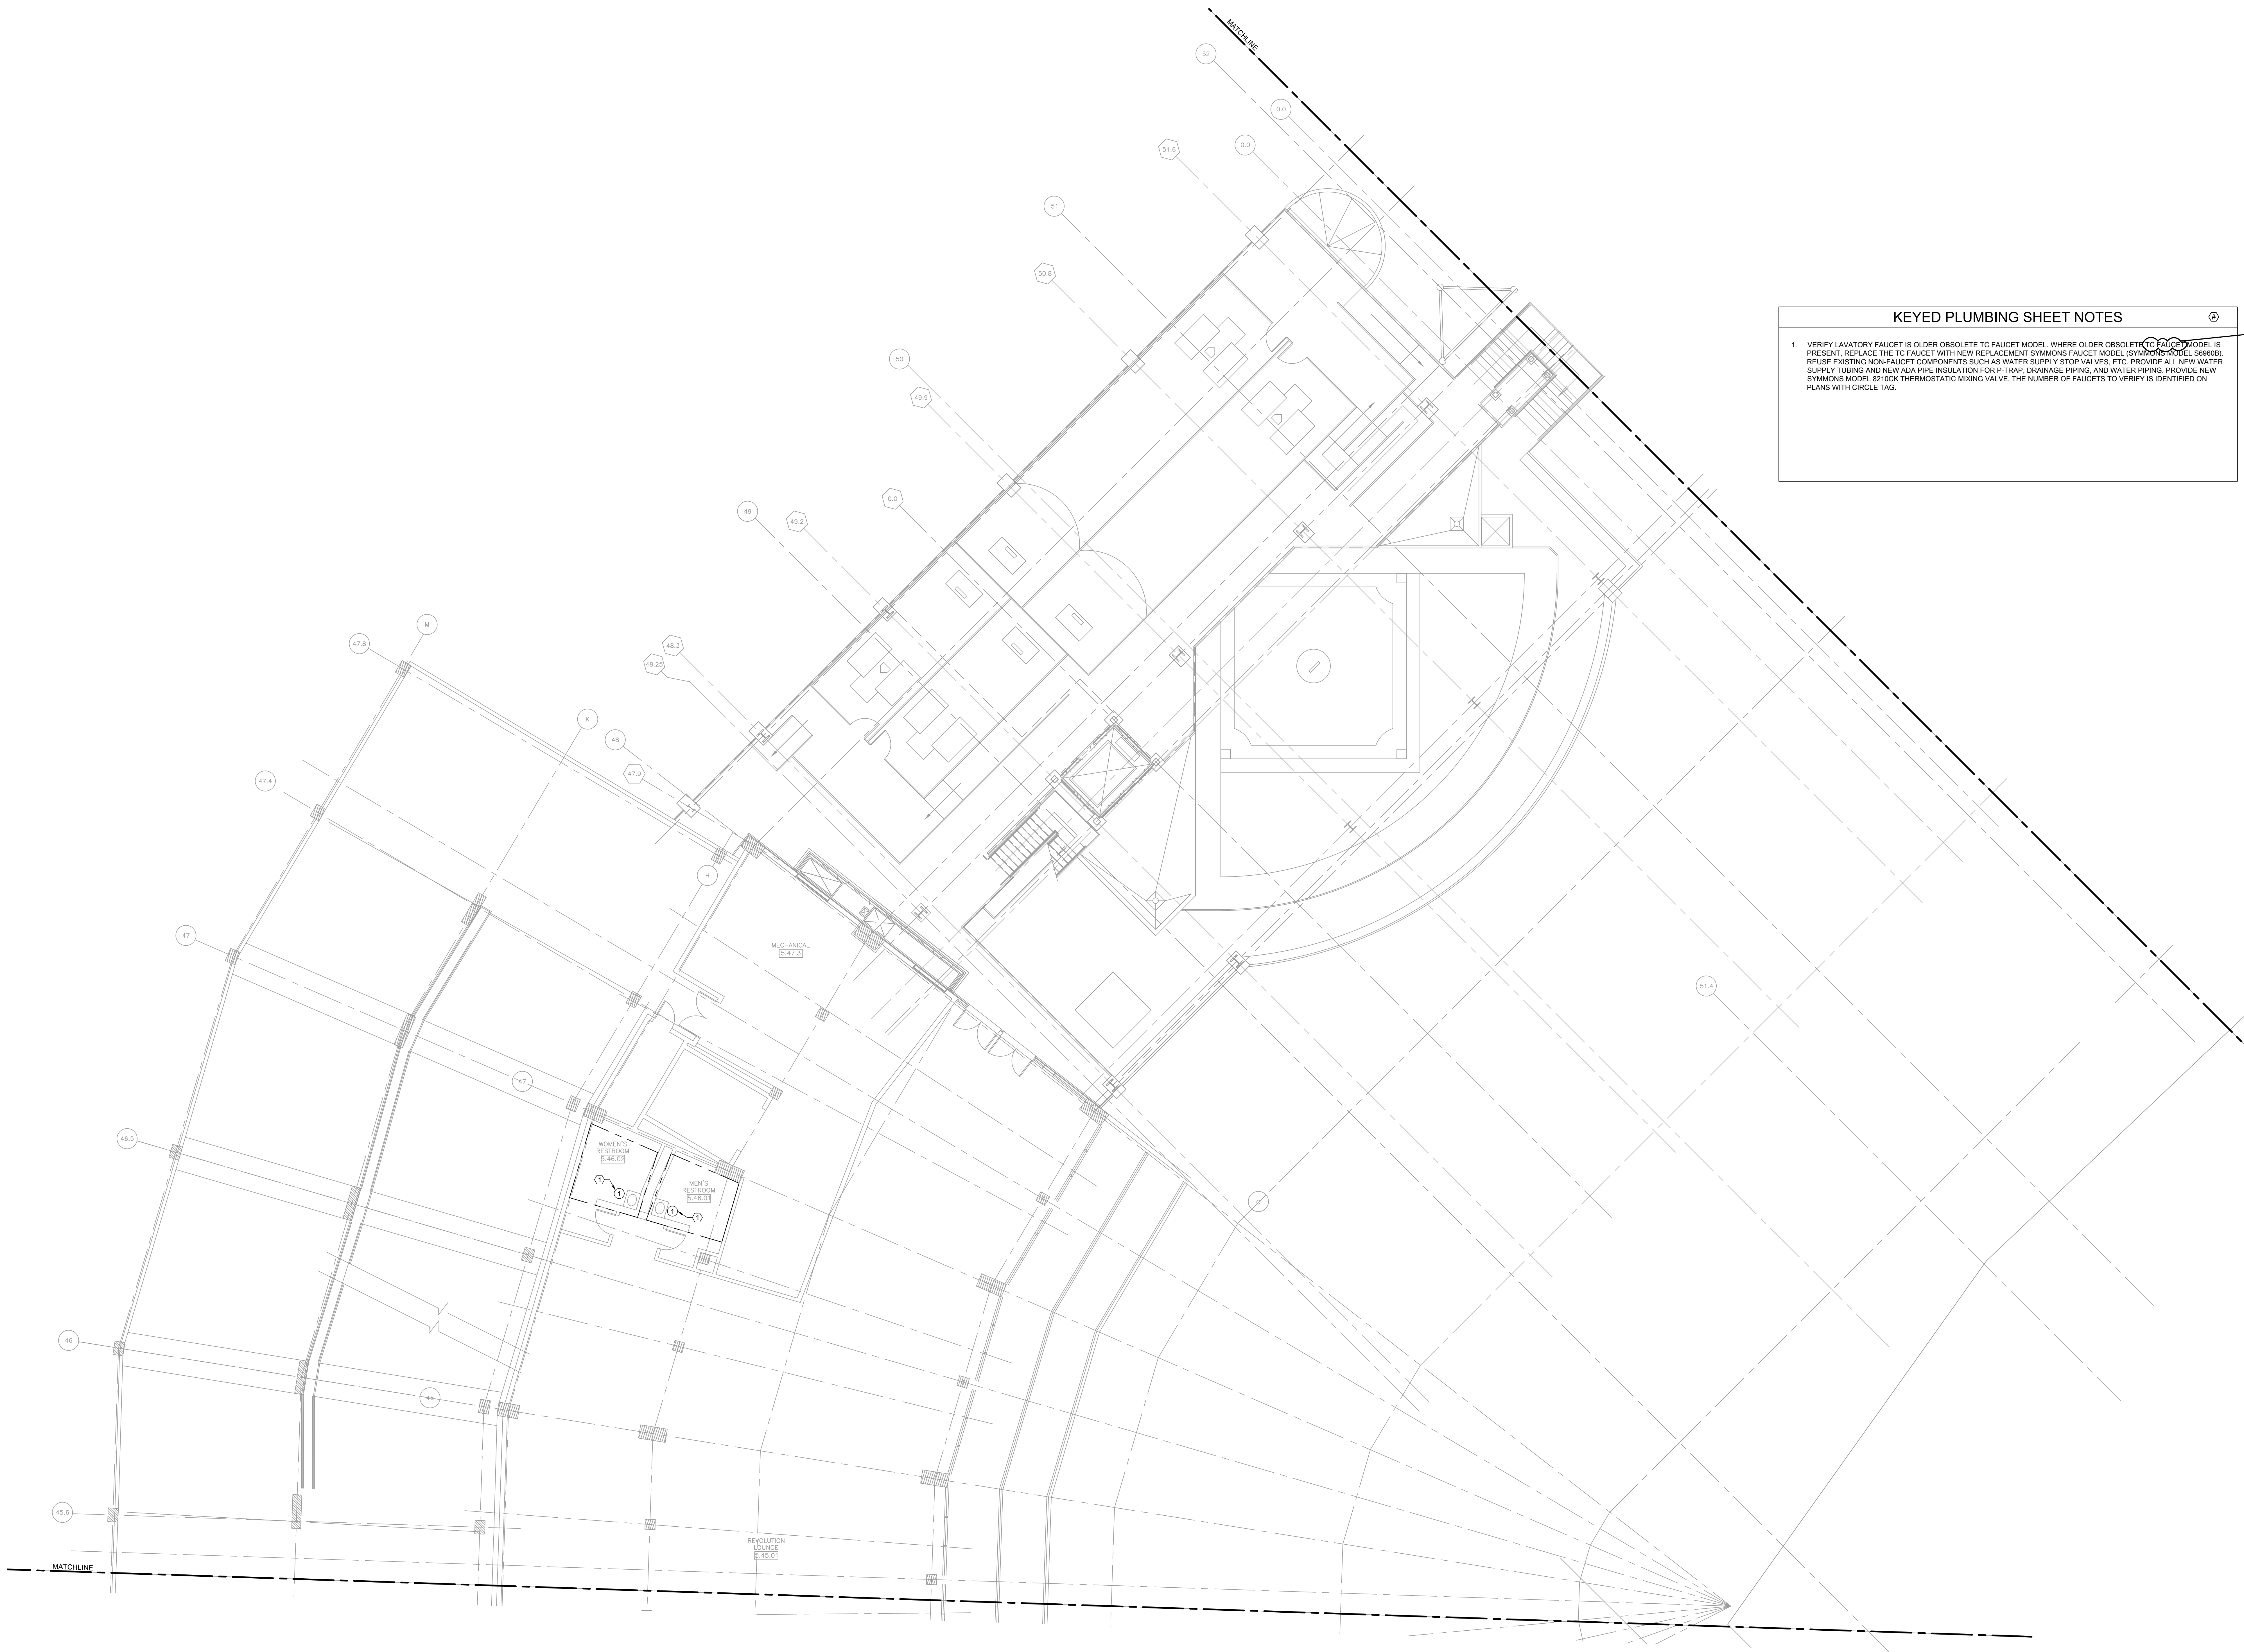

KEYED PLUMBING SHEET NOTES

1. VERIFY LAVATORY FAUCET IS OLDER OBSOLETE TC FAUCET MODEL. WHERE OLDER OBSOLETE TC FAUCET MODEL IS PRESENT, REPLACE THE TC FAUCET WITH NEW REPLACEMENT SYMMONS FAUCET MODEL (SYMMONS MODEL 569608). REUSE EXISTING NON-FAUCET COMPONENTS SUCH AS WATER SUPPLY STOP VALVES, ETC. PROVIDE ALL NEW WATER SUPPLY TUBING AND NEW ADA PIPE INSULATION FOR P-TRAP. DRAINAGE PIPING, AND WATER PIPING. PROVIDE NEW SYMMONS MODEL 52100A THERMOSTATIC MIXING VALVE. THE NUMBER OF FAUCETS TO VERIFY IS IDENTIFIED ON PLANS WITH CIRCLE TAG.

1 PLUMBING PLAN - 400 LEVEL - SECTION 10 ENLARGED

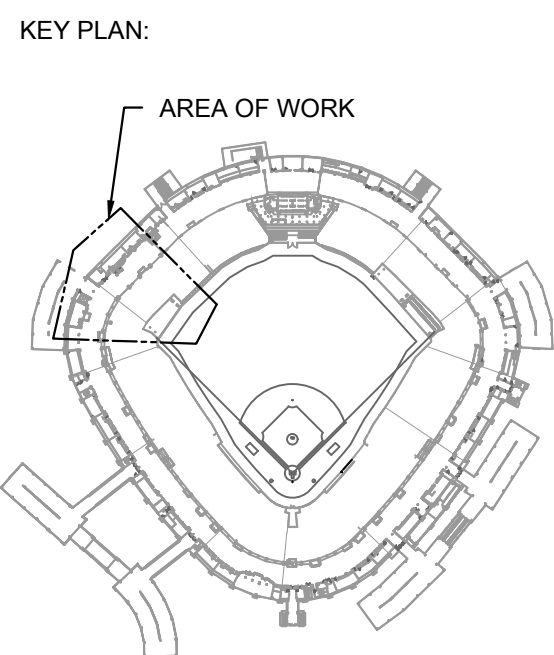

ISSUE/REVISION:		
REV.	DATE	DESCRIPTION
111425		ISSUE FOR BID
110925		ISSUE FOR ADDENDUM NO. 1


PROJECT:
GUARANTEED RATE FIELD -
WASTE/VENT PIPING FY2026

333 W 35TH STREET,
CHICAGO, ILLINOIS 60616

DRAWING TITLE:
PLUMBING PLAN - LEVEL 400 -
SECTION 10

DESIGNED BY: CF
CHECKED BY: MS
PROJECT NO: 25081
SCALE: 1/8" = 1'-0"

SHEET NO.
P1.410

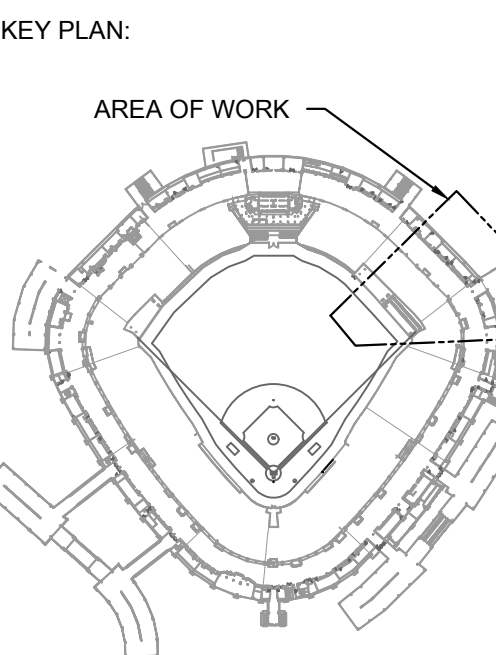

ISSUE/REVISION:		
REV.	DATE	DESCRIPTION
1	11/14/25	ISSUE FOR BID
2	11/09/25	ISSUE FOR ADDENDUM NO. 1

PROJECT:
GUARANTEED RATE FIELD -
WASTE/VENT PIPING FY2026

333 W 35TH STREET,
CHICAGO, ILLINOIS 60616


DRAWING TITLE:
PLUMBING PLAN - LEVEL 500 -
SECTION 3

DESIGNED BY: CF
CHECKED BY: MS
PROJECT NO: 25081
SCALE: 1/8" = 1'-0"

SHEET NO.
P1.503

KEYED PLUMBING SHEET NOTES

1. VERIFY LAVATORY FAUCET IS OLDER OBSOLETE TC FAUCET MODEL. WHERE OLDER OBSOLETE TC FAUCET MODEL IS PRESENT, REPLACE THE TC FAUCET WITH NEW REPLACEMENT SYMMONS FAUCET MODEL (SYMMONS MODEL S6400B). REUSE EXISTING NON-FAUCET COMPONENTS SUCH AS WATER SUPPLY STOP VALVES, ETC. PROVIDE ALL NEW WATER SUPPLY TUBING AND NEW ADA PIPE INSULATION FOR P-TRAP, DRAINAGE PIPING, AND WATER PIPING. PROVIDE NEW SYMMONS MODEL 6210CK THERMOSTATIC MIXING VALVE. THE NUMBER OF FAUCETS TO VERIFY IS IDENTIFIED ON PLANS WITH CIRCLE TAG.

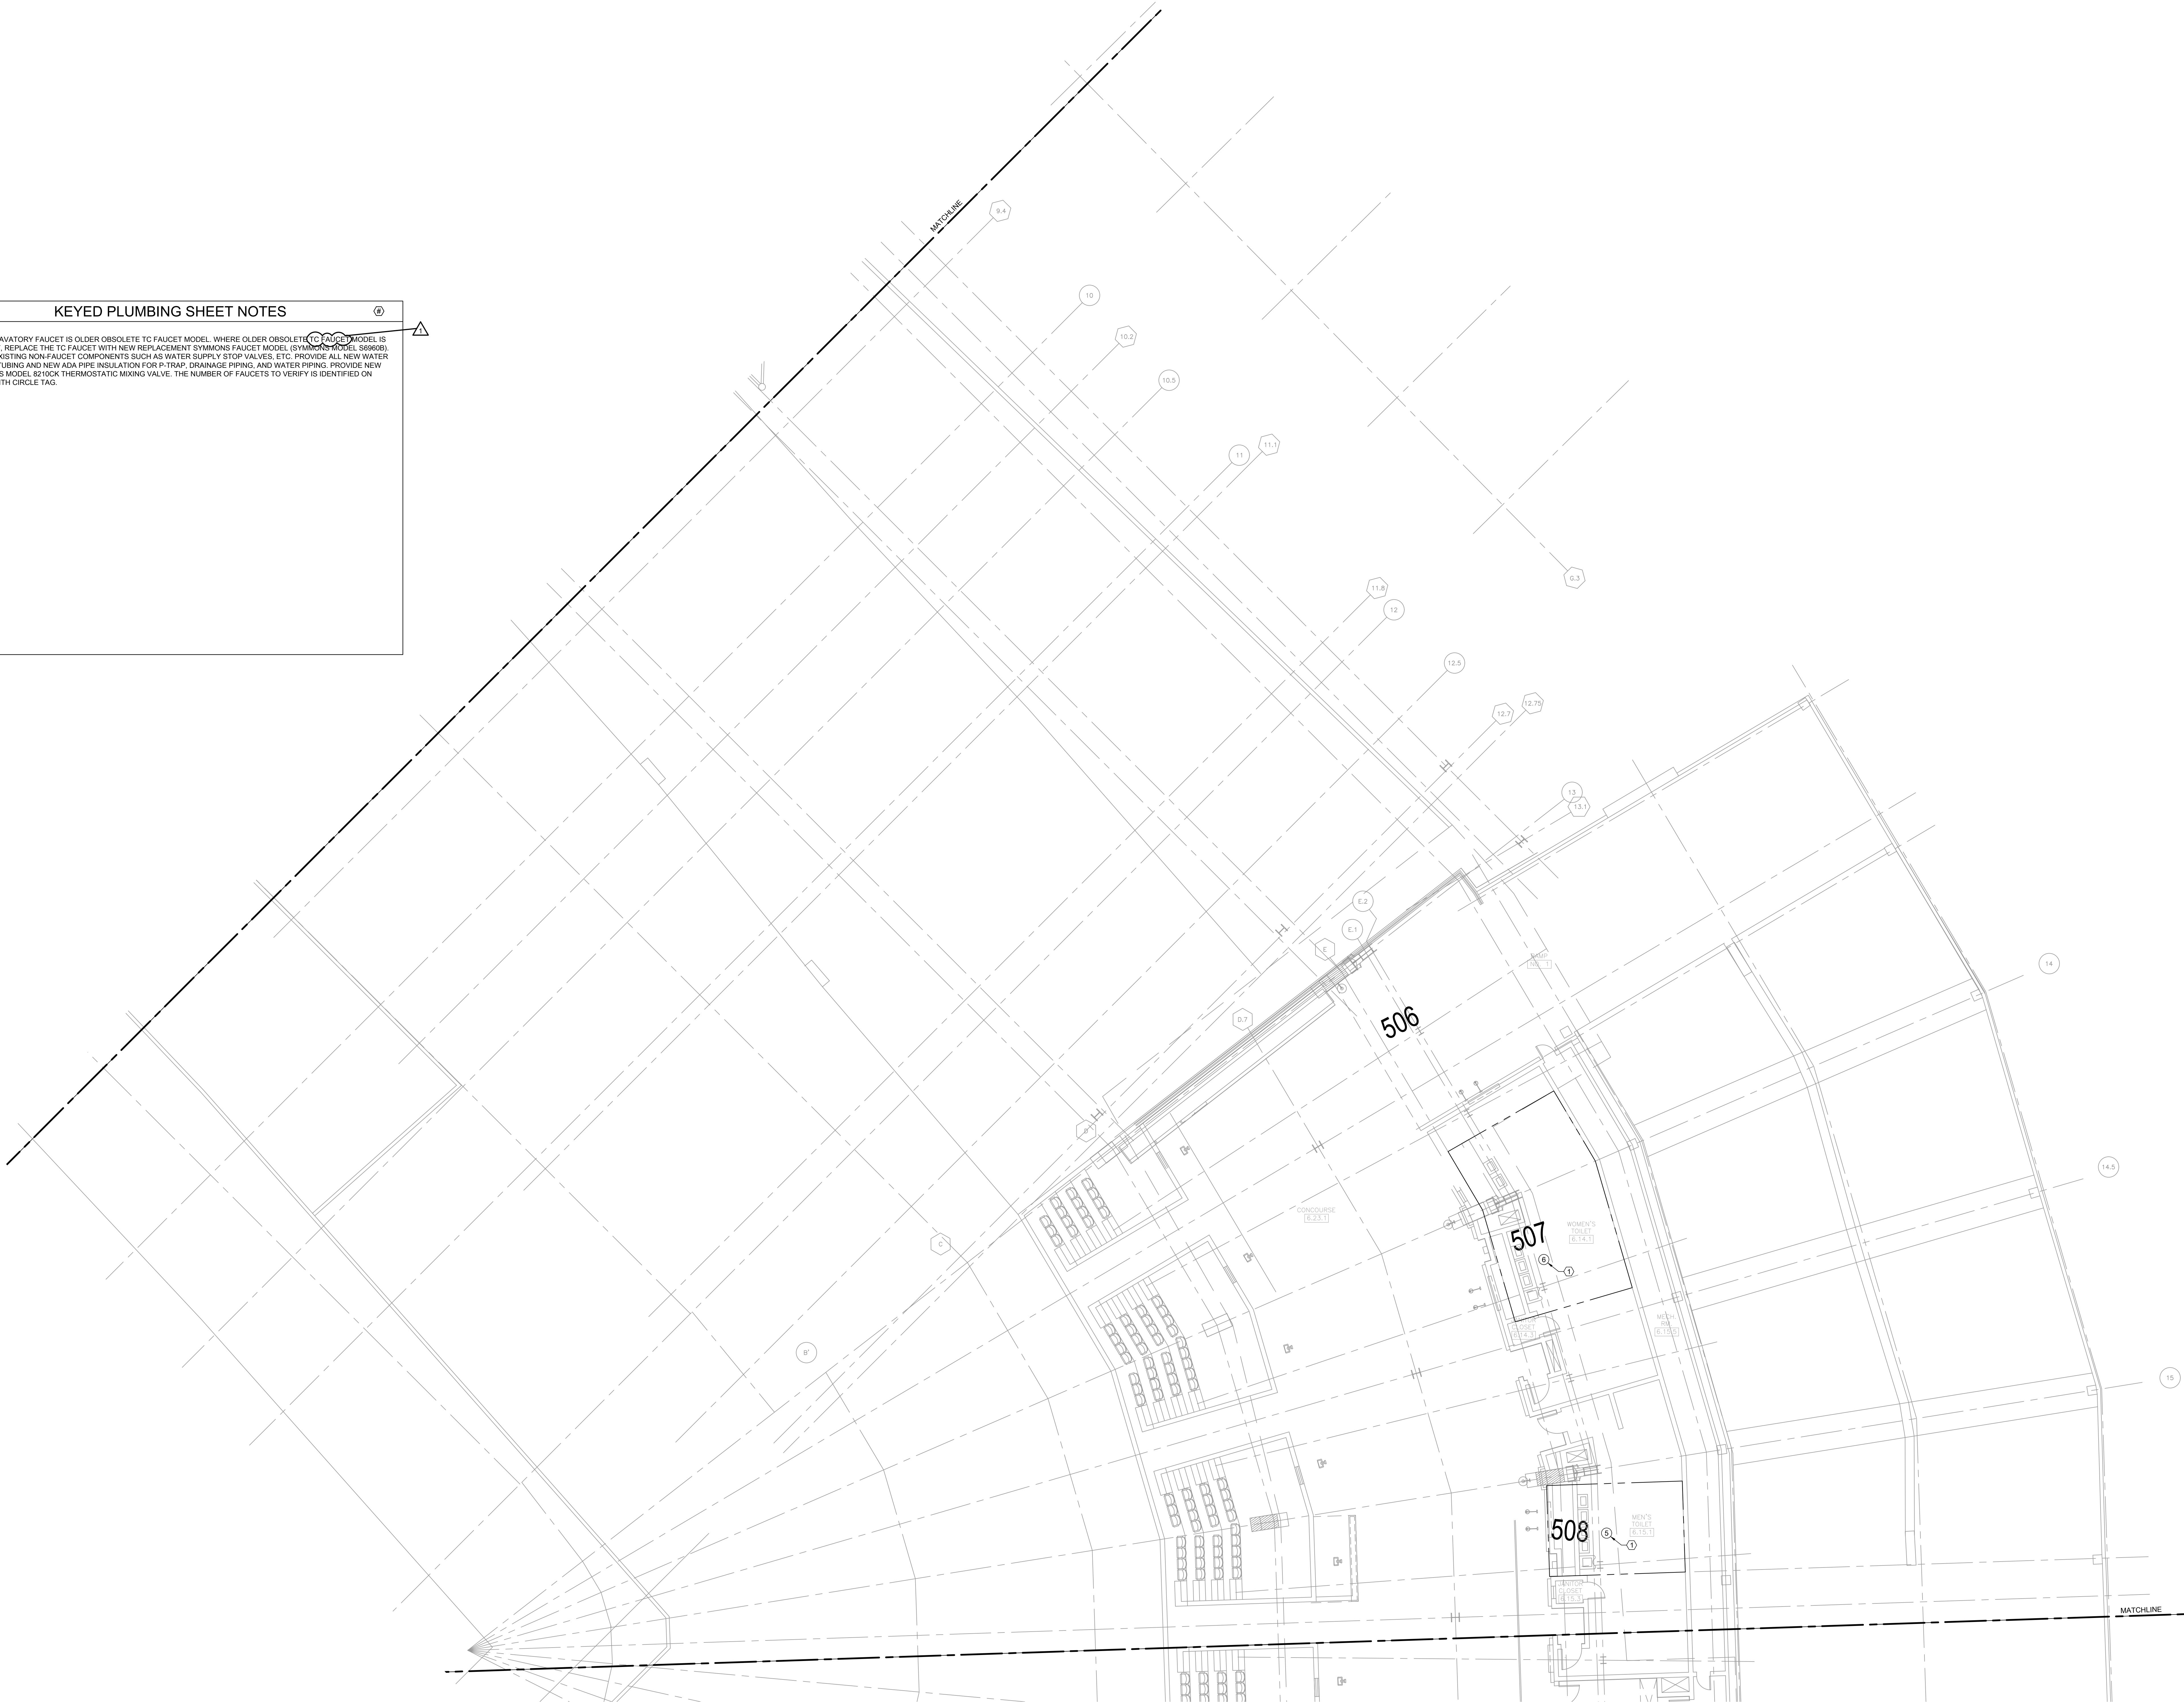

1 PLUMBING PLAN - 500 LEVEL - SECTION 3 ENLARGED

SCALE: 1/8" = 1'-0"


0 2 4 8 16



KEYED PLUMBING SHEET NOTES

1. VERIFY LAVATORY FAUCET IS OLDER OBSOLETE TC FAUCET MODEL, WHERE OLDER OBSOLETE TC FAUCET MODEL IS PRESENT, REPLACE THE TC FAUCET WITH NEW REPLACEMENT SYMMONS FAUCET MODEL (SYMMONS MODEL S6900B). REUSE EXISTING NON-FAUCET COMPONENTS SUCH AS WATER SUPPLY STOP VALVES, ETC. PROVIDE ALL NEW WATER SUPPLY TUBING AND NEW ADA PIPE INSULATION FOR P-TRAP, DRAINAGE PIPING, AND WATER PIPING. PROVIDE NEW SYMMONS MODEL 8210CK THERMOSTATIC MIXING VALVE. THE NUMBER OF FAUCETS TO VERIFY IS IDENTIFIED ON PLANS WITH CIRCLE TAG.

1 PLUMBING PLAN - 500 LEVEL - SECTION 4 ENLARGED

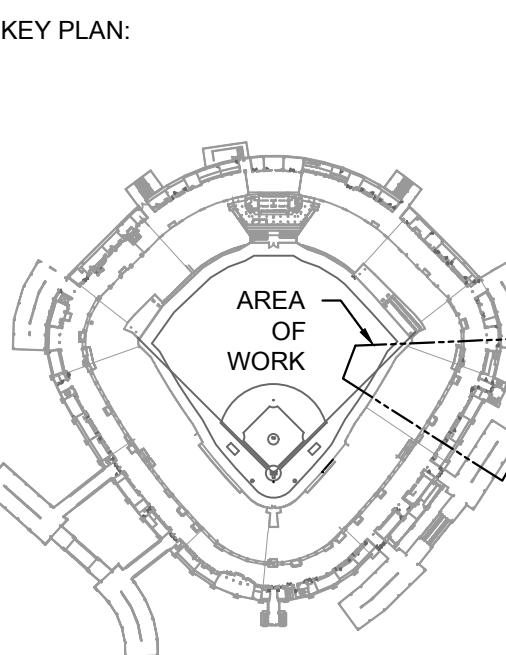

ISSUE/REVISION:		
REV.	DATE	DESCRIPTION
1	11/14/25	ISSUE FOR BID
2	11/09/25	ISSUE FOR ADDENDUM NO. 1

PROJECT:
GUARANTEED RATE FIELD -
WASTE/VENT PIPING FY2026

333 W 35TH STREET,
CHICAGO, ILLINOIS 60616

DRAWING TITLE:
PLUMBING PLAN - LEVEL 500 -
SECTION 4

DESIGNED BY:	CF
CHECKED BY:	MS
PROJECT NO:	25081
SCALE:	1/8" = 1'-0"

SHEET NO.
P1.504


KEYED PLUMBING SHEET NOTES

1. VERIFY LAVATORY FAUCET IS OLDER OBSOLETE TC FAUCET MODEL. WHERE OLDER OBSOLETE TC FAUCET MODEL IS PRESENT, REPLACE THE TC FAUCET WITH NEW REPLACEMENT SYMMONS FAUCET MODEL (SYMMONS MODEL S99088). REUSE EXISTING NON FAUCET COMPONENTS SUCH AS WATER SUPPLY STOP VALVES, ETC. PROVIDE ALL NEW WATER SUPPLY TUBING AND NEW ADA PIPE INSULATION FOR P-TRAP, DRAINAGE PIPING, AND WATER PIPING. PROVIDE NEW SYMMONS MODEL 82 LOCK THERMOSTATIC MIXING VALVE. THE NUMBER OF FAUCETS TO VERIFY IS IDENTIFIED ON PLANS WITH CIRCLE TAG.

1 PLUMBING PLAN - 500 LEVEL - SECTION 5 ENLARGED

SCALE: 1/8" = 1'-0"

KEY PLAN:

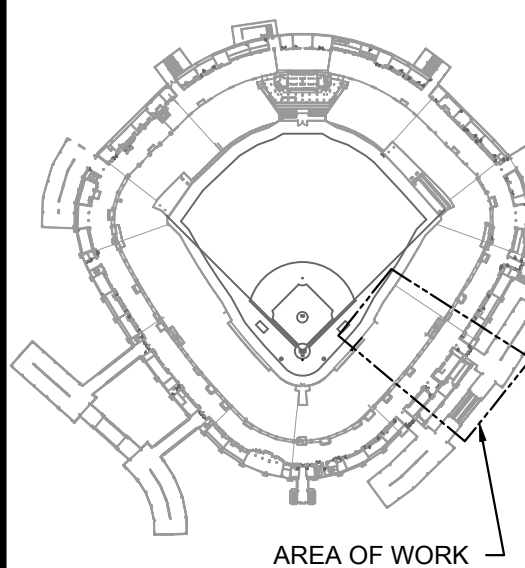

ISSUE/REVISION:

REV.	DATE	DESCRIPTION
111425		ISSUE FOR BID
110925		ISSUE FOR ADDENDUM NO. 1

PROJECT:

GUARANTEED RATE FIELD -
WASTE/VENT PIPING FY2026

333 W 35TH STREET,
CHICAGO, ILLINOIS 60616



DRAWING TITLE:

PLUMBING PLAN - LEVEL 500 -
SECTION 5

DESIGNED BY: CF
CHECKED BY: MS
PROJECT NO: 25081
SCALE: 1/8" = 1'-0"

SHEET NO.

P1.505

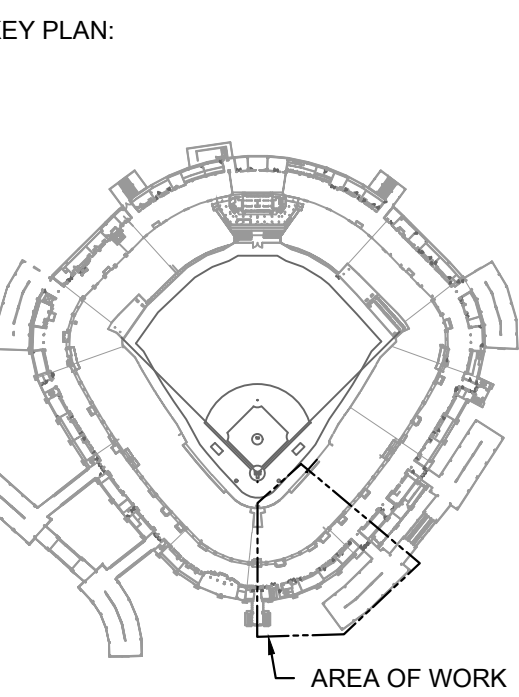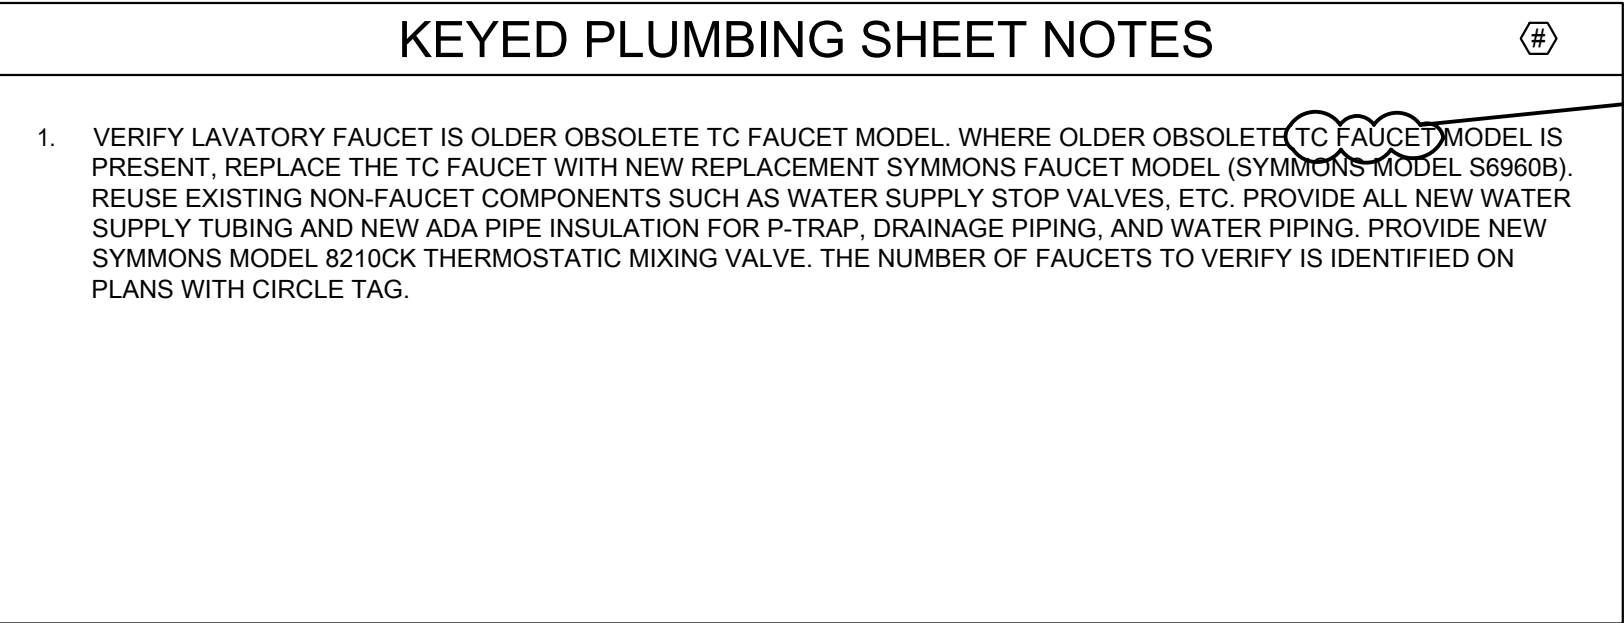

ISSUE/REVISION:		
REV.	DATE	DESCRIPTION
1	11/14/25	ISSUE FOR BID
	11/09/25	ISSUE FOR ADDENDUM NO. 1

PROJECT:
GUARANTEED RATE FIELD -
WASTE/VENT PIPING FY2026


333 W 35TH STREET,
CHICAGO, ILLINOIS 60616

DRAWING TITLE:
PLUMBING PLAN - LEVEL 500 -
SECTION 6

DESIGNED BY:	CF
CHECKED BY:	MS
PROJECT NO:	25081
SCALE:	1/8" = 1'-0"

SHEET NO. _____

P1.506

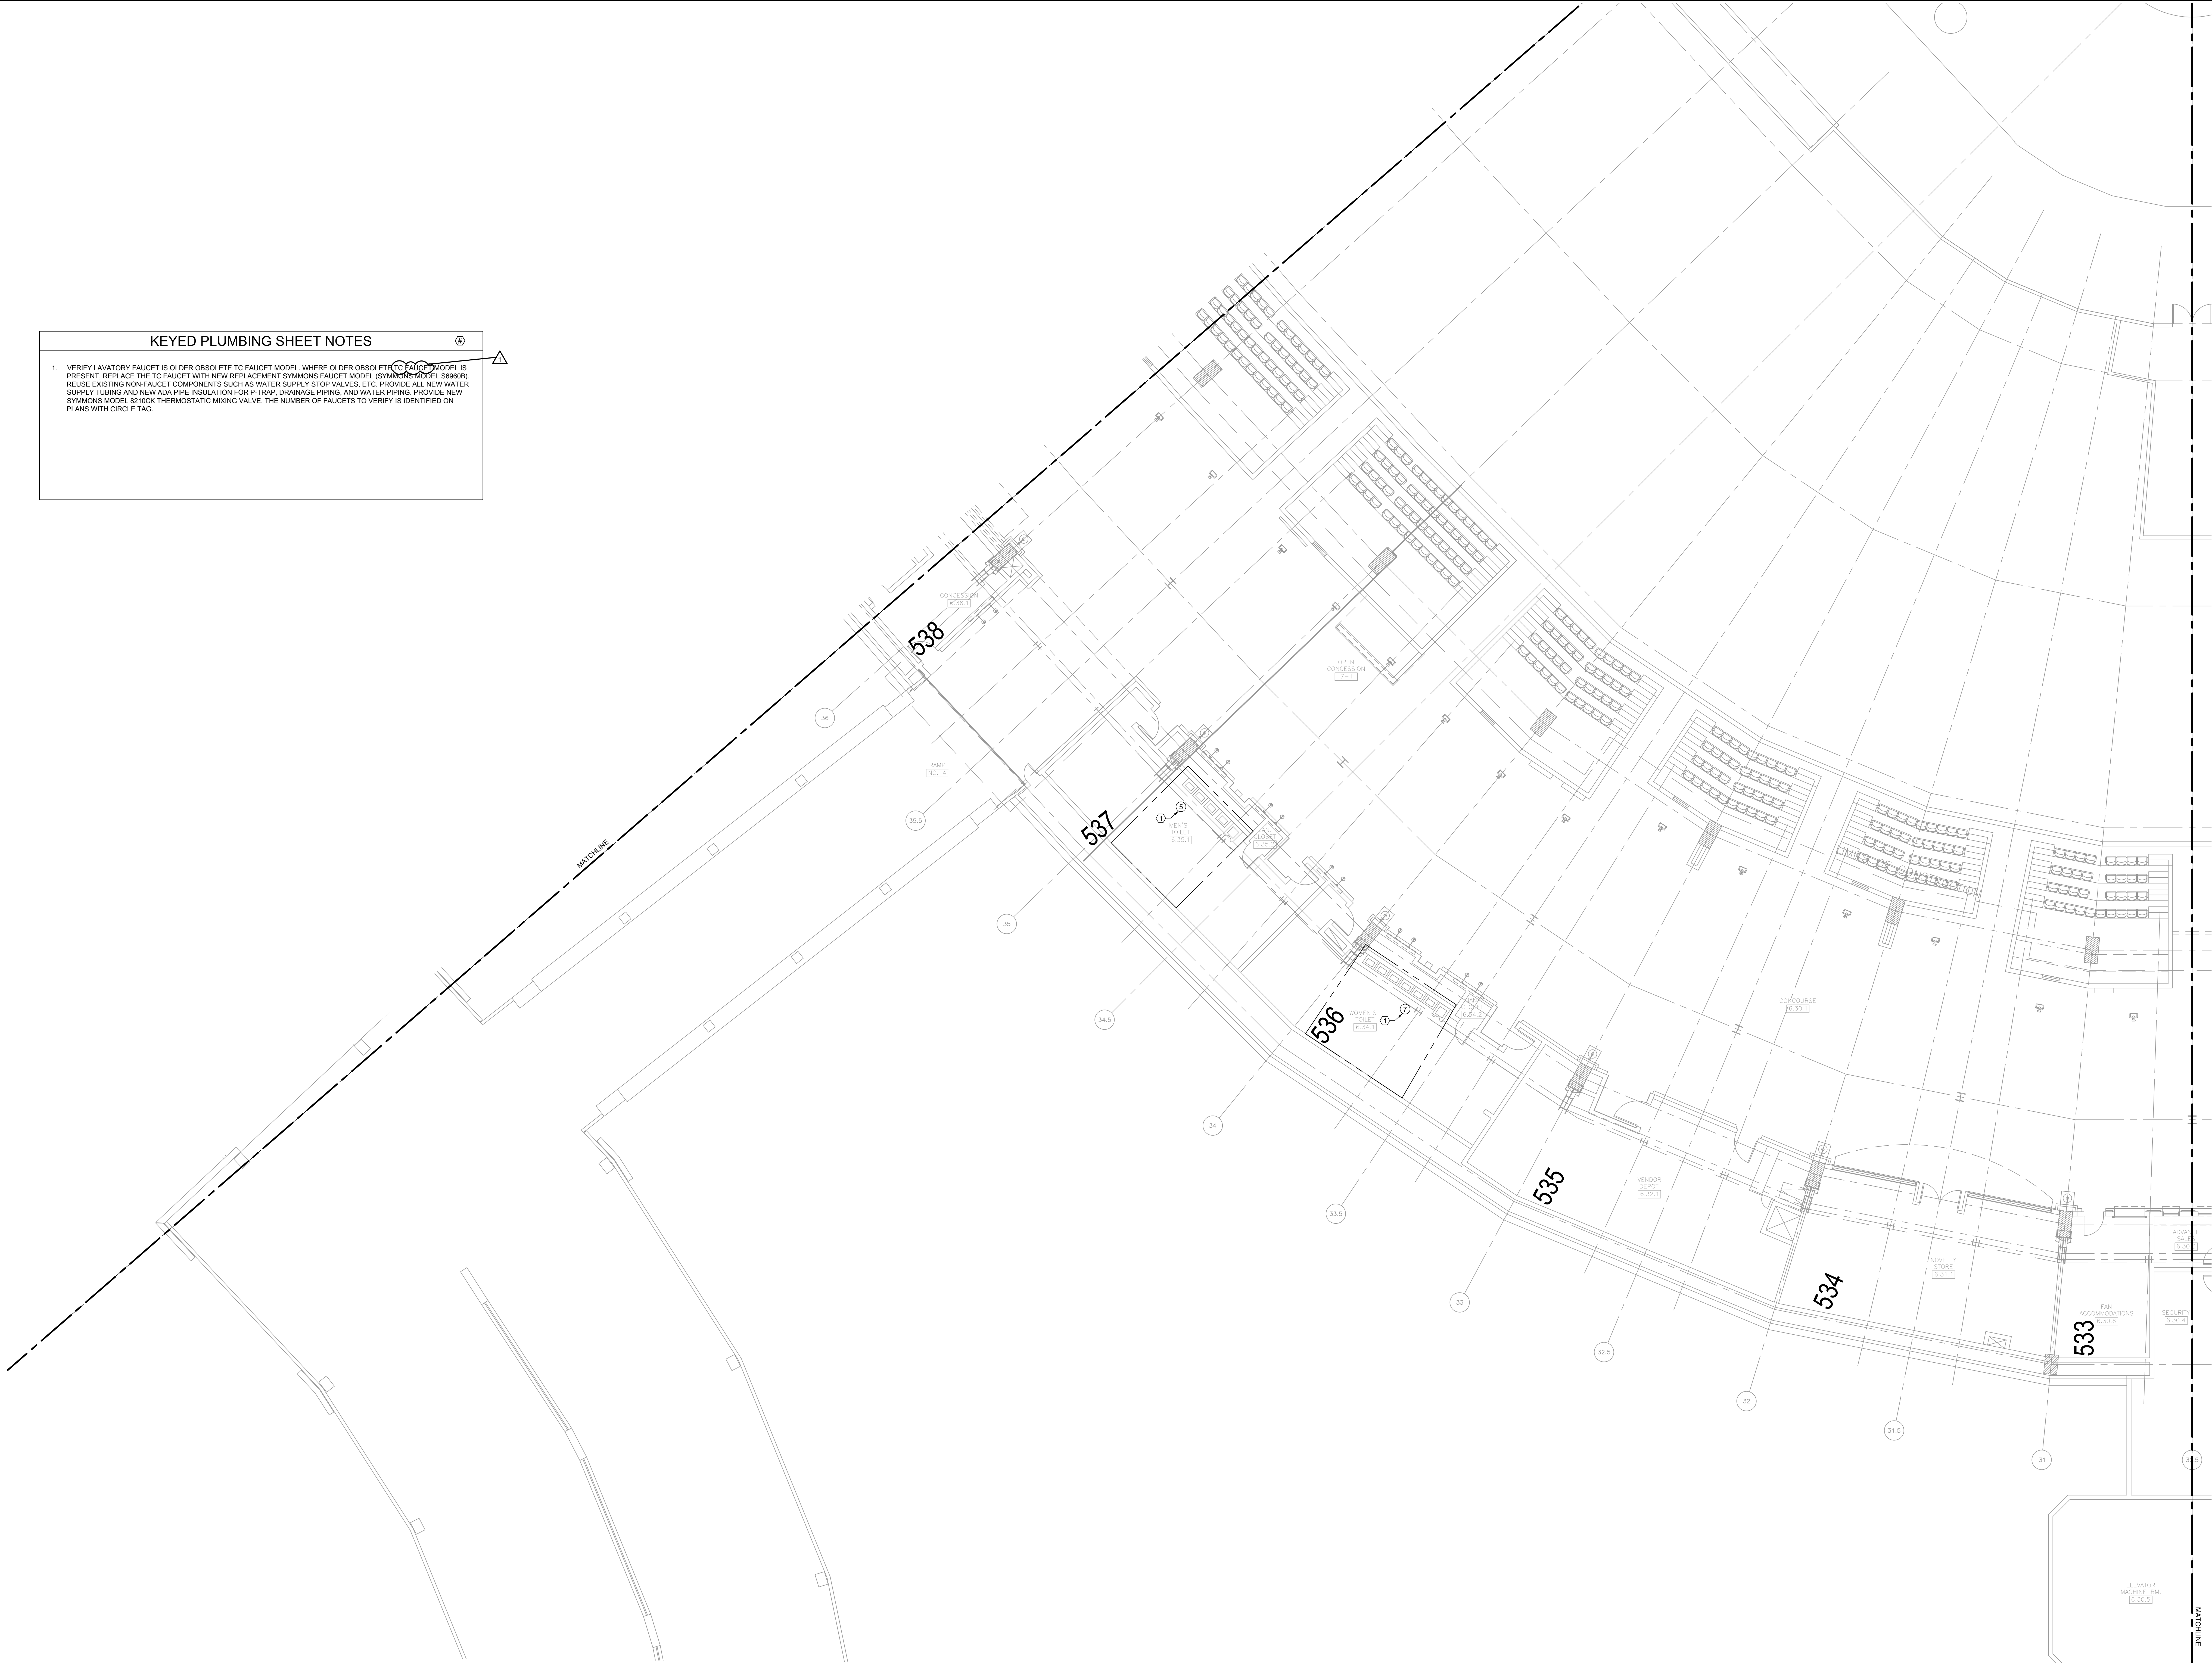

KEYED PLUMBING SHEET NOTES

1. VERIFY LAVATORY FAUCET IS OLDER OBSOLETE TO FAUCET MODEL, WHERE OLDER OBSOLETE TO FAUCET MODEL IS PRESENT, REPLACE THE TO FAUCET WITH NEW REPLACEMENT SYMMONS FAUCET MODEL (SYMMONS MODEL S6960B). REUSE EXISTING NON-FAUCET COMPONENTS SUCH AS WATER SUPPLY STOP VALVES, ETC. PROVIDE ALL NEW WATER SUPPLY TUBING AND NEW ADA PIPE INSULATION FOR P-TRAP, DRAINAGE PIPING, AND WATER PIPING. PROVIDE NEW SYMMONS MODEL 8210CK THERMOSTATIC MIXING VALVE. THE NUMBER OF FAUCETS TO VERIFY IS IDENTIFIED ON PLANS WITH CIRCLE TAG.

1 PLUMBING PLAN - 500 LEVEL - SECTION 7 ENLARGED




elaraeng.com | (708) 236-0300



INLAND SPOKES
FACILITIES AUTHORITY

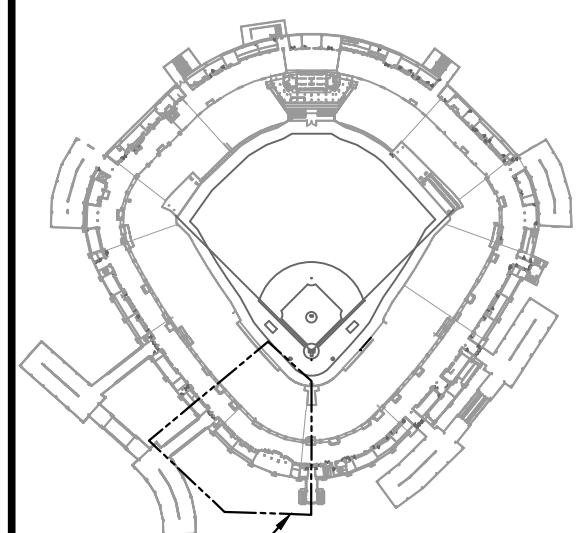

KEY PLAN:


AREA OF WORK:
ISSUE/REVISION:

REV.	DATE	DESCRIPTION
111425		ISSUE FOR BID
110925		ISSUE FOR ADDENDUM NO. 1

PROJECT:
GUARANTEED RATE FIELD -
WASTE/VENT PIPING FY2026

333 W 35TH STREET,
CHICAGO, ILLINOIS 60616

DRAWING TITLE:
PLUMBING PLAN - LEVEL 500 -
SECTION 7

DESIGNED BY: CF
CHECKED BY: MS
PROJECT NO: 25081
SCALE: 1/8" = 1'-0"
SHEET NO.

P1.507




KEYED PLUMBING SHEET NOTES

1

VERIFY LAVATORY FAUCET IS OLDER OBSOLETE TC FAUCET MODEL WHERE OLDER OBSOLETE TC FAUCET MODEL IS PRESENT. REPLACE THE TC FAUCET WITH NEW REPLACEMENT SYMMONS FAUCET MODEL (SYMMONS MODEL 588906). REUSE EXISTING NON-FAUCET COMPONENTS SUCH AS WATER SUPPLY STOP VALVES, ETC. PROVIDE ALL NEW WATER SUPPLY TUBING AND NEW ADA PIPE INSULATION FOR P-TRAP, DRAINAGE PIPING, AND WATER PIPING. PROVIDE NEW SYMMONS MODEL 8210CK THERMOSTATIC MIXING VALVE. THE NUMBER OF FAUCETS TO VERIFY IS IDENTIFIED ON PLANS WITH CIRCLE TAG.

1 PLUMBING PLAN - 500 LEVEL - SECTION 8 ENLARGED

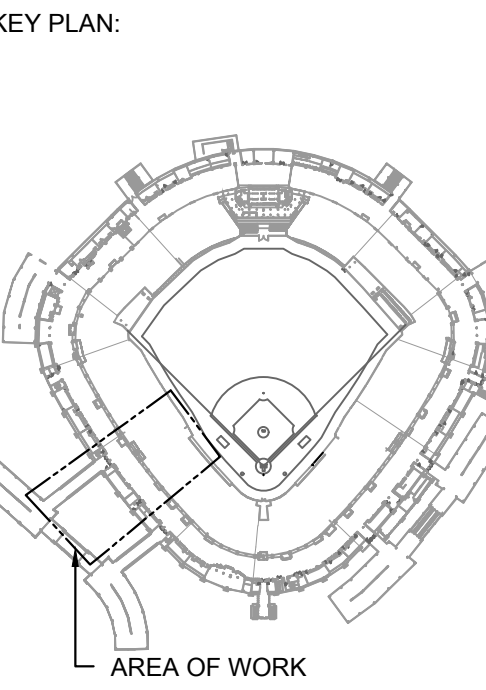

ISSUE/REVISION:		
REV.	DATE	DESCRIPTION
111425		ISSUE FOR BID
110925		ISSUE FOR ADDENDUM NO. 1


PROJECT:
GUARANTEED RATE FIELD -
WASTE/VENT PIPING FY2026

333 W 35TH STREET,
CHICAGO, ILLINOIS 60616

DRAWING TITLE:
PLUMBING PLAN - LEVEL 500 -
SECTION 8

DESIGNED BY: CF
CHECKED BY: MS
PROJECT NO: 25081
SCALE: 1/8" = 1'-0"

SHEET NO.
P1.508

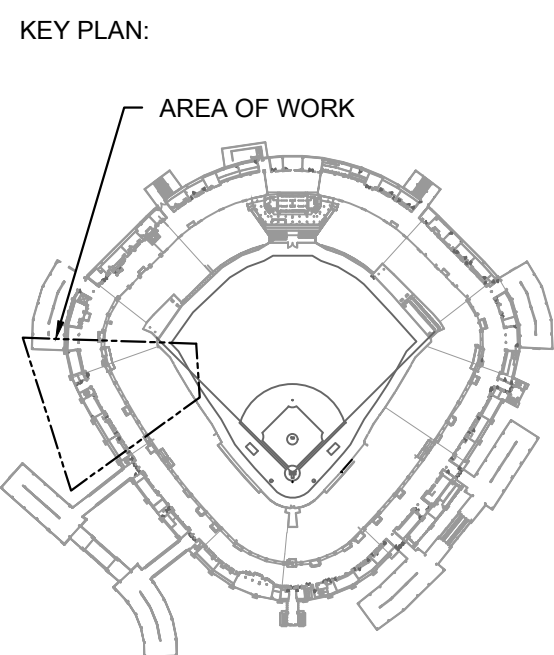

ISSUE/REVISION:		
REV.	DATE	DESCRIPTION
1	11/14/25	ISSUE FOR BID
2	11/09/25	ISSUE FOR ADDENDUM NO. 1

PROJECT:
GUARANTEED RATE FIELD -
WASTE/VENT PIPING FY2026

333 W 35TH STREET,
CHICAGO, ILLINOIS 60616

DRAWING TITLE:
PLUMBING PLAN - LEVEL 500 -
SECTION 9

 
DESIGNED BY: CF
CHECKED BY: MS
PROJECT NO: 25081
SCALE: 1/8" = 1'-0"


SHEET NO.

P1.509

1 PLUMBING PLAN - 500 LEVEL - SECTION 9 ENLARGED

SCALE: 1/8" = 1'-0"



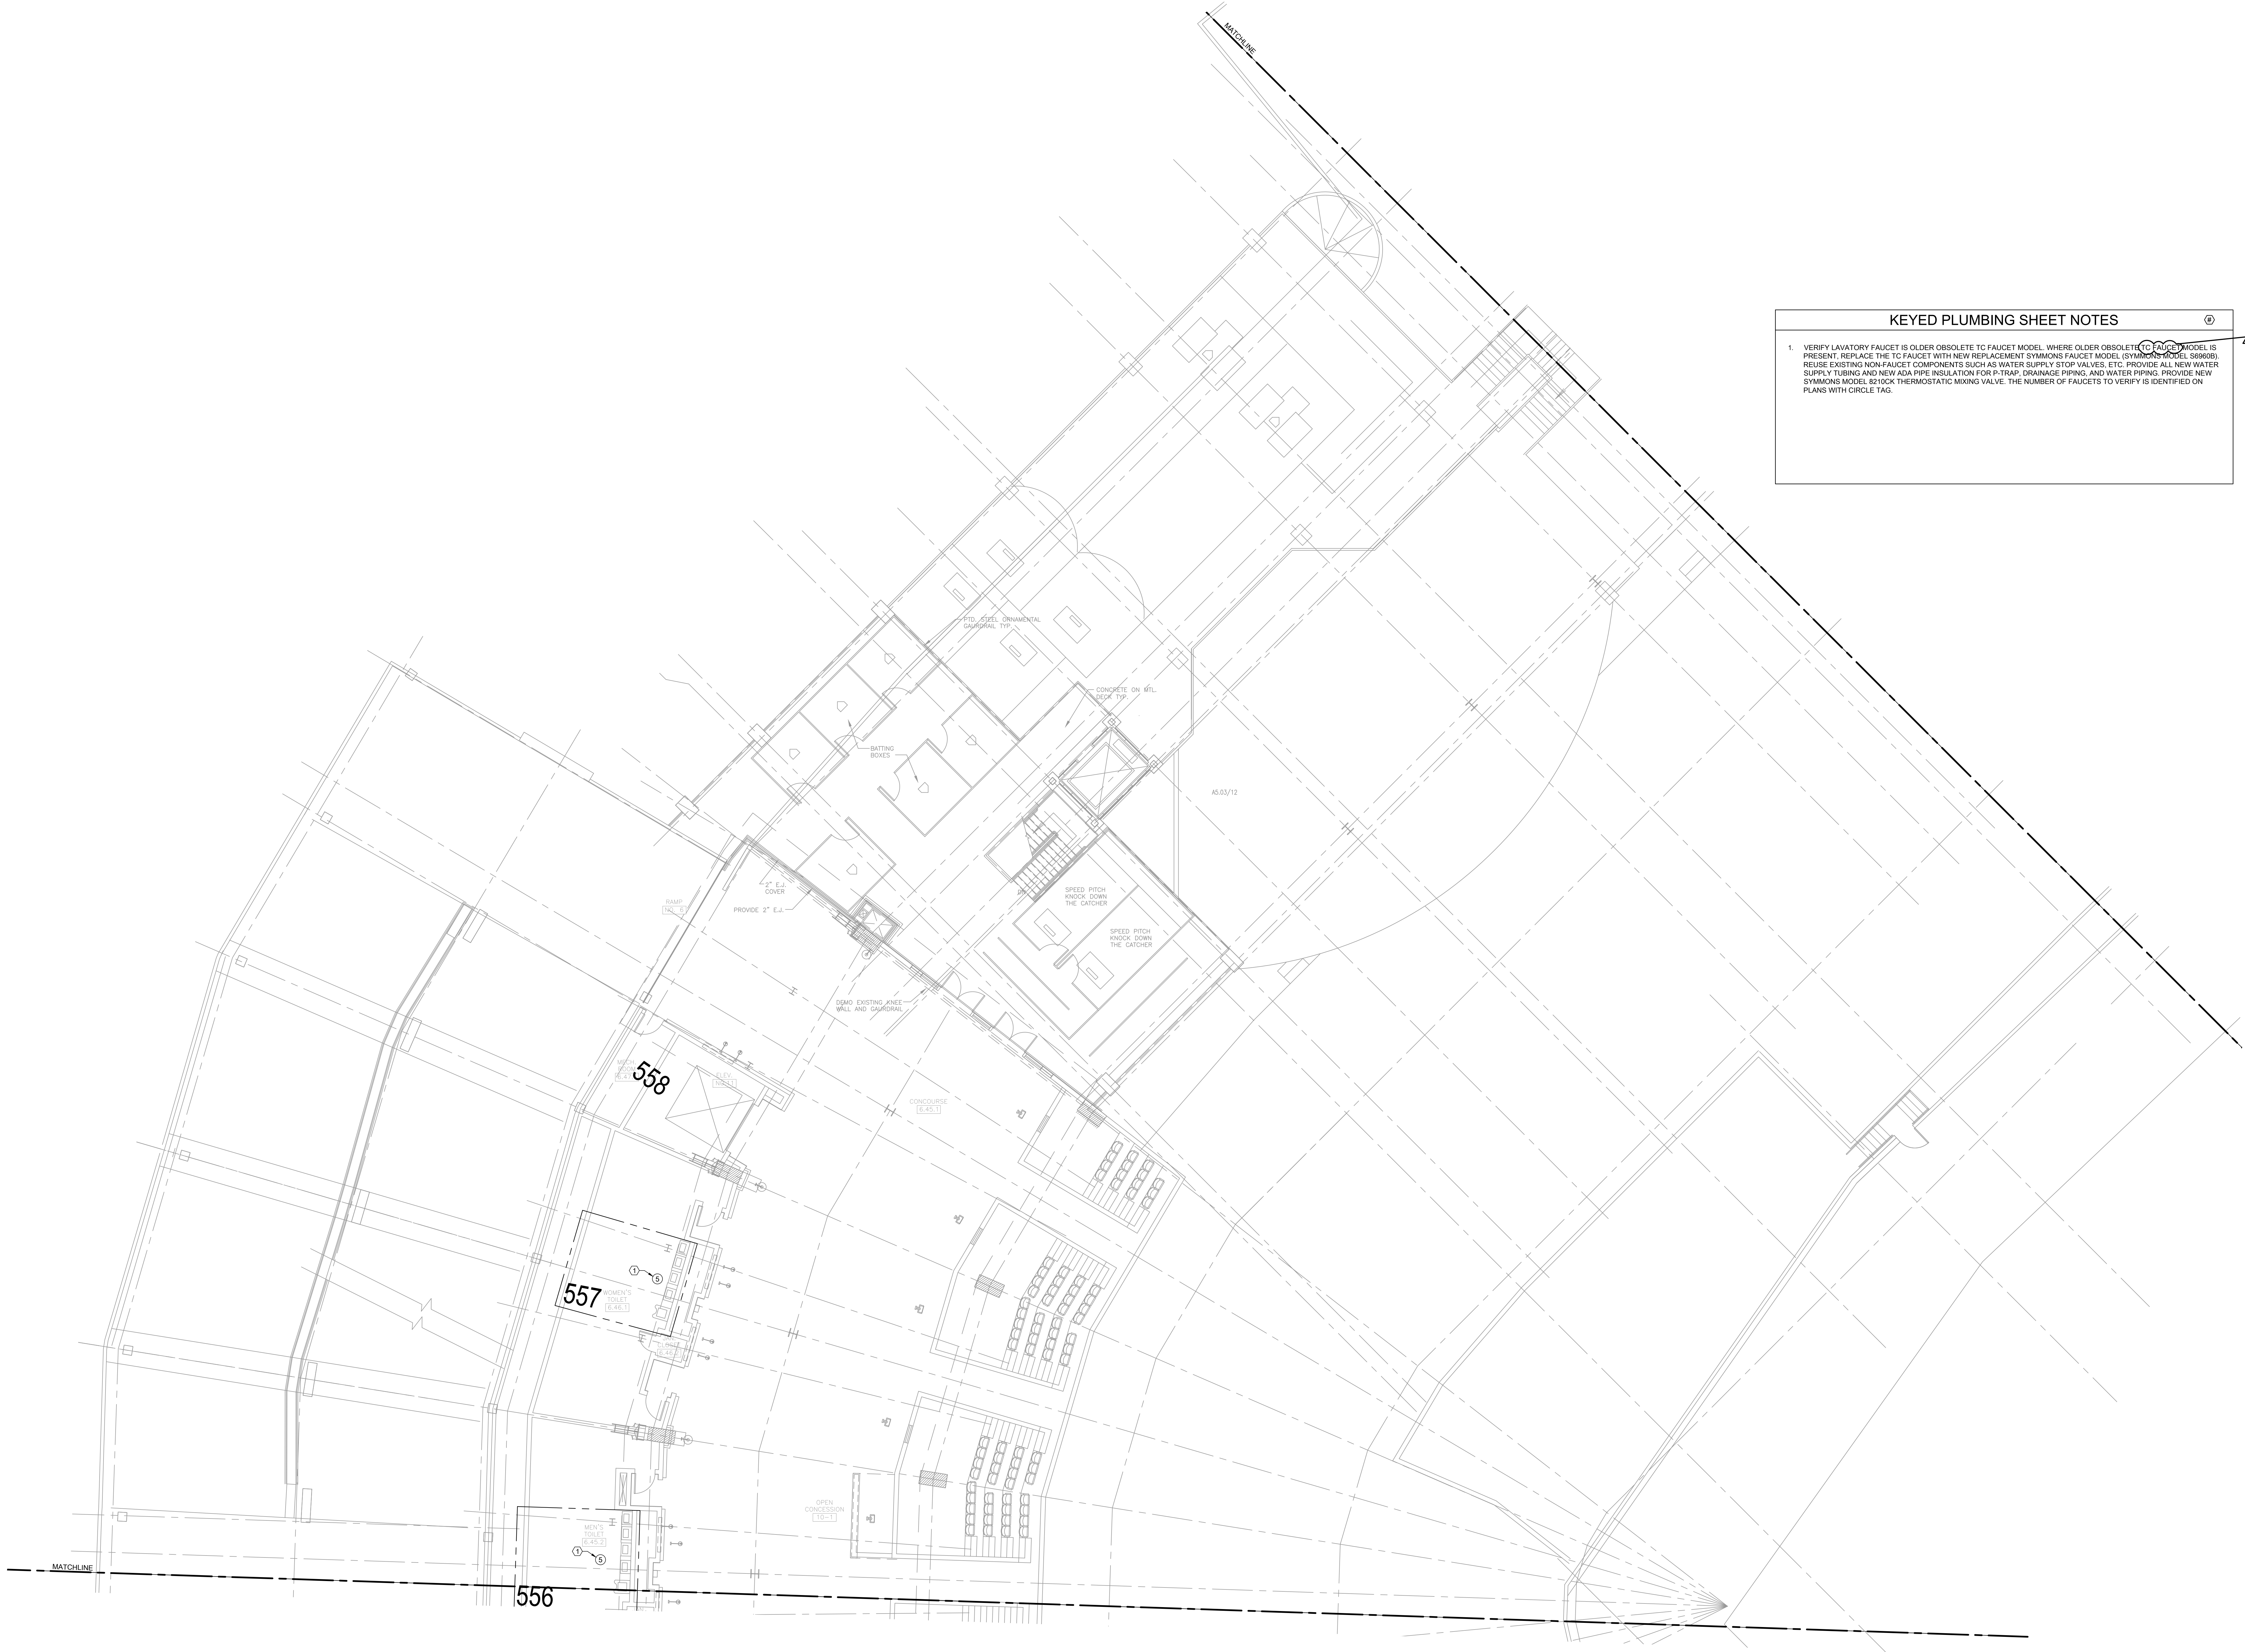

KEYED PLUMBING SHEET NOTES

1. VERIFY LAVATORY FAUCET IS OLDER OBSOLETE TC FAUCET MODEL. WHERE OLDER OBSOLETE TC FAUCET MODEL IS PRESENT, REPLACE THE TC FAUCET WITH NEW REPLACEMENT SYMMONS FAUCET MODEL (SYMMONS MODEL 569608). REUSE EXISTING NON-FAUCET COMPONENTS SUCH AS WATER SUPPLY STOP VALVES, ETC. PROVIDE ALL NEW WATER SUPPLY TUBING AND NEW ADA PIPE INSULATION FOR P-TRAP, DRAINAGE PIPING, AND WATER PIPING. PROVIDE NEW SYMMONS MODEL 521004 THERMOSTATIC MIXING VALVE. THE NUMBER OF FAUCETS TO VERIFY IS IDENTIFIED ON PLANS WITH CIRCLE TAG.




elaraeng.com | (708) 236-0300



INLAND SPOKES
FACILITIES AUTHORITY

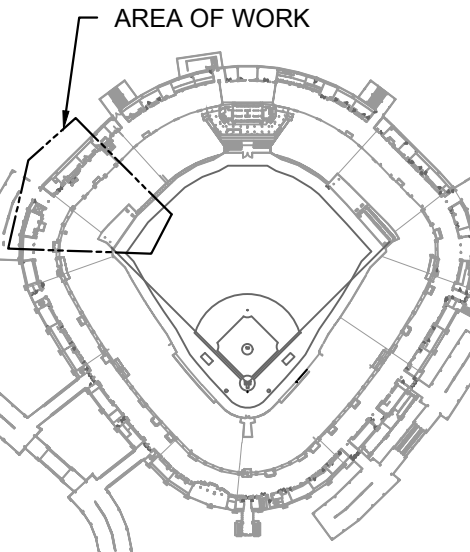

KEY PLAN:


ISSUE/REVISION:

REV.	DATE	DESCRIPTION
1	11/14/25	ISSUE FOR BID
2	11/09/25	ISSUE FOR ADDENDUM NO. 1

PROJECT:
GUARANTEED RATE FIELD -
WASTE/VENT PIPING FY2026

333 W 35TH STREET,
CHICAGO, ILLINOIS 60616

DRAWING TITLE:
PLUMBING PLAN - LEVEL 500 -
SECTION 10

DESIGNED BY: CF
CHECKED BY: MS
PROJECT NO: 25081
SCALE: 1/8" = 1'-0"

SHEET NO.
P1.510